


THE ARCHITECT HEREBY EXPRESSLY RESERVES THE COPYRIGHT AND PROPERTY RIGHTS IN THESE PLANS. DRAWINGS ARE NOT TO BE REPRODUCED, CHANGED, OR COPIED IN ANY FORM OR MANNER WHATSOEVER WITHOUT FIRST OBTAINING WRITTEN PERMISSION AND CONSENT. NOR ARE THEY TO BE ASSIGNED TO ANY PARTY WITHOUT FIRST OBTAINING SAID WRITTEN PERMISSION AND CONSENT.

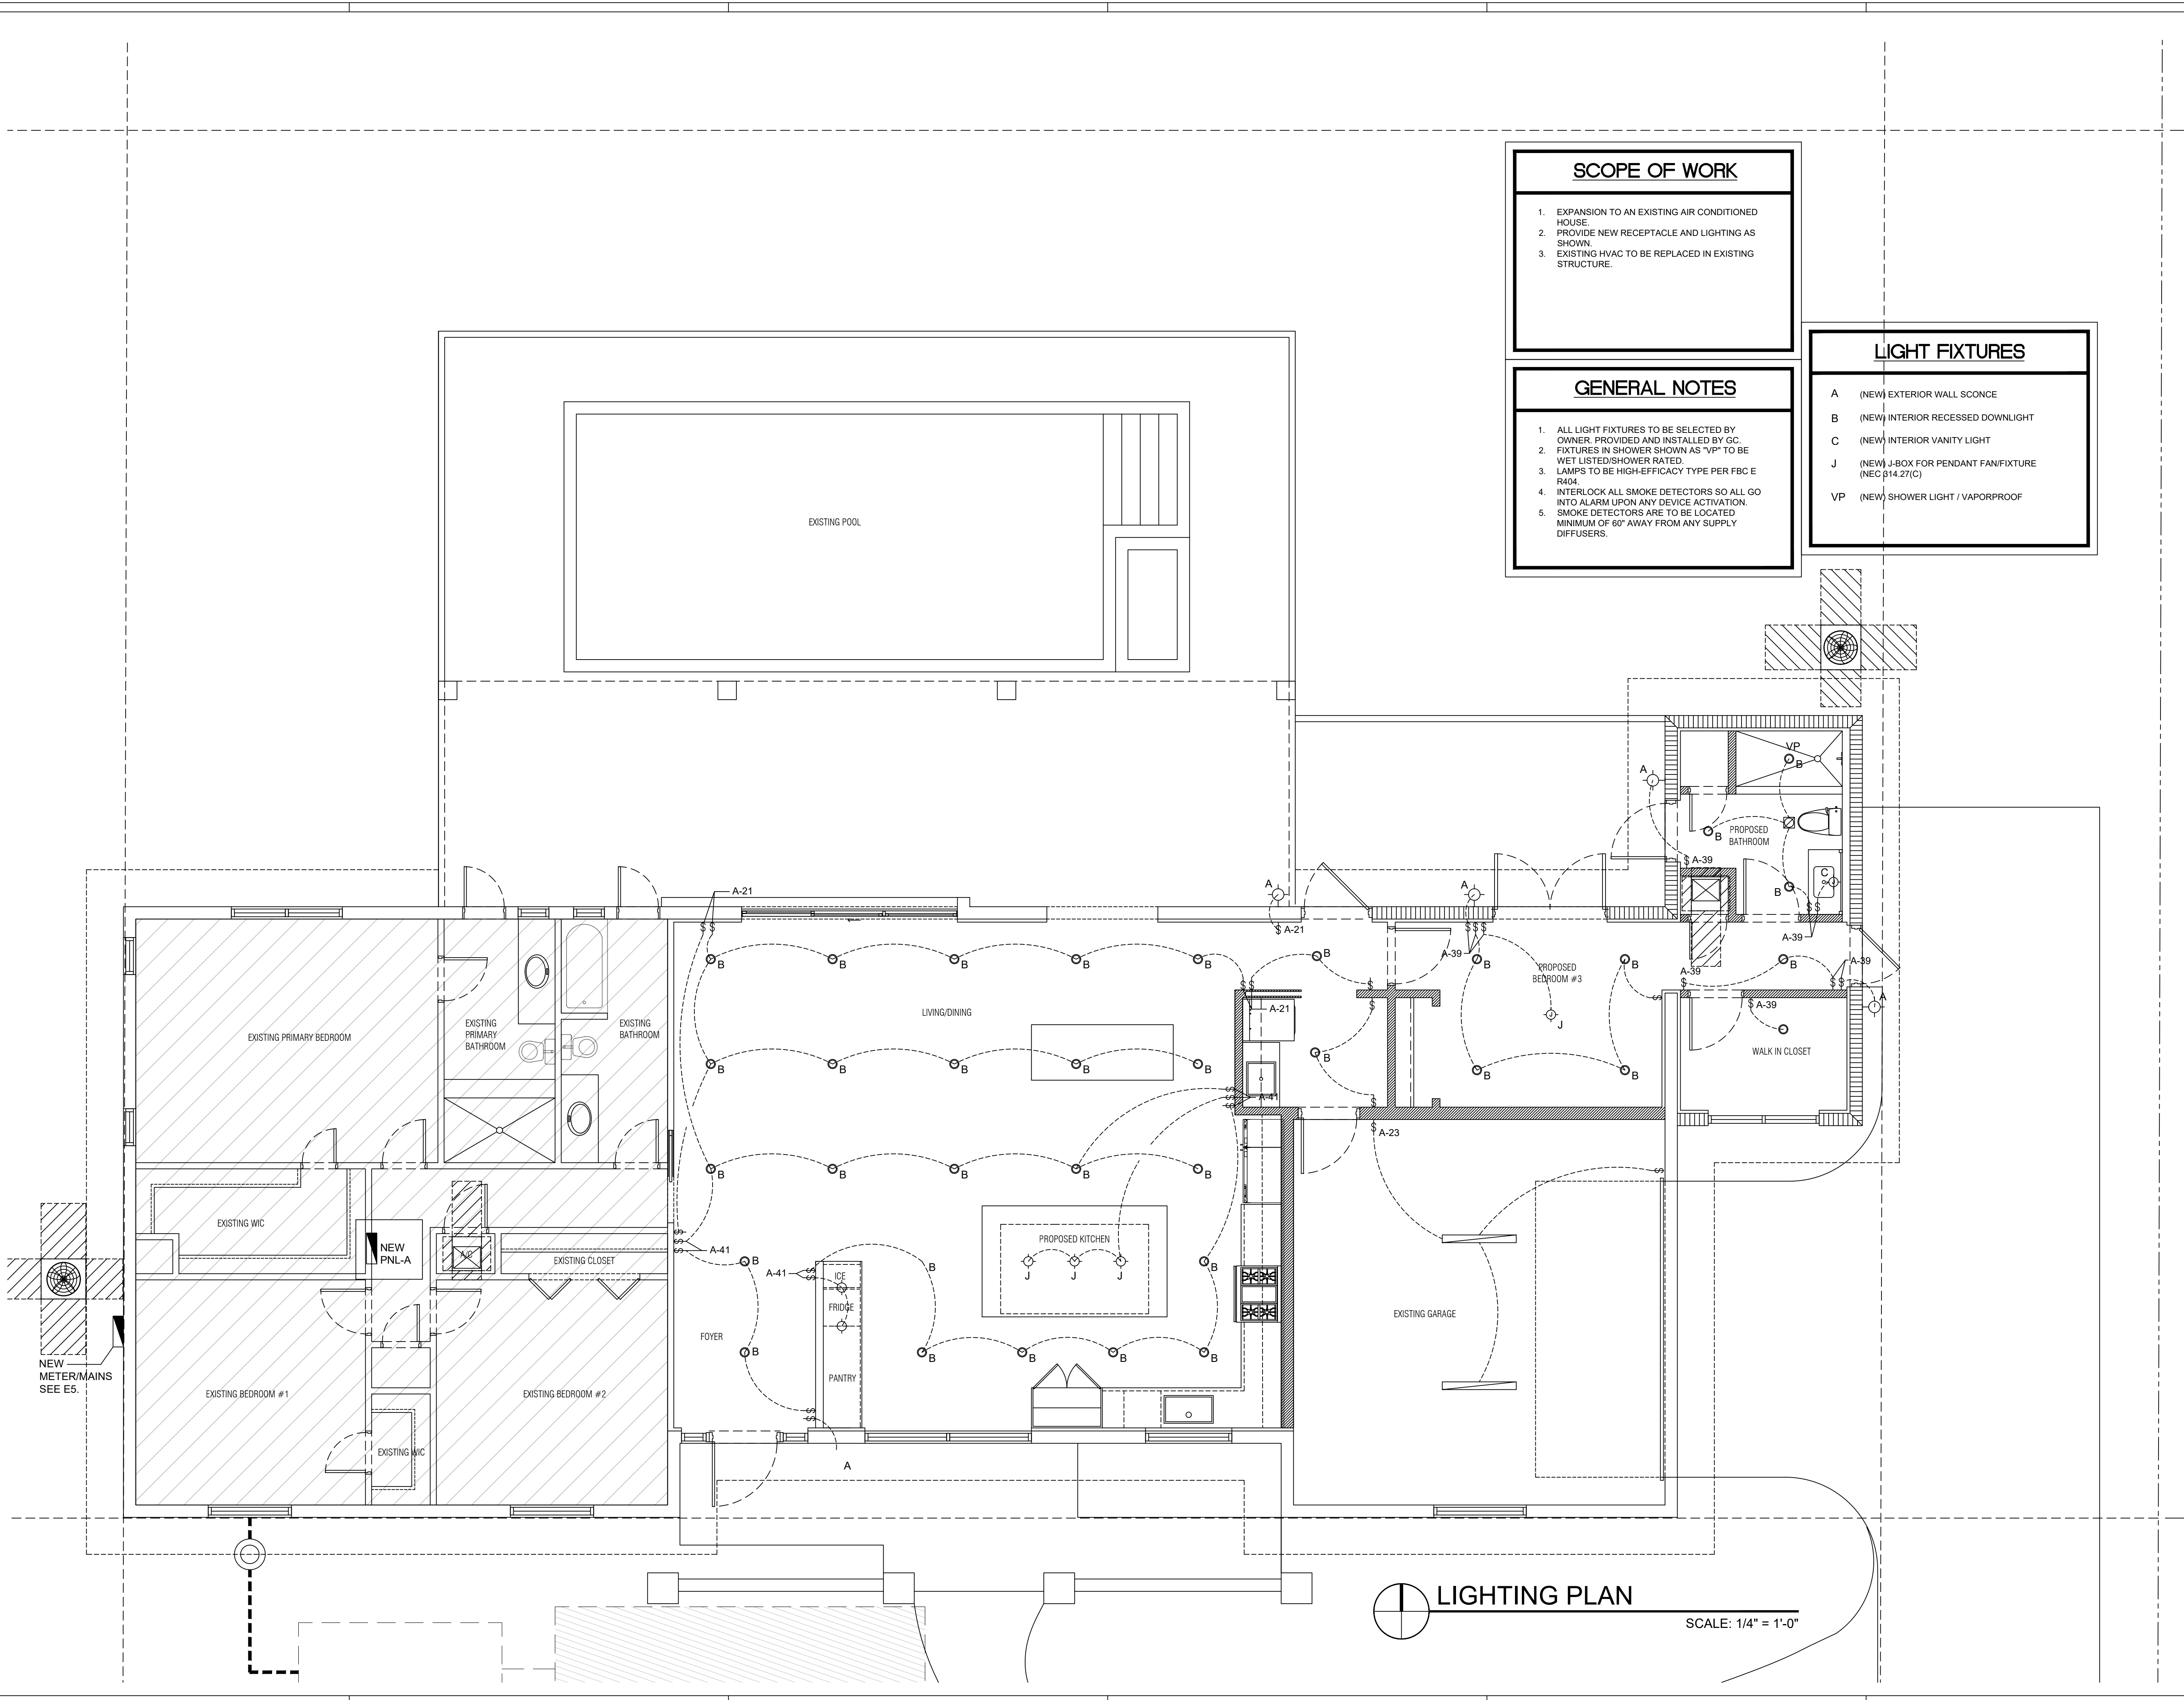

SCOPE OF WORK

1. EXPANSION TO AN EXISTING AIR CONDITIONED HOUSE.
2. PROVIDE NEW RECEPTACLE AND LIGHTING AS SHOWN.
3. EXISTING HVAC TO BE REPLACED IN EXISTING STRUCTURE.

GENERAL NOTES

1. ALL LIGHT FIXTURES TO BE SELECTED BY OWNER. PROVIDED AND INSTALLED BY GC.
2. FIXTURES IN SHOWER SHOWN AS "VP" TO BE WET LISTED/SHOWER RATED.
3. LAMPS TO BE HIGH-EFFICACY TYPE PER FBC E R404.
4. INTERLOCK ALL SMOKE DETECTORS SO ALL GO INTO ALARM UPON ANY DEVICE ACTIVATION.
5. SMOKE DETECTORS ARE TO BE LOCATED MINIMUM OF 60" AWAY FROM ANY SUPPLY DIFFUSERS.

LIGHT FIXTURES

- A (NEW) EXTERIOR WALL SCONCE
- B (NEW) INTERIOR RECESSED DOWNLIGHT
- C (NEW) INTERIOR VANITY LIGHT
- J (NEW) J-BOX FOR PENDANT FAN/FIXTURE (NEC §14.27(C))
- VP (NEW) SHOWER LIGHT / VAPORPROOF

NEW
METER/MAINS
SEE E5.

EXISTING PRIMARY BEDROOM

EXISTING PRIMARY BATHROOM

EXISTING BATHROOM

LIVING/DINING

NEW
PNL-A

EXISTING CLOSET

FOYER

ICE

FRIDGE

PANTRY

PROPOSED KITCHEN

EXISTING GARAGE

PROPOSED BEDROOM #3

WALK IN CLOSET

LIGHTING PLAN

SCALE: 1/4" = 1'-0"

ADDITION & RESTORATION FOR:

MAZZINI & MELINE
RESIDENCE

10300 SW 70TH AVE,
MIAMI, FL 33156



Digitally signed by
Edgardo J. Betancourt
Santiago
Date: 2023.08.24
16:08:49-04'00'



DRAWN BY
DATE 04.03.23 PROJECT
CHECKED BY 22-84

REVISIONS

LIGHTING
PLAN

CONSTRUCTION DOCUMENTS

E3