
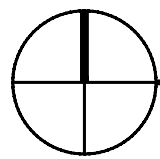


THE ARCHITECT HEREBY EXPRESSLY RESERVES THE COPYRIGHT AND PROPERTY RIGHTS IN THESE PLANS. DRAWINGS ARE NOT TO BE REPRODUCED, CHANGED, OR COPIED IN ANY FORM OR MANNER WHATSOEVER WITHOUT FIRST OBTAINING WRITTEN PERMISSION AND CONSENT. NOR ARE THEY TO BE ASSIGNED TO ANY PARTY WITHOUT FIRST OBTAINING SAID WRITTEN PERMISSION AND CONSENT.

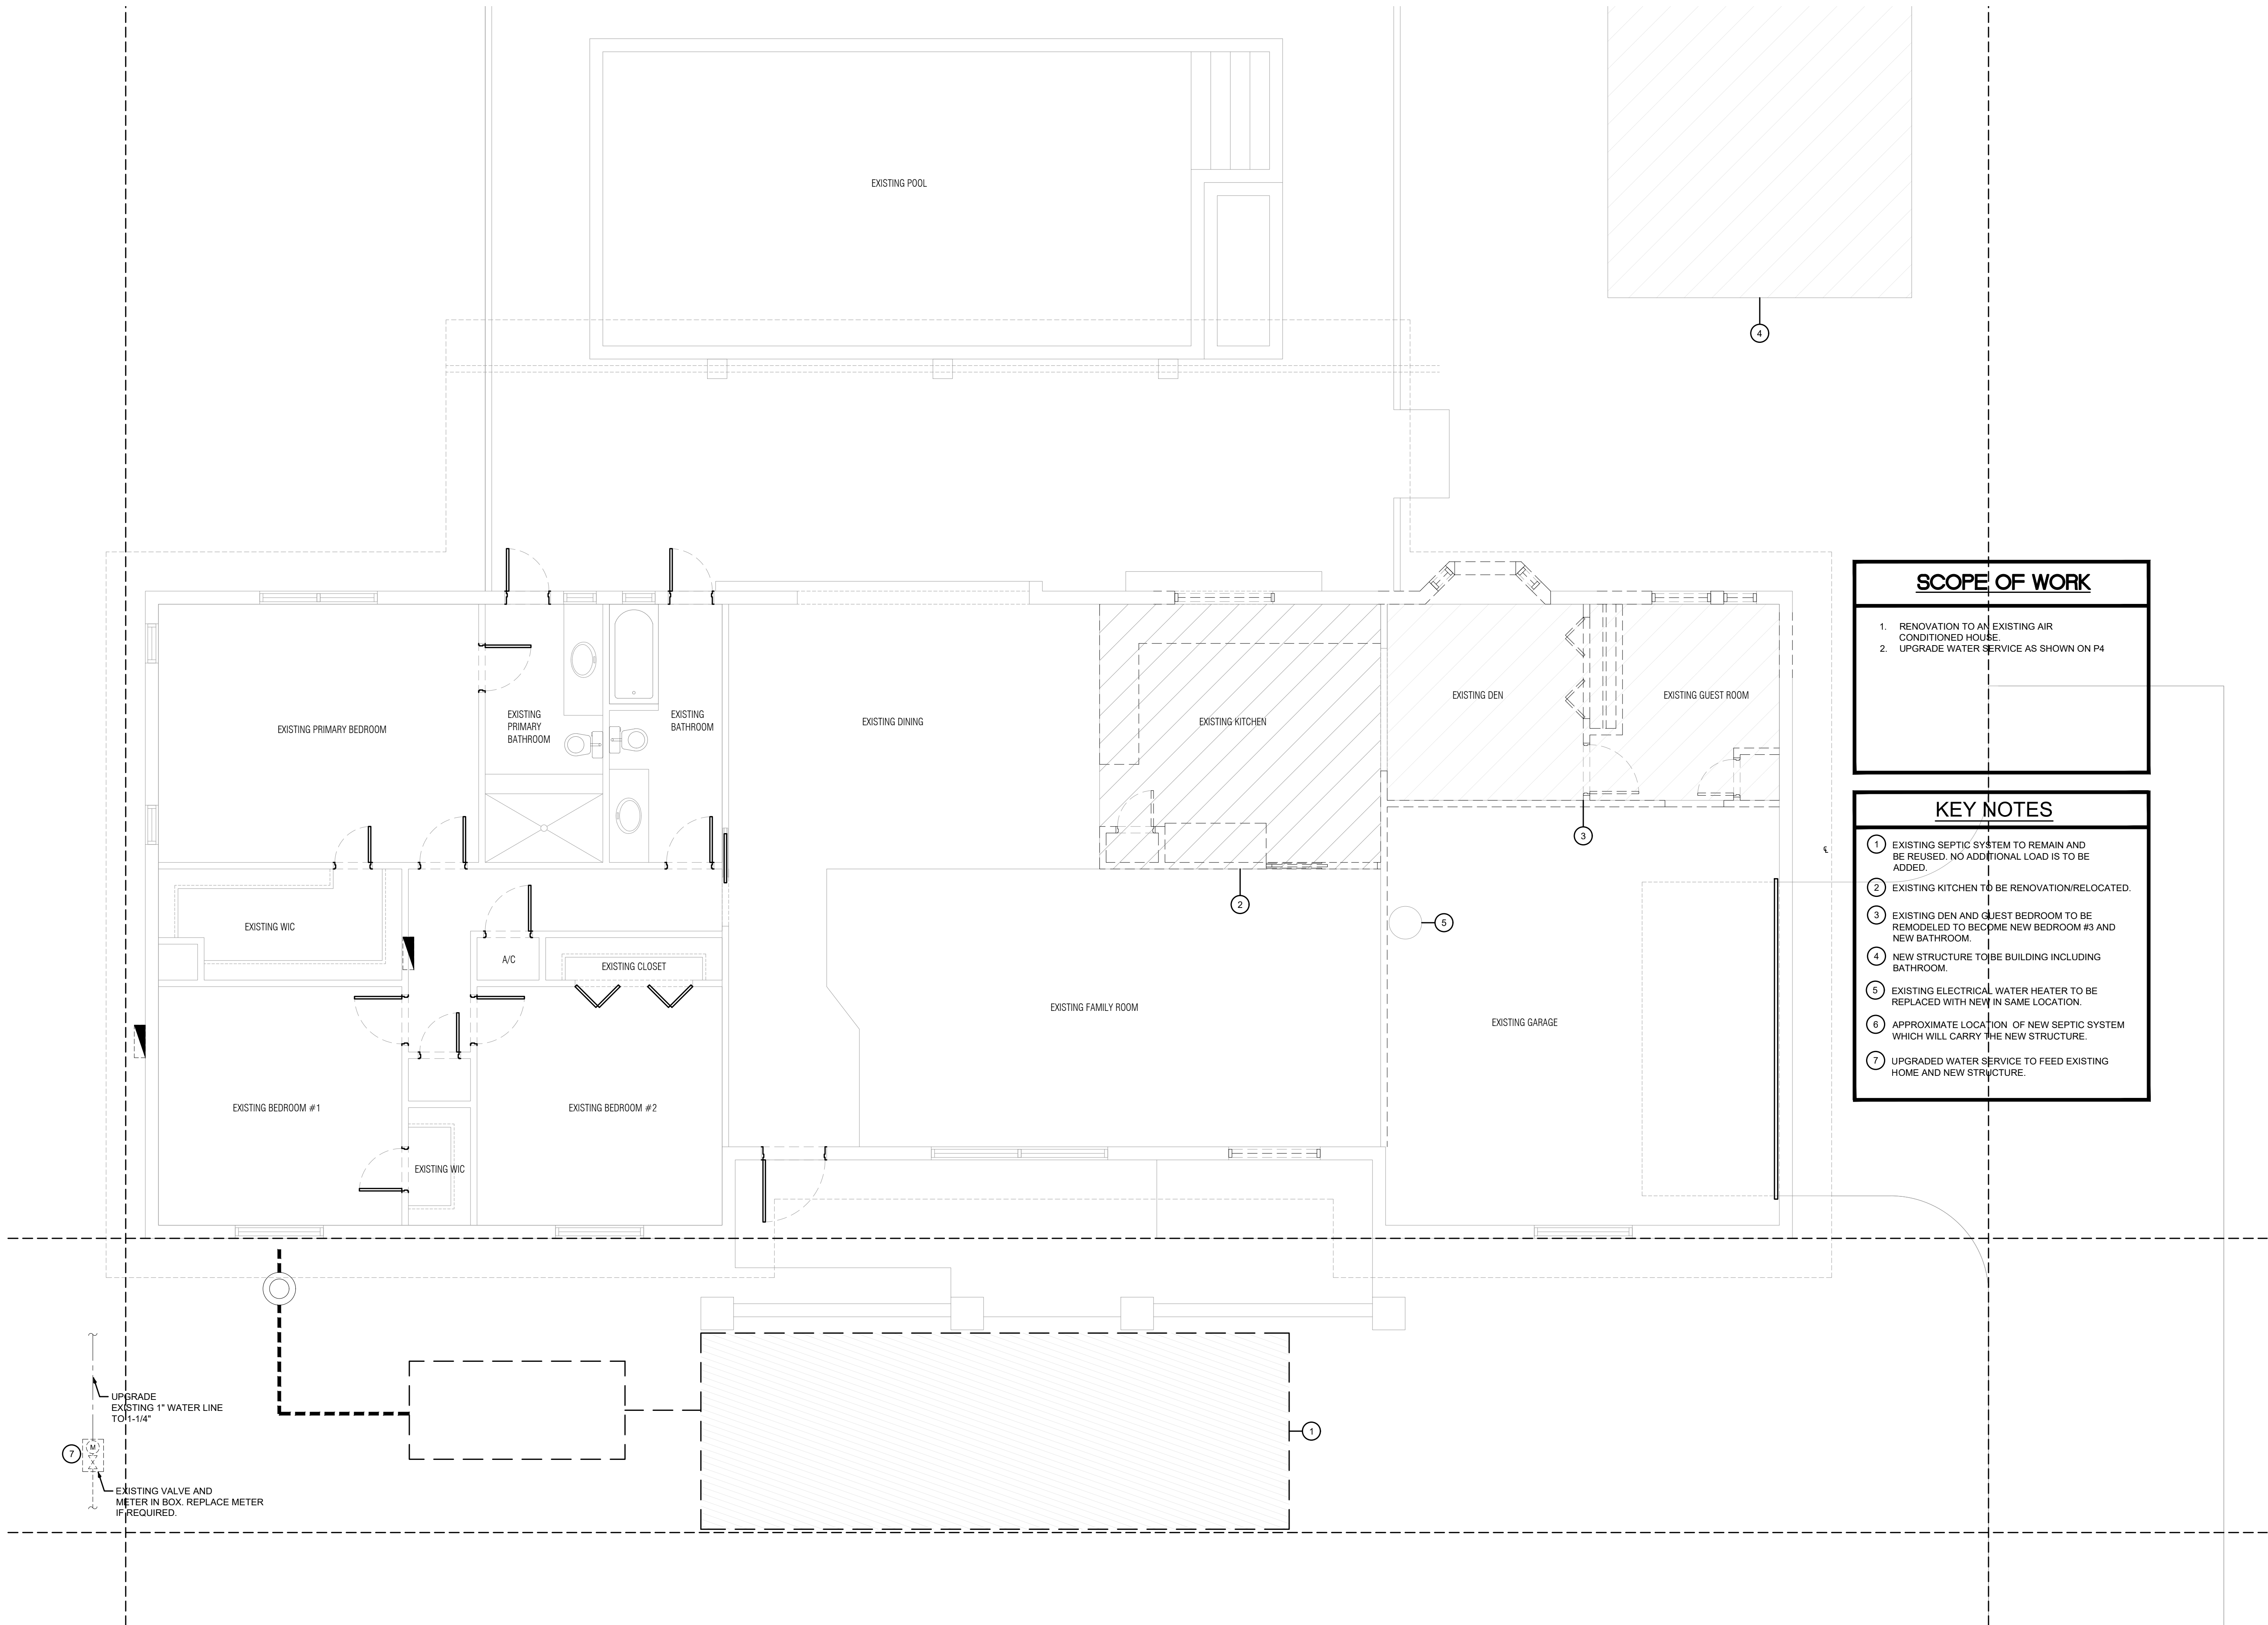

EXISTING PLUMBING PLAN


SCALE: 1/8" = 1'-0"

SCOPE OF WORK

1. RENOVATION TO AN EXISTING AIR CONDITIONED HOUSE.
2. UPGRADE WATER SERVICE AS SHOWN ON P4

KEY NOTES

1. EXISTING SEPTIC SYSTEM TO REMAIN AND BE REUSED. NO ADDITIONAL LOAD IS TO BE ADDED.
2. EXISTING KITCHEN TO BE RENOVATION/RELOCATED.
3. EXISTING DEN AND GUEST BEDROOM TO BE REMODELED TO BECOME NEW BEDROOM #3 AND NEW BATHROOM.
4. NEW STRUCTURE TO BE BUILDING INCLUDING BATHROOM.
5. EXISTING ELECTRICAL WATER HEATER TO BE REPLACED WITH NEW IN SAME LOCATION.
6. APPROXIMATE LOCATION OF NEW SEPTIC SYSTEM WHICH WILL CARRY THE NEW STRUCTURE.
7. UPGRADED WATER SERVICE TO FEED EXISTING HOME AND NEW STRUCTURE.

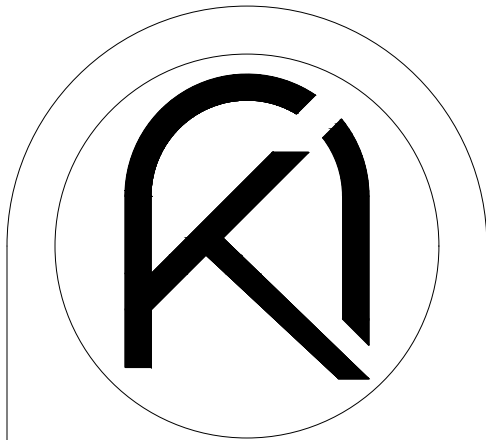

ARKO ARCHITECTURE, LLC
2980 McFARLANE RD, SUITE 200
COCONUT GROVE, FL 33133
edgardo@thearkogroup.com
eduardo@thearkogroup.com
c: 954.647.1447
c: 305.951.6181


ADDITION & RESTORATION FOR:

MAZZINI & MELINE
RESIDENCE

10300 SW 70TH AVE,
MIAMI, FL 33156



Digitally signed by
Edgardo J. Betancourt
Santiago
Date: 2023.08.24
16:08:43-04'00'

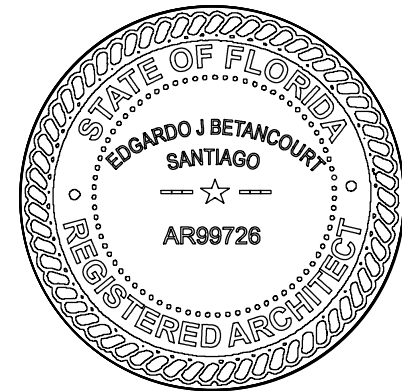

DRAWN BY
DATE 04.03.23 PROJECT
CHECKED BY 22-84

REVISIONS

EXISTING
PLUMBING
PLAN

CONSTRUCTION DOCUMENTS

P2