


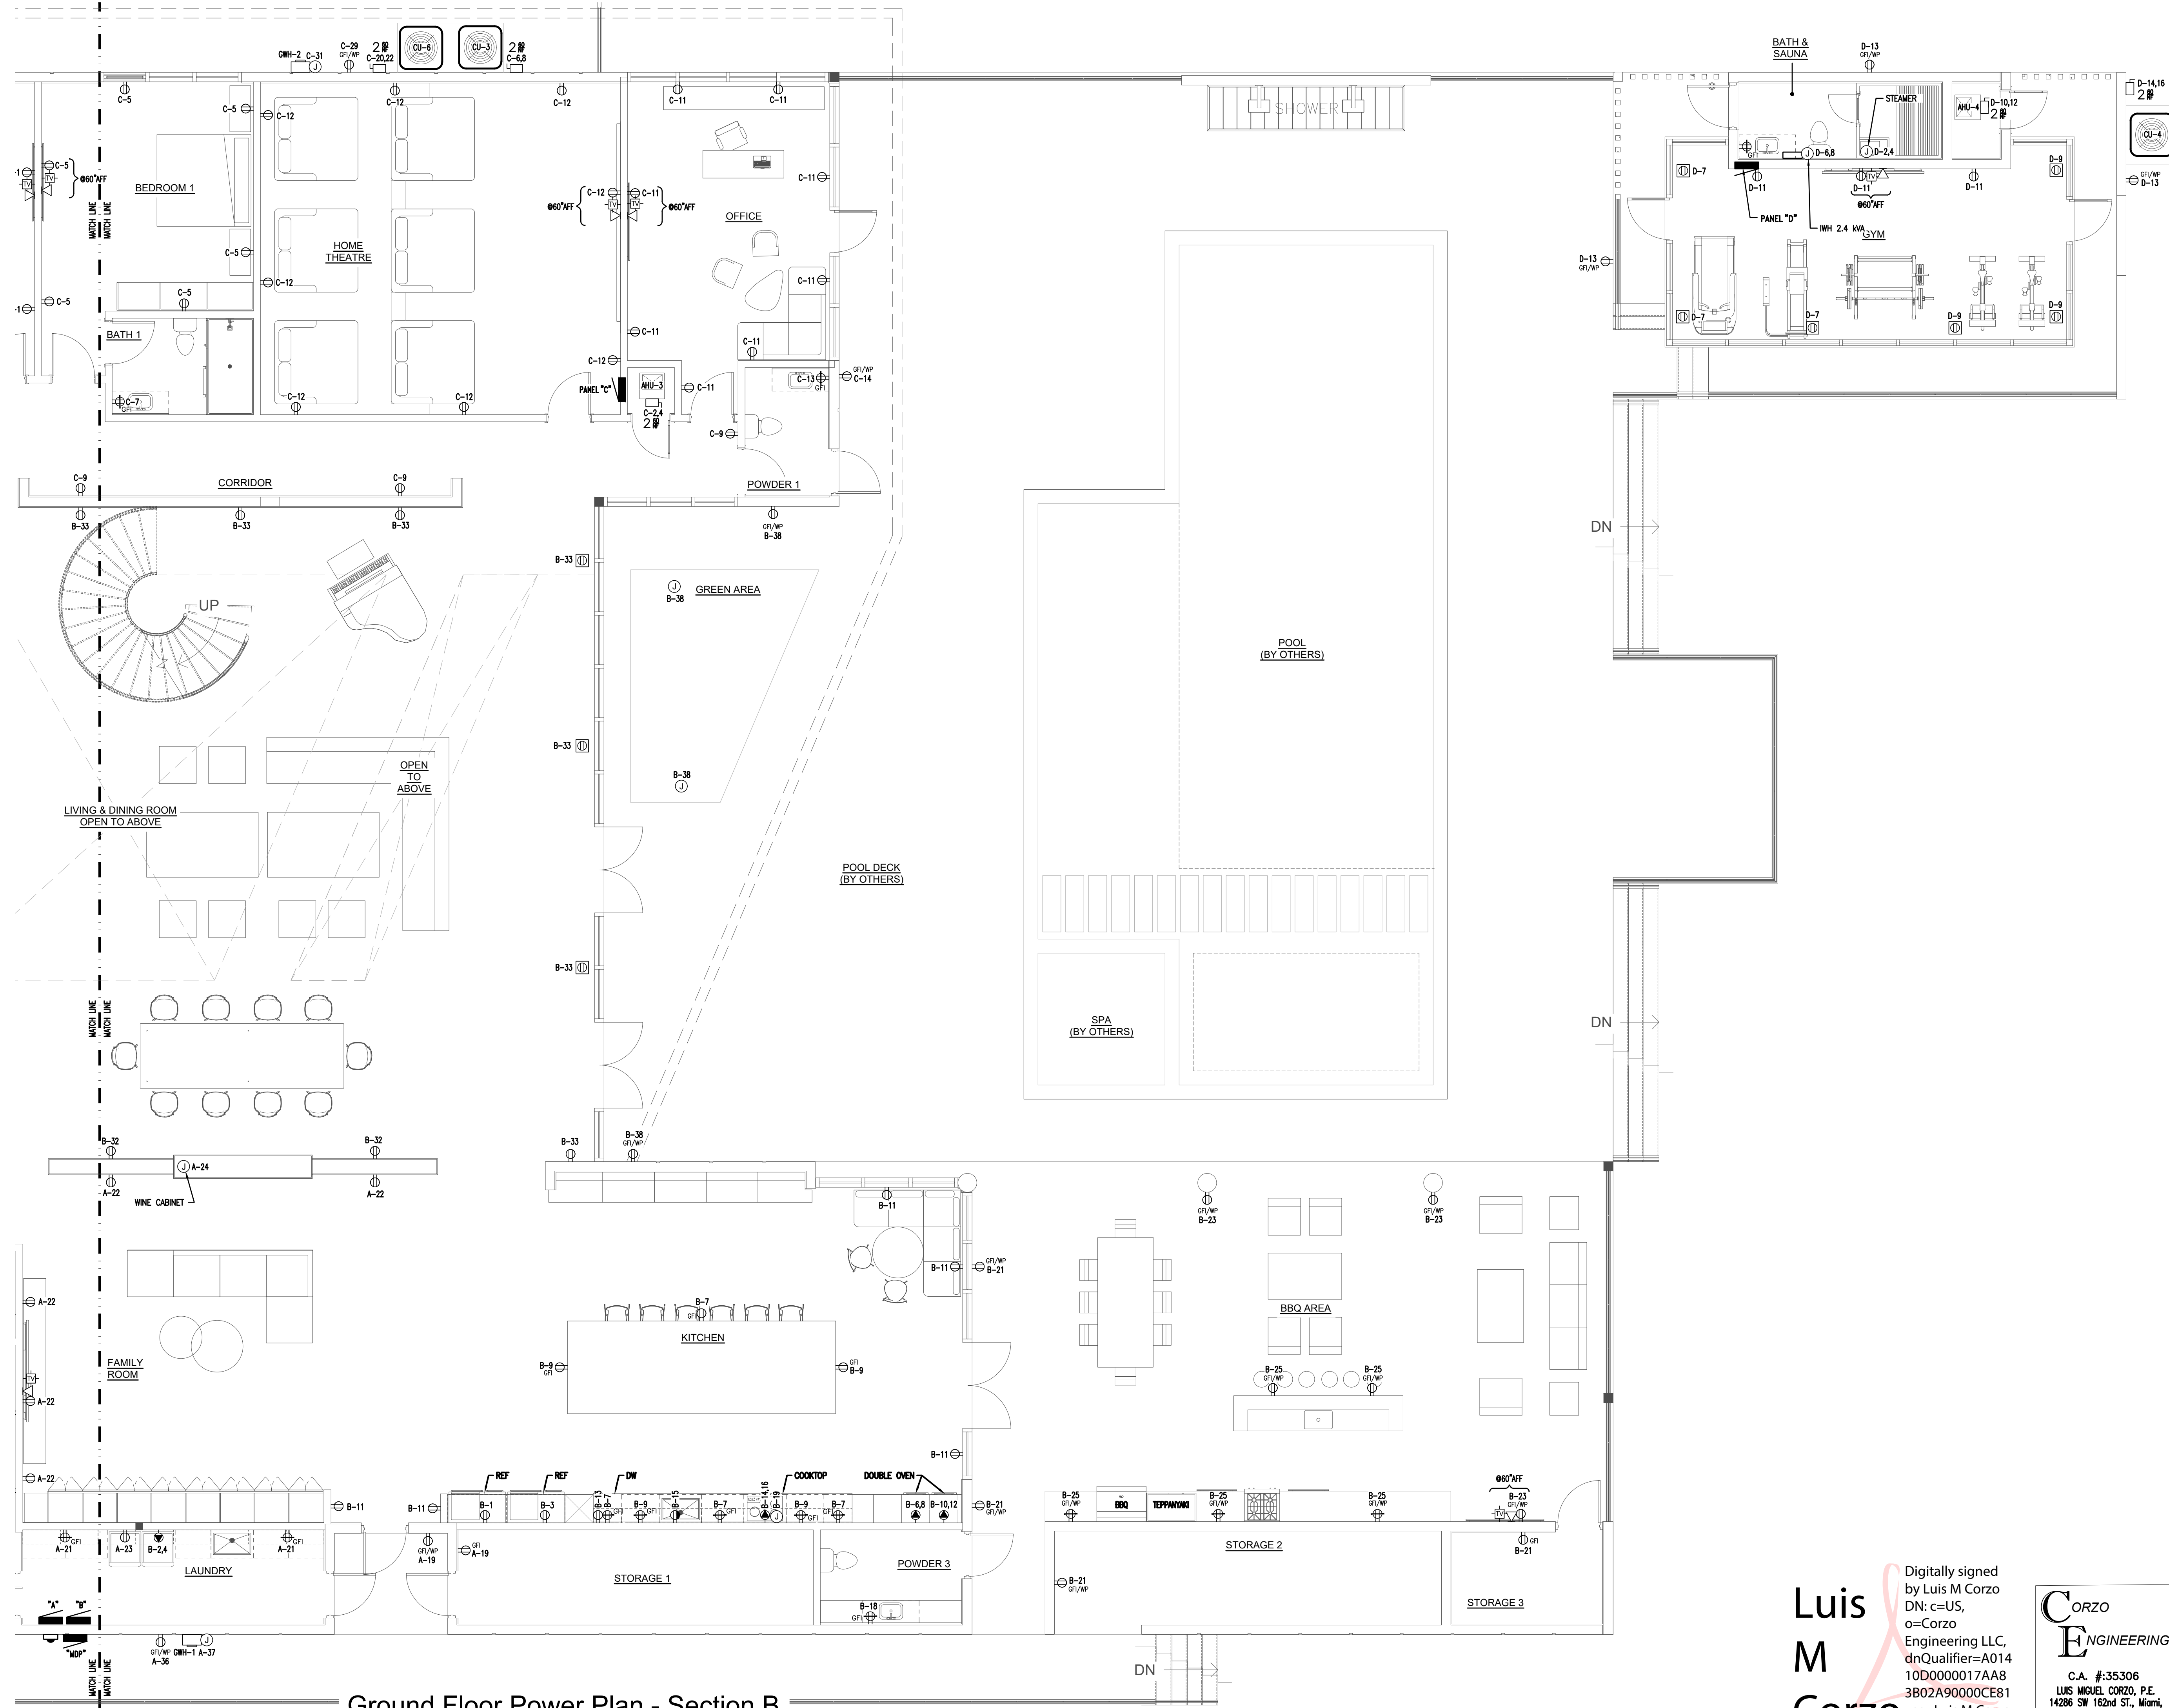

Ground Floor Power Plan - Section B
Scale: 3/16" = 1' - 0"

Luis M Corzo

Digitally signed by Luis M Corzo
DN: c=US, o=Corzo Engineering LLC, dnQualifier=A01410D0000017AA83B02A90000CE81, cn=Luis M Corzo
Date: 2023.08.29 12:18:53 -04'00'

CORZO ENGINEERING

C.A. #:35306
LUIS MIGUEL CORZO, P.E.
14286 SW 162nd ST., Miami, FL 33177
Phone: (954) 536-9535
Email: luis@corzo88@gmail.com
Florida P.E. # 90966

REVISIONS

Rev.	Date	Description

FIDANZA'S FAMILY HOUSE
NEW CONSTRUCTION
11041 SW 77TH AVE, PINECREST, FL 33156

LUIS MIGUEL CORZO
LICENSE
No 90966
STATE OF FLORIDA
PROFESSIONAL ENGINEER

VILLA & ASSOCIATES INC.
ARCHITECTURE - PLANNING - INTERIOR DESIGN
5801 SW 69 AVENUE - MIAMI, FLORIDA 33156
TEL. 305-613-0865 - E-Mail Jvillarchitect@gmail.com

CONSULTANT : ARCHI-TEK STUDIO CORP.
TEL. 305-799-8016 - E-Mail maguilar@architekstudio.com

DATE:
10-20-2022

SCALE:
AS SHOWN

PROJECT NO:

DRAWING NO :
E-1.2