


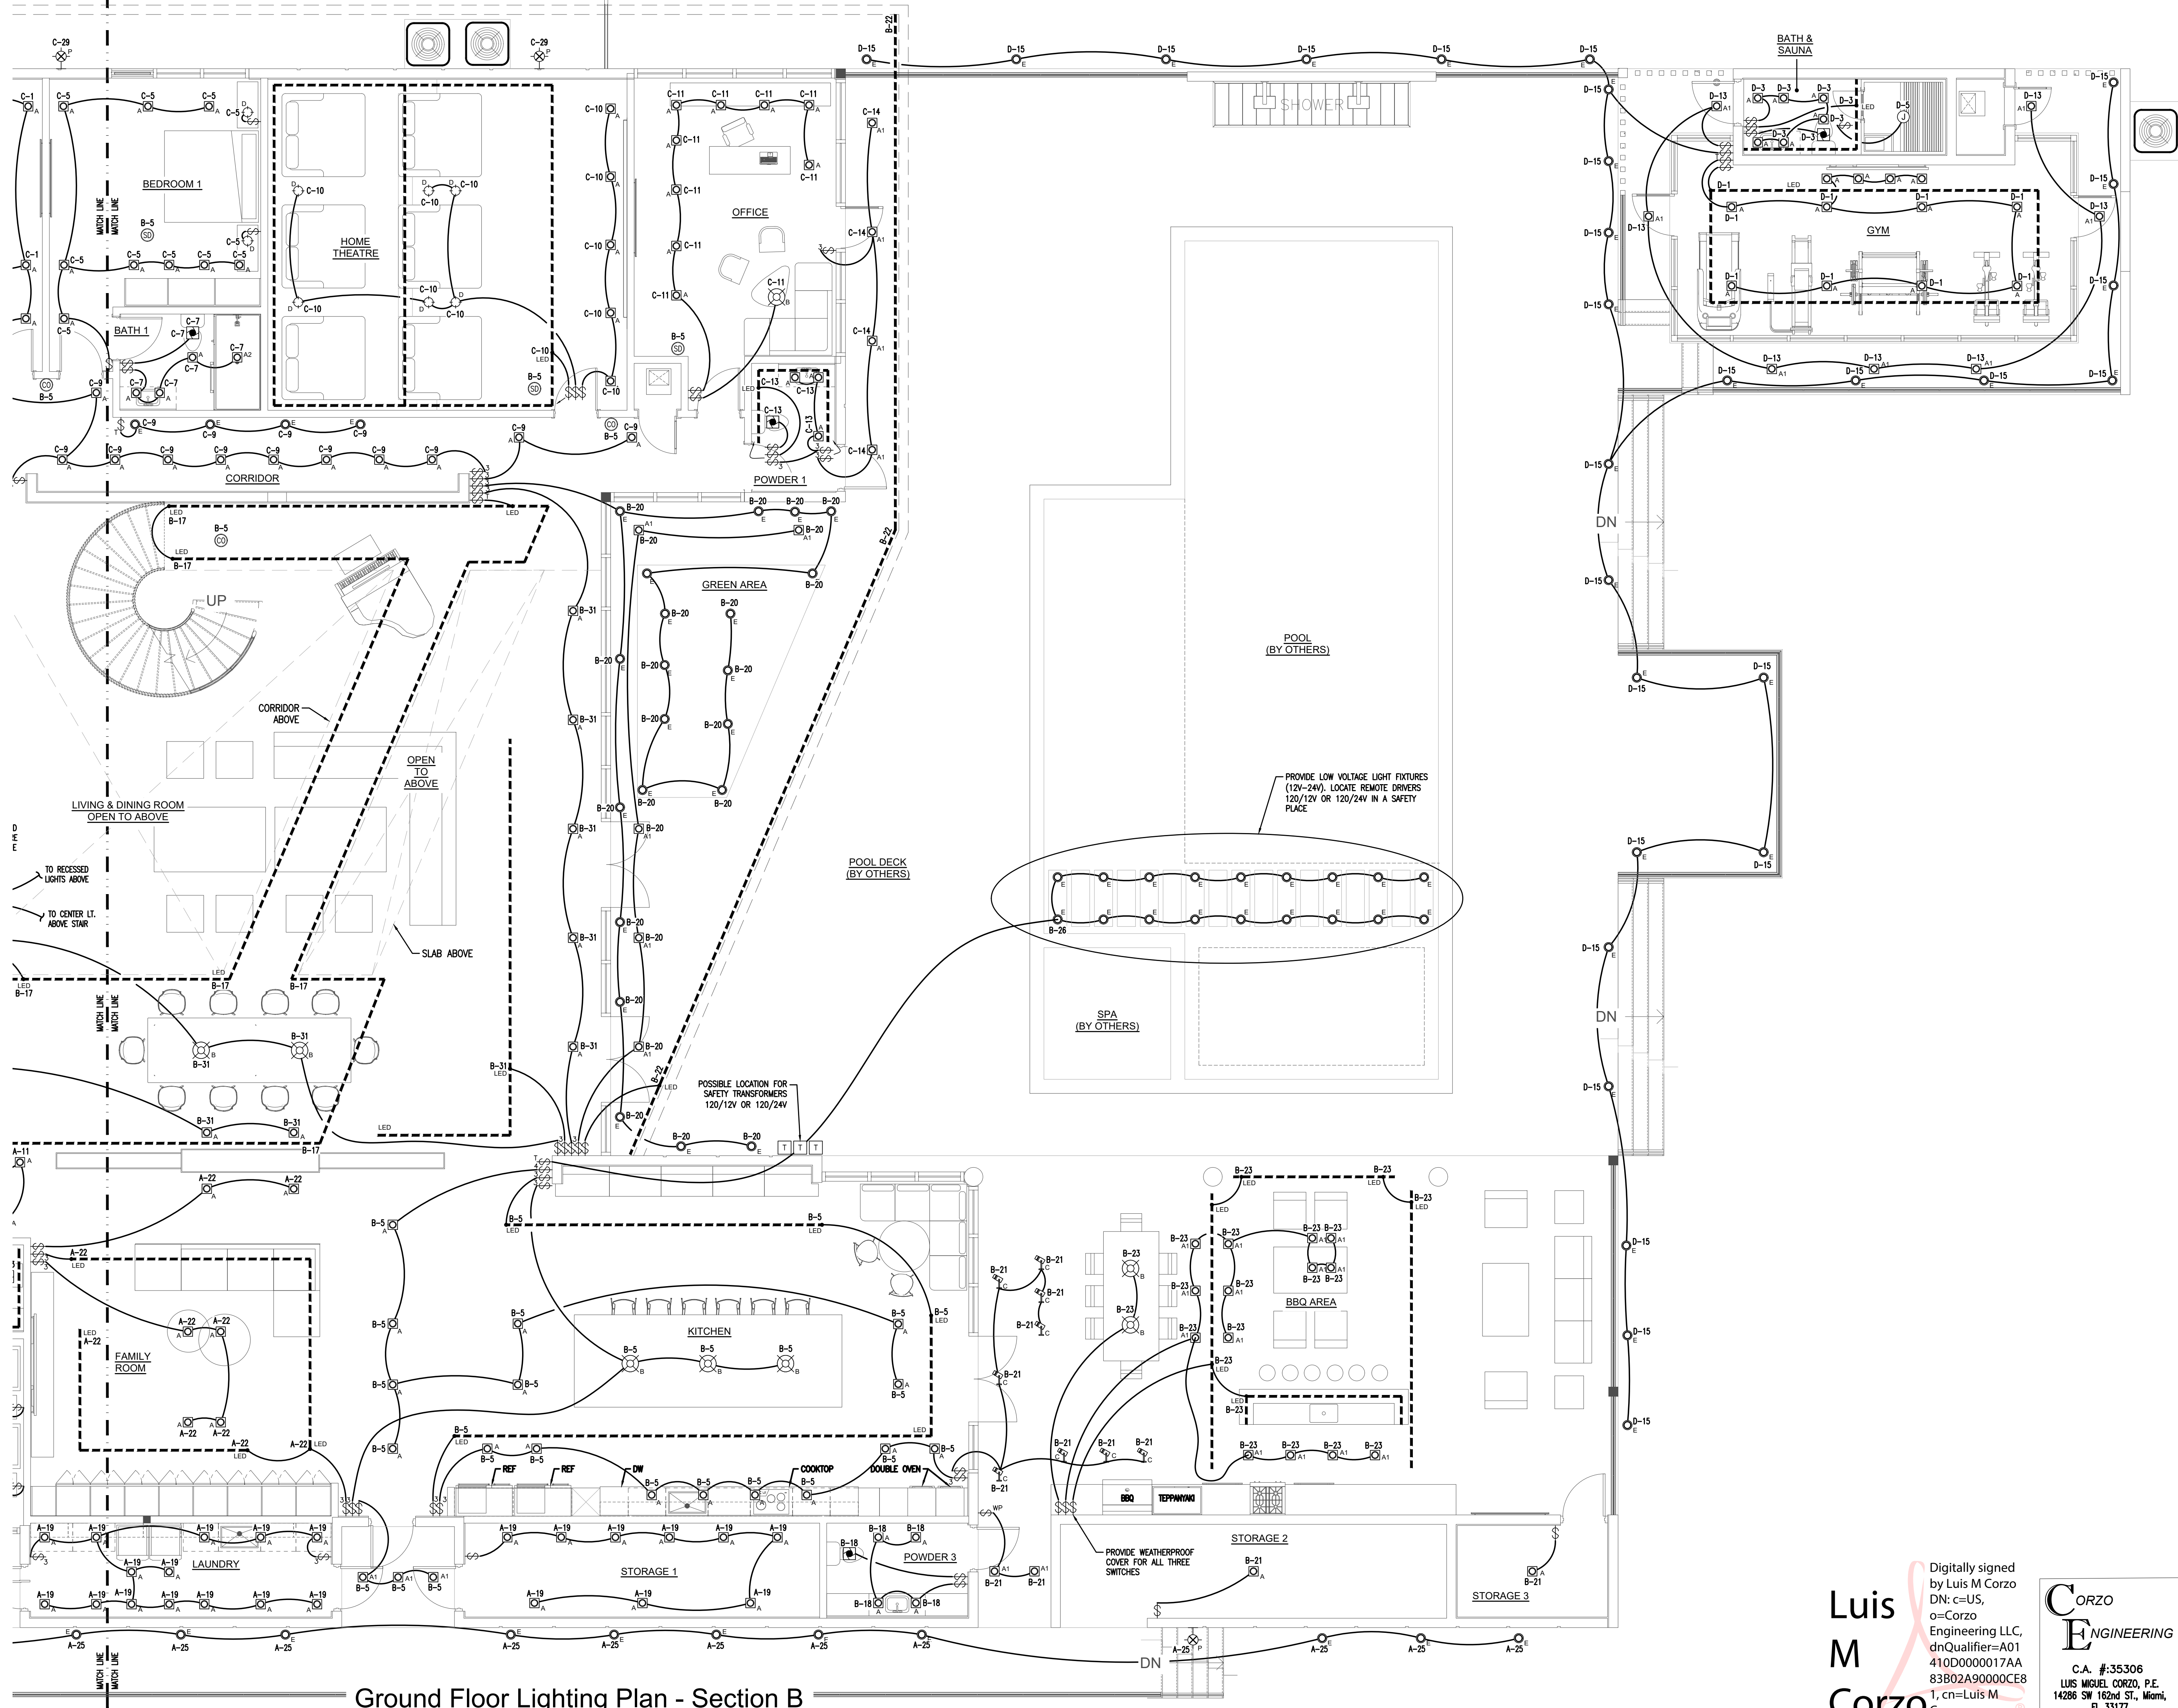

Ground Floor Lighting Plan - Section B

Scale: 3/16" = 1' - 0"


Luis
M
Corzo

Digitally signed
by Luis M Corzo
DN: c=US,
o=Corzo
Engineering LLC,
dnQualifier=A01
410D000017AA
83B02A90000CE8
1, cn=Luis M.
Corzo
Date: 2023.08.29
12:19:51 -04'00'


CORZO
ENGINEERING
C.A. #35306
LUIS MIGUEL CORZO, P.E.
14286 SW 162nd ST., Miami,
FL 33177
Phone: (954) 536-9535
Email: luisincorzo88@gmail.com
Florida P.E. # 90966

REVISIONS	
Rev.	Description

FIDANZA'S FAMILY HOUSE
NEW CONSTRUCTION
11041 SW 77TH AVE, PINECREST, FL 33156

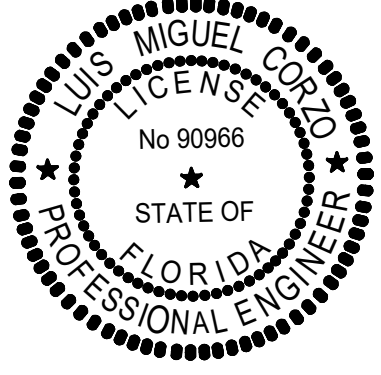

VILLA & ASSOCIATES INC.
ARCHITECTURE PLANNING INTERIOR DESIGN
5801 SW 69 AVENUE MIAMI, FLORIDA 33156
TEL. 305-613-0865 - E-Mail Jvillarchitect@gmail.com
CONSULTANT: ARCHI-TEK STUDIO CORP.
TEL. 305-799-8016 - E-Mail maguilar@architekstudio.com

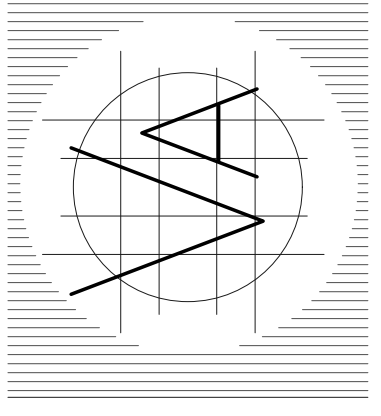

DATE: 10-20-2022	SCALE: AS SHOWN
PROJECT NO:	
DRAWING NO : E-1.4	