


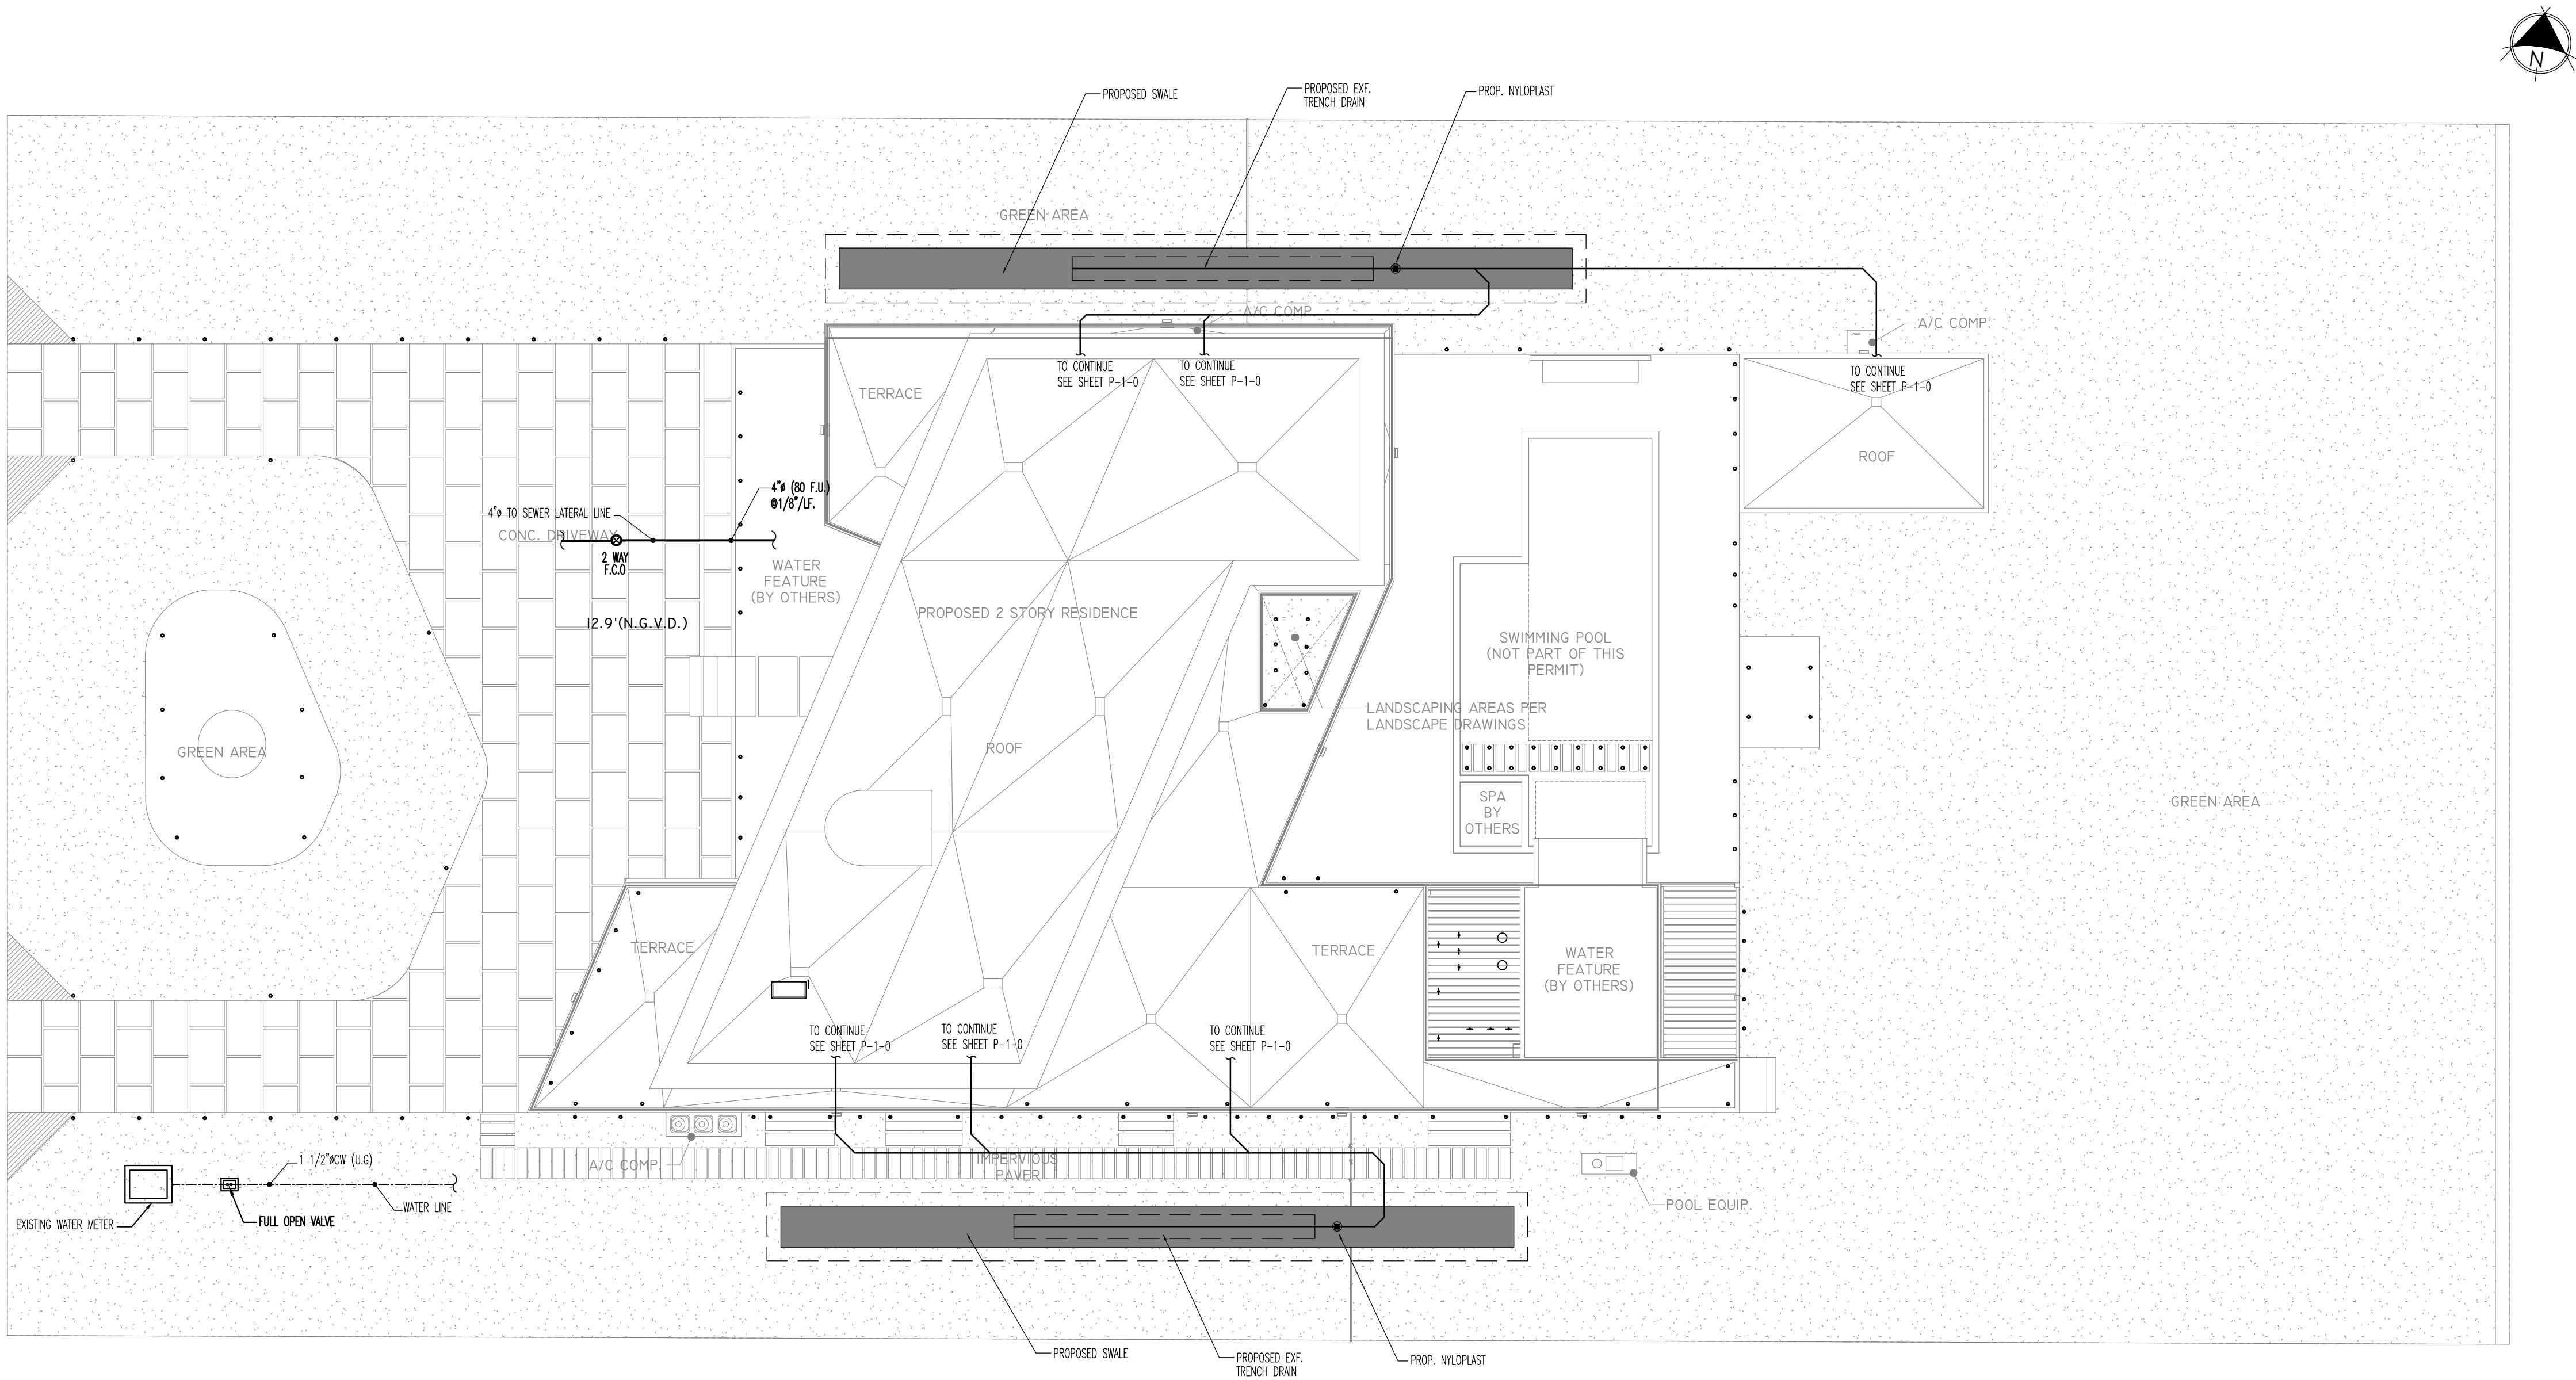

1
P-0-1 PLUMBING SITE PLAN
1/16" = 1'-0"

Eduardo A Barreto
EDUARDO A. BARRETO
P.E. No. 69677
PH: (786) 239-1808
EMAIL: eabsservices@gmail.com


EDUARDO A. BARRETO, PROFESSIONAL ENGINEER, STATE OF FLORIDA, LICENSE NO. 69677. THIS ITEM HAS BEEN DIGITALLY SIGNED AND SEALED BY EDUARDO A. BARRETO, PE, ON DAY AS APPEAR ON SEAL. PRINTED COPIES OF THIS DOCUMENT ARE NOT CONSIDERED SIGNED AND SEALED AND THE SIGNATURE MUST BE VERIFIED ON ANY ELECTRONIC COPIES.

REVISIONS		
Rev.	Date	Description

FIDANZA'S FAMILY HOUSE
NEW CONSTRUCTION
11041 SW 77TH AVE, PINECREST, FL 33156

Corporation Licence
#AA0003589
Architectural Seal
JORGE L VILLAVICENCIO
NO. AR0012110

VILLA & ASSOCIATES INC.
ARCHITECTURE - PLANNING - INTERIOR DESIGN
5801 SW 69 AVENUE - MIAMI, FLORIDA 33155
TEL. 305-613-0865 - E-Mail: Jvillarchitect@gmail.com
CONSULTANT : ARCHI-TEK STUDIO CORP.
TEL. 305-799-8016 - E-Mail: maguilar@architekstudio.com

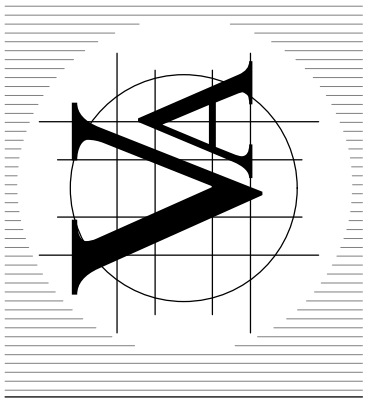

DATE: 10-20-2022	SCALE: AS SHOWN
PROJECT NO: Unnamed	
DRAWING NO: P-0-1	