


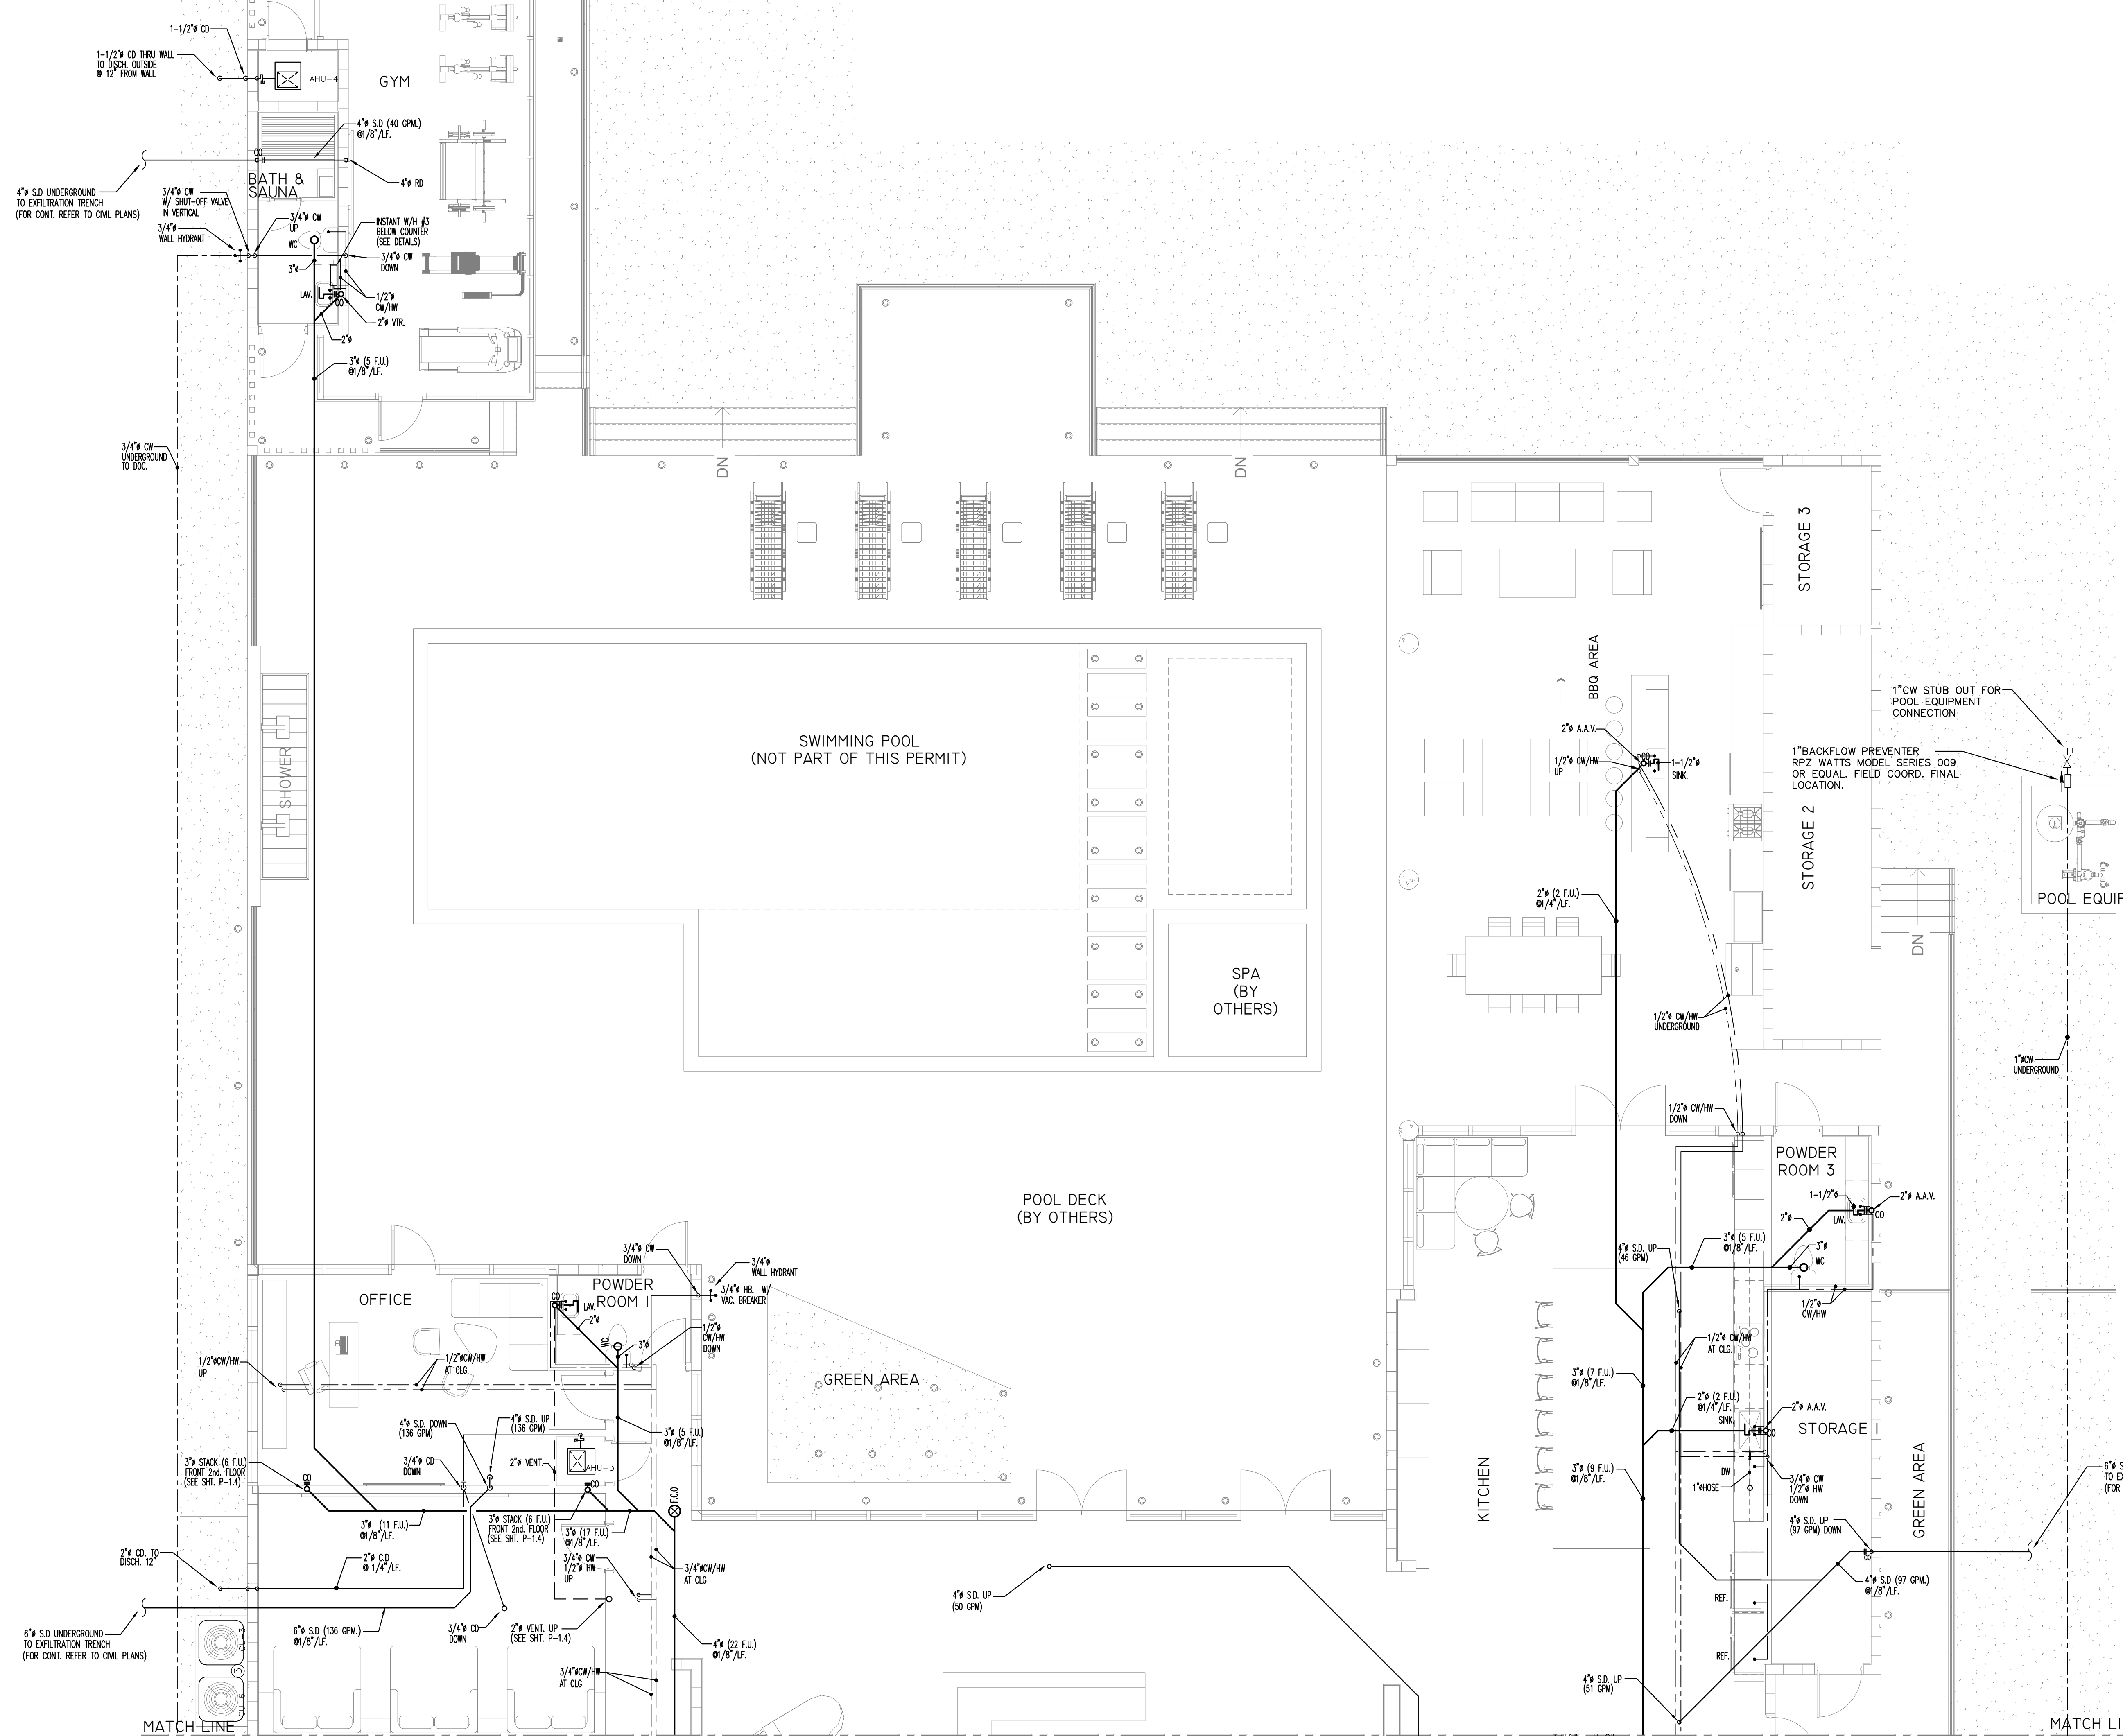

PLUMBING GROUND FLOOR PLAN
3/16" = 1'-0"

Eduardo A Barreto
Digitally signed by Eduardo A Barreto
DN: c=US, ou=Florida, dnQualifier=A0410C000018984F54FC0000D5C, cn=Eduardo A Barreto
Date: 2023.08.30 22:50:47 -0500

EDUARDO A. BARRETO
P.E. No. 69677
PH: (786) 239-1808
EMAIL: eabsservices@gmail.com

EDUARDO A. BARRETO, PROFESSIONAL ENGINEER,
STATE OF FLORIDA, LICENSE NO. 69677
THIS ITEM HAS BEEN DIGITALLY SIGNED AND SEALED
BY EDUARDO A. BARRETO, PE, ON DAY AS APPEAR
ON SEAL.
PRINTED COPIES OF THIS DOCUMENT ARE NOT
CONSIDERED SIGNED AND SEALED AND THE
SIGNATURE MUST BE VERIFIED ON ANY ELECTRONIC
COPIES.


REVISIONS	
Rev.	Description

FIDANZA'S FAMILY HOUSE
NEW CONSTRUCTION
11041 SW 77TH AVE, PINECREST, FL 33156

Corporation Licence
#AA0003589
Architectural Seal
JORGE L VILLAVICENCIO
INC. AR012110

VILLA & ASSOCIATES INC.
ARCHITECTURE - PLANNING - INTERIOR DESIGN
5801 SW 69 AVENUE - MIAMI, FLORIDA 33155
TEL. 305-613-0865 - E-Mail: jvillarchitect@gmail.com

CONSULTANT : ARCHI-TEK STUDIO CORP.
TEL. 305-799-8016 - E-Mail: maquilar@architekstudio.com

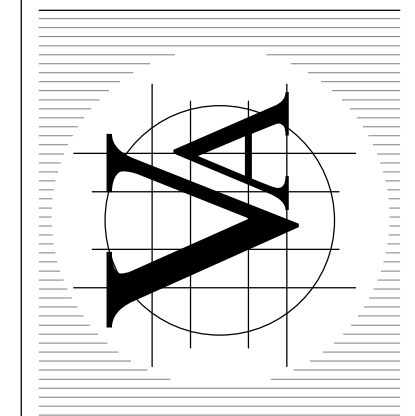

DATE: 10-20-2022	SCALE: AS SHOWN
PROJECT NO: Unnamed	DRAWING NO: P-1-1