


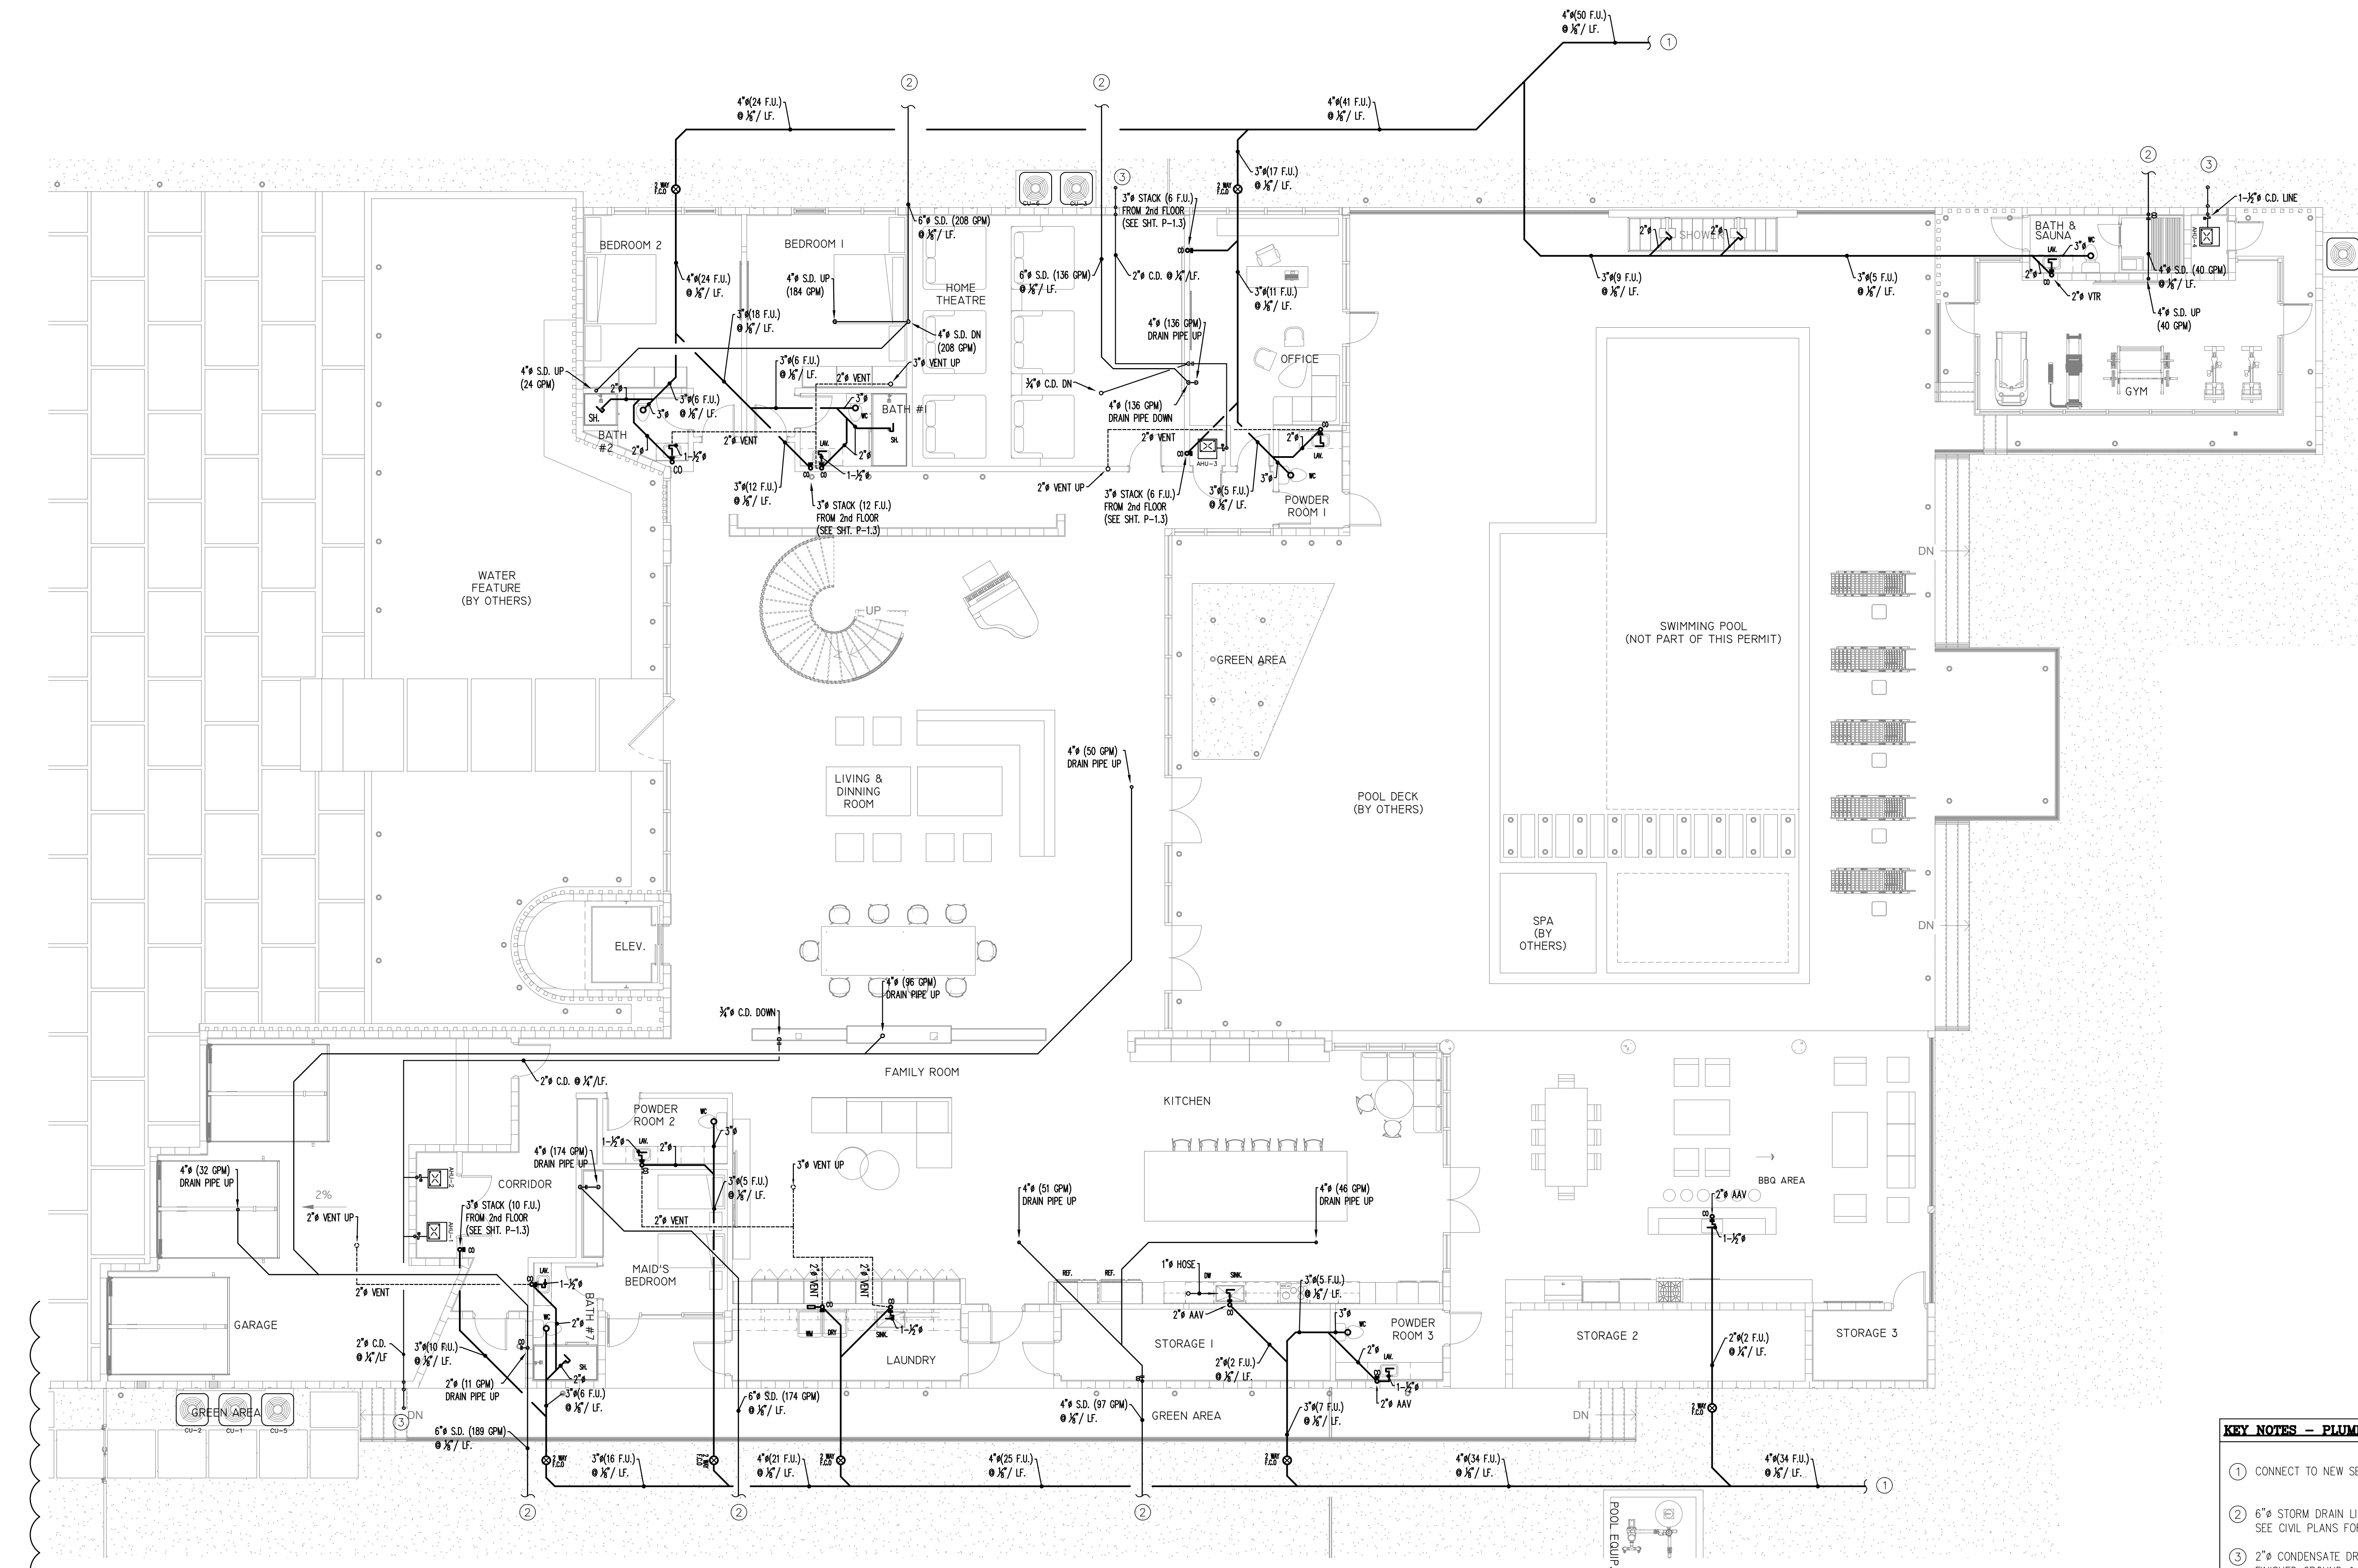

- KEY NOTES – PLUMBING**
- 1 CONNECT TO NEW SEPTIC TANK SYSTEM (BY OTHERS)
 - 2 6" S.D. STORM DRAIN LINE UNDERGROUND TO EXFILTRATION TRENCH. SEE CIVIL PLANS FOR CONTINUATION.
 - 3 2" CONDENSATE DRAIN WITH GOOSENECK TO TERMINATE 6" ABOVE FINISHED GROUND & 12" AWAY FROM WALL.

Eduardo A Barreto
P.E. No. 69677
PH: (786) 239-1808
EMAIL: eabsservices@gmail.com

EDUARDO A. BARRETO, PROFESSIONAL ENGINEER,
STATE OF FLORIDA, LICENSE NO. 69677
THIS ITEM HAS BEEN DIGITALLY SIGNED AND SEALED
BY EDUARDO A. BARRETO, PE, ON DAY AS APPEAR
ON SEAL.
PRINTED COPIES OF THIS DOCUMENT ARE NOT
CONSIDERED SIGNED AND SEALED AND THE
SIGNATURE MUST BE VERIFIED ON ANY ELECTRONIC
COPIES.


PLUMBING GROUND FLOOR - SANITARY PLAN
1/8" = 1'-0"

REVISIONS	
Rev	Description
1	B.D.C.

FIDANZA'S FAMILY HOUSE
NEW CONSTRUCTION
11041 SW 77TH AVE, PINECREST, FL 33156

Corporation Licence
#A4003589
Architectural Seal
JORGE L VILLAVENCIO
NC AR001210

VILLA & ASSOCIATES INC.
ARCHITECTURE - PLANNING - INTERIOR DESIGN
5801 SW 69 AVENUE - MIAMI, FLORIDA 33155
TEL. 305-613-0865 - E-Mail Jvillarchitect@gmail.com
CONSULTANT : ARCHI-TEK STUDIO CORP.
TEL. 305-799-8016 - E-Mail maguilar@architekstudio.com

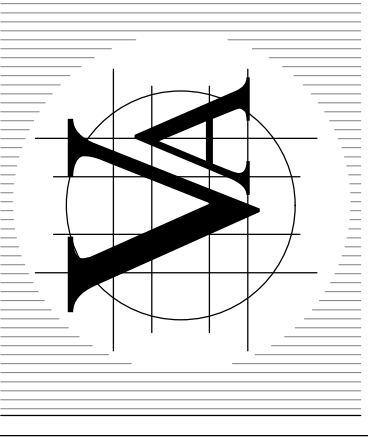

DATE: 10-20-2022	SCALE: AS SHOWN
PROJECT NO: Unnamed	
DRAWING NO: P-1-0	