


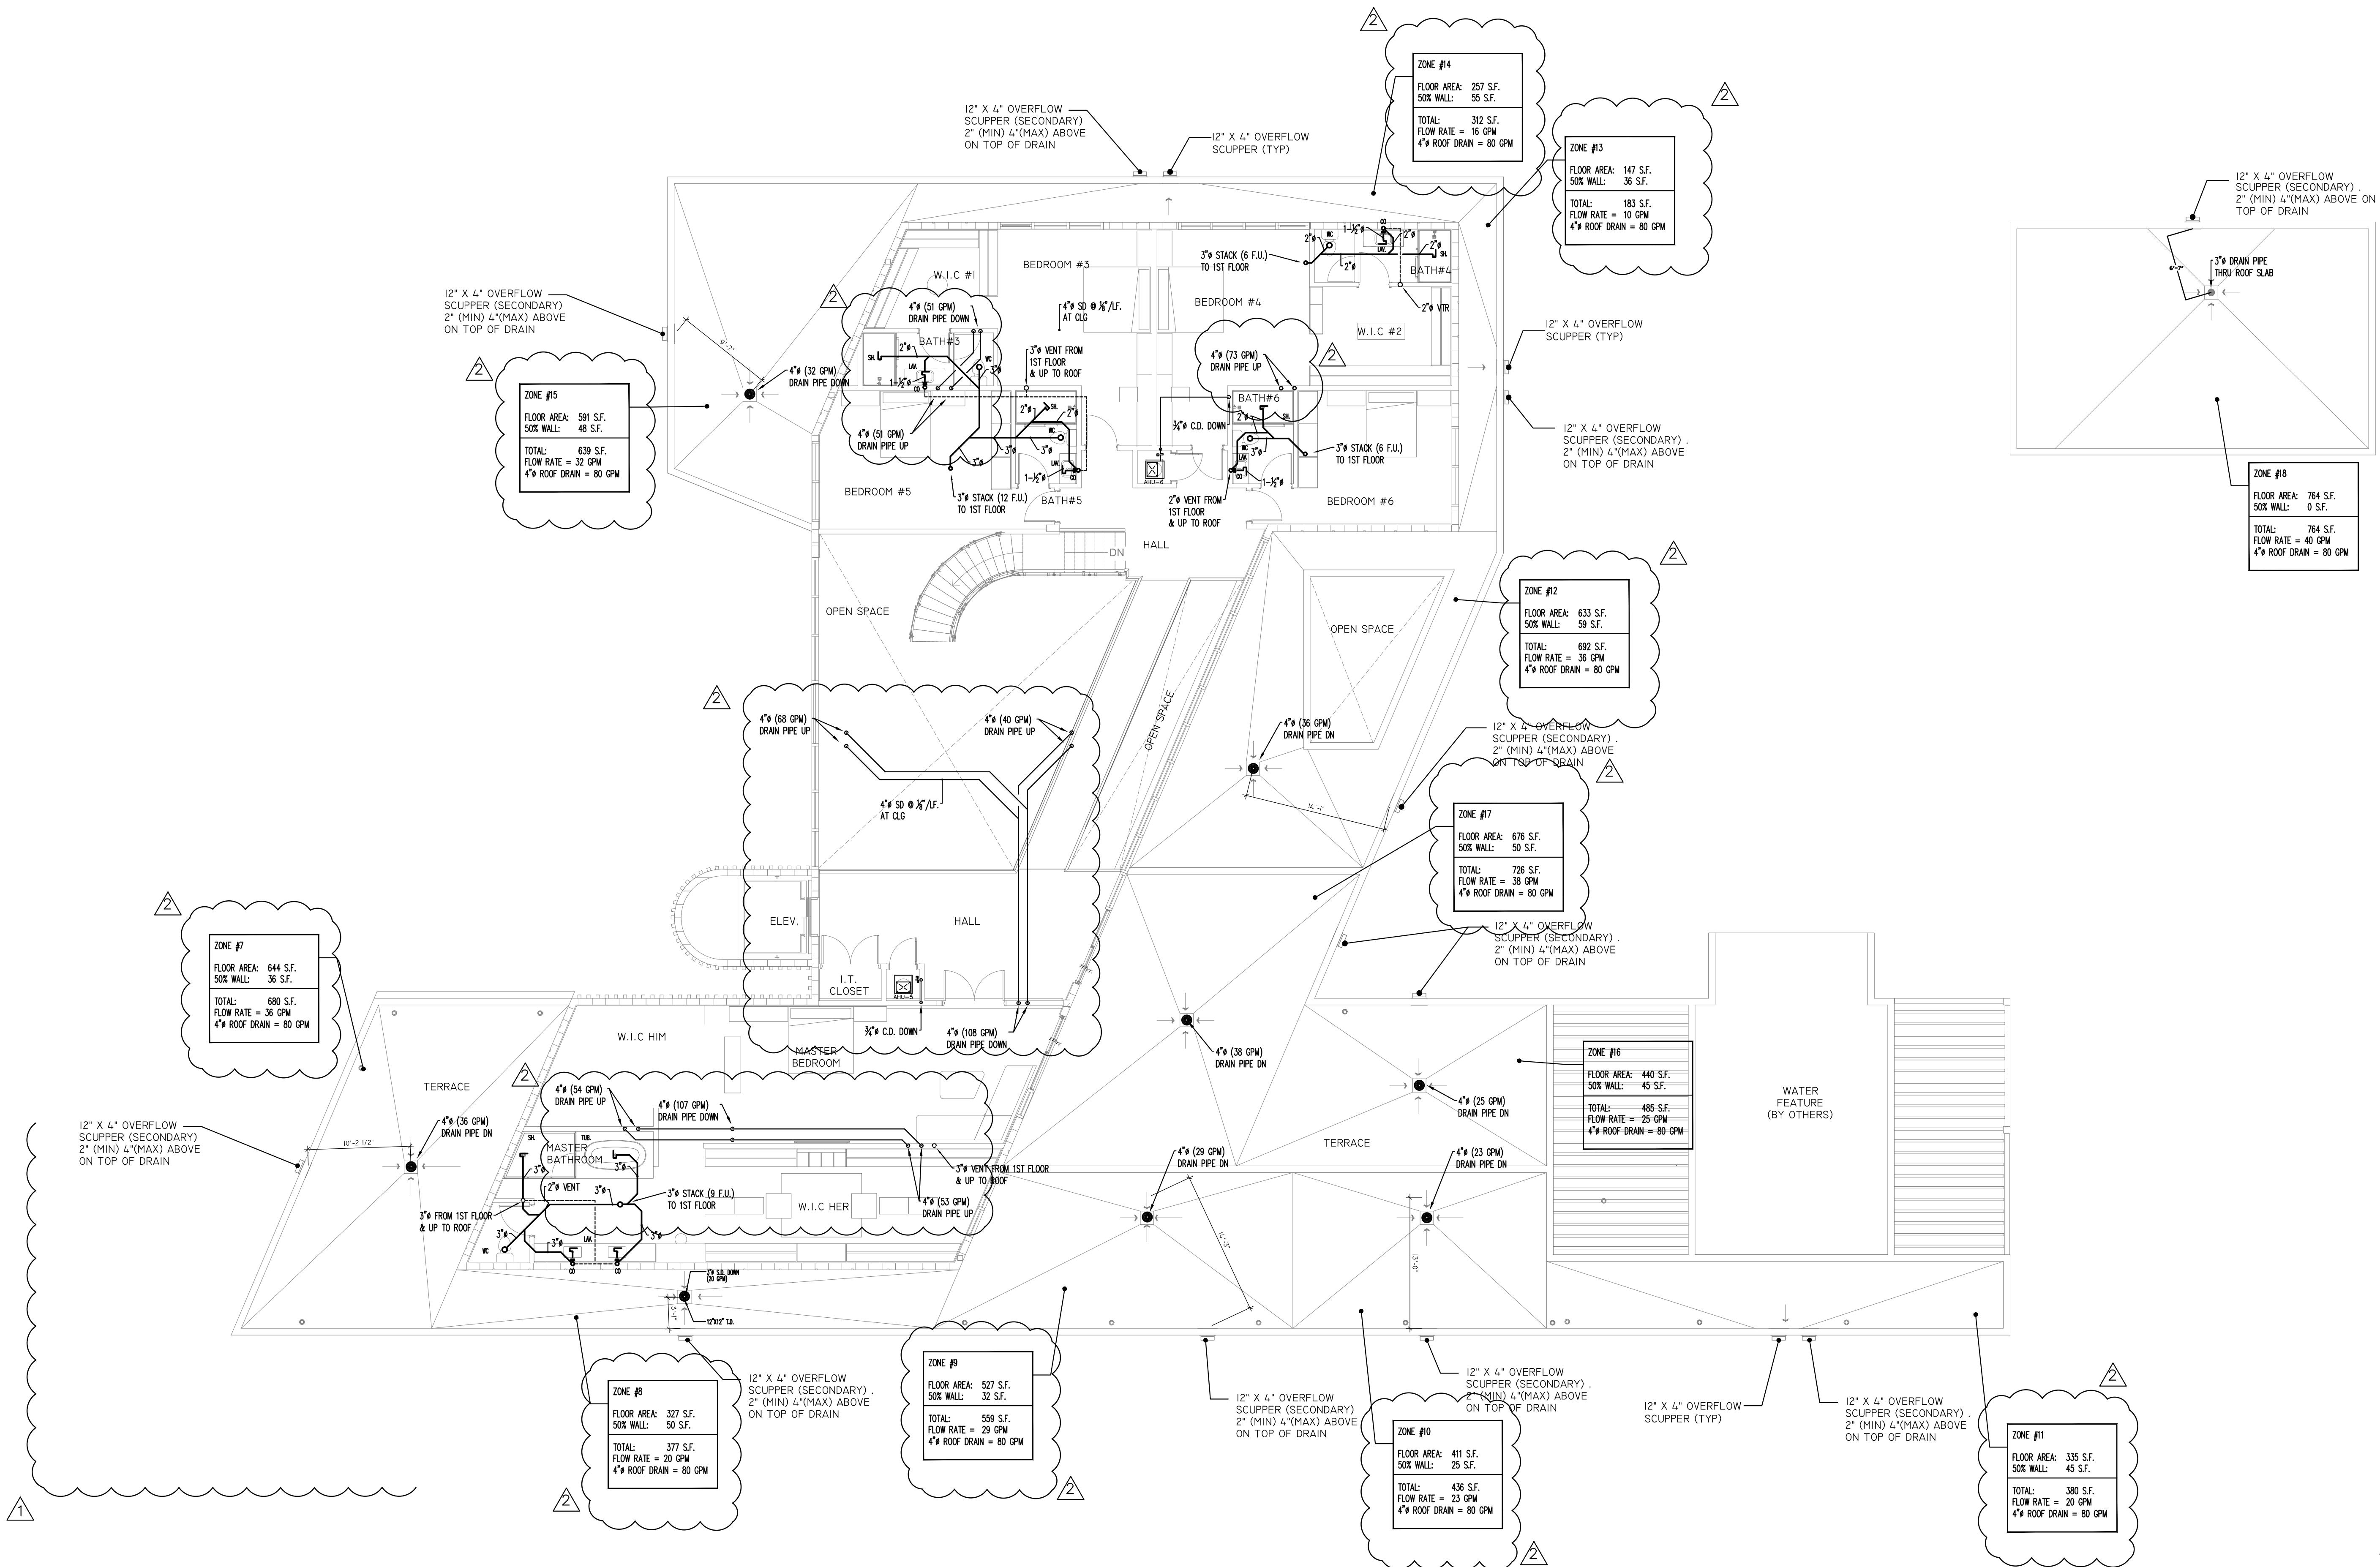


PLUMBING SECOND FLOOR - SANITARY PLAN
1/8" = 1'-0"

REVISIONS	
Rev.	Description
10/24/23	B.D.C
04/25/24	B.D.C

FIDANZA'S FAMILY HOUSE
NEW CONSTRUCTION
11041 SW 77TH AVE, PINECREST, FL 33156

Corporation Licence
#AA0003395
Architectural Seal
JORGE L VILLAVICENCIO
NO. AR0012110

VILLA & ASSOCIATES INC.
ARCHITECTURE - PLANNING - INTERIOR DESIGN
5801 SW 69 AVENUE - MIAMI, FLORIDA 33155
TEL. 305-613-0865 - E-Mail: jvillararchitect@gmail.com
CONSULTANT: ARCHI-TEK STUDIO CORP.
TEL. 305-799-8016 - E-Mail: maguilar@architekstudio.com

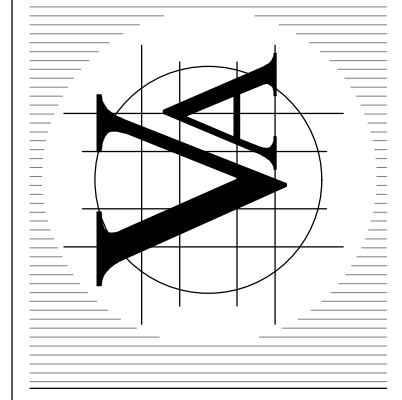

Eduardo A Barreto
P.E. No. 69677
PH: (786) 239-1808
EMAIL: eaboservices@gmail.com

EDUARDO A BARRETO, PROFESSIONAL ENGINEER,
STATE OF FLORIDA, LICENSE NO. 69677
THIS ITEM HAS BEEN DIGITALLY SIGNED AND SEALED
BY EDUARDO A BARRETO, PE, ON DAY AS APPEAR
ON SEAL.
PRINTED COPIES OF THIS DOCUMENT ARE NOT
CONSIDERED SIGNED AND SEALED AND THE
SIGNATURE MUST BE VERIFIED ON ANY ELECTRONIC
COPIES.

DATE: 10-20-2022	SCALE: AS SHOWN
PROJECT NO: Unnamed	
DRAWING NO : P-1-2	