


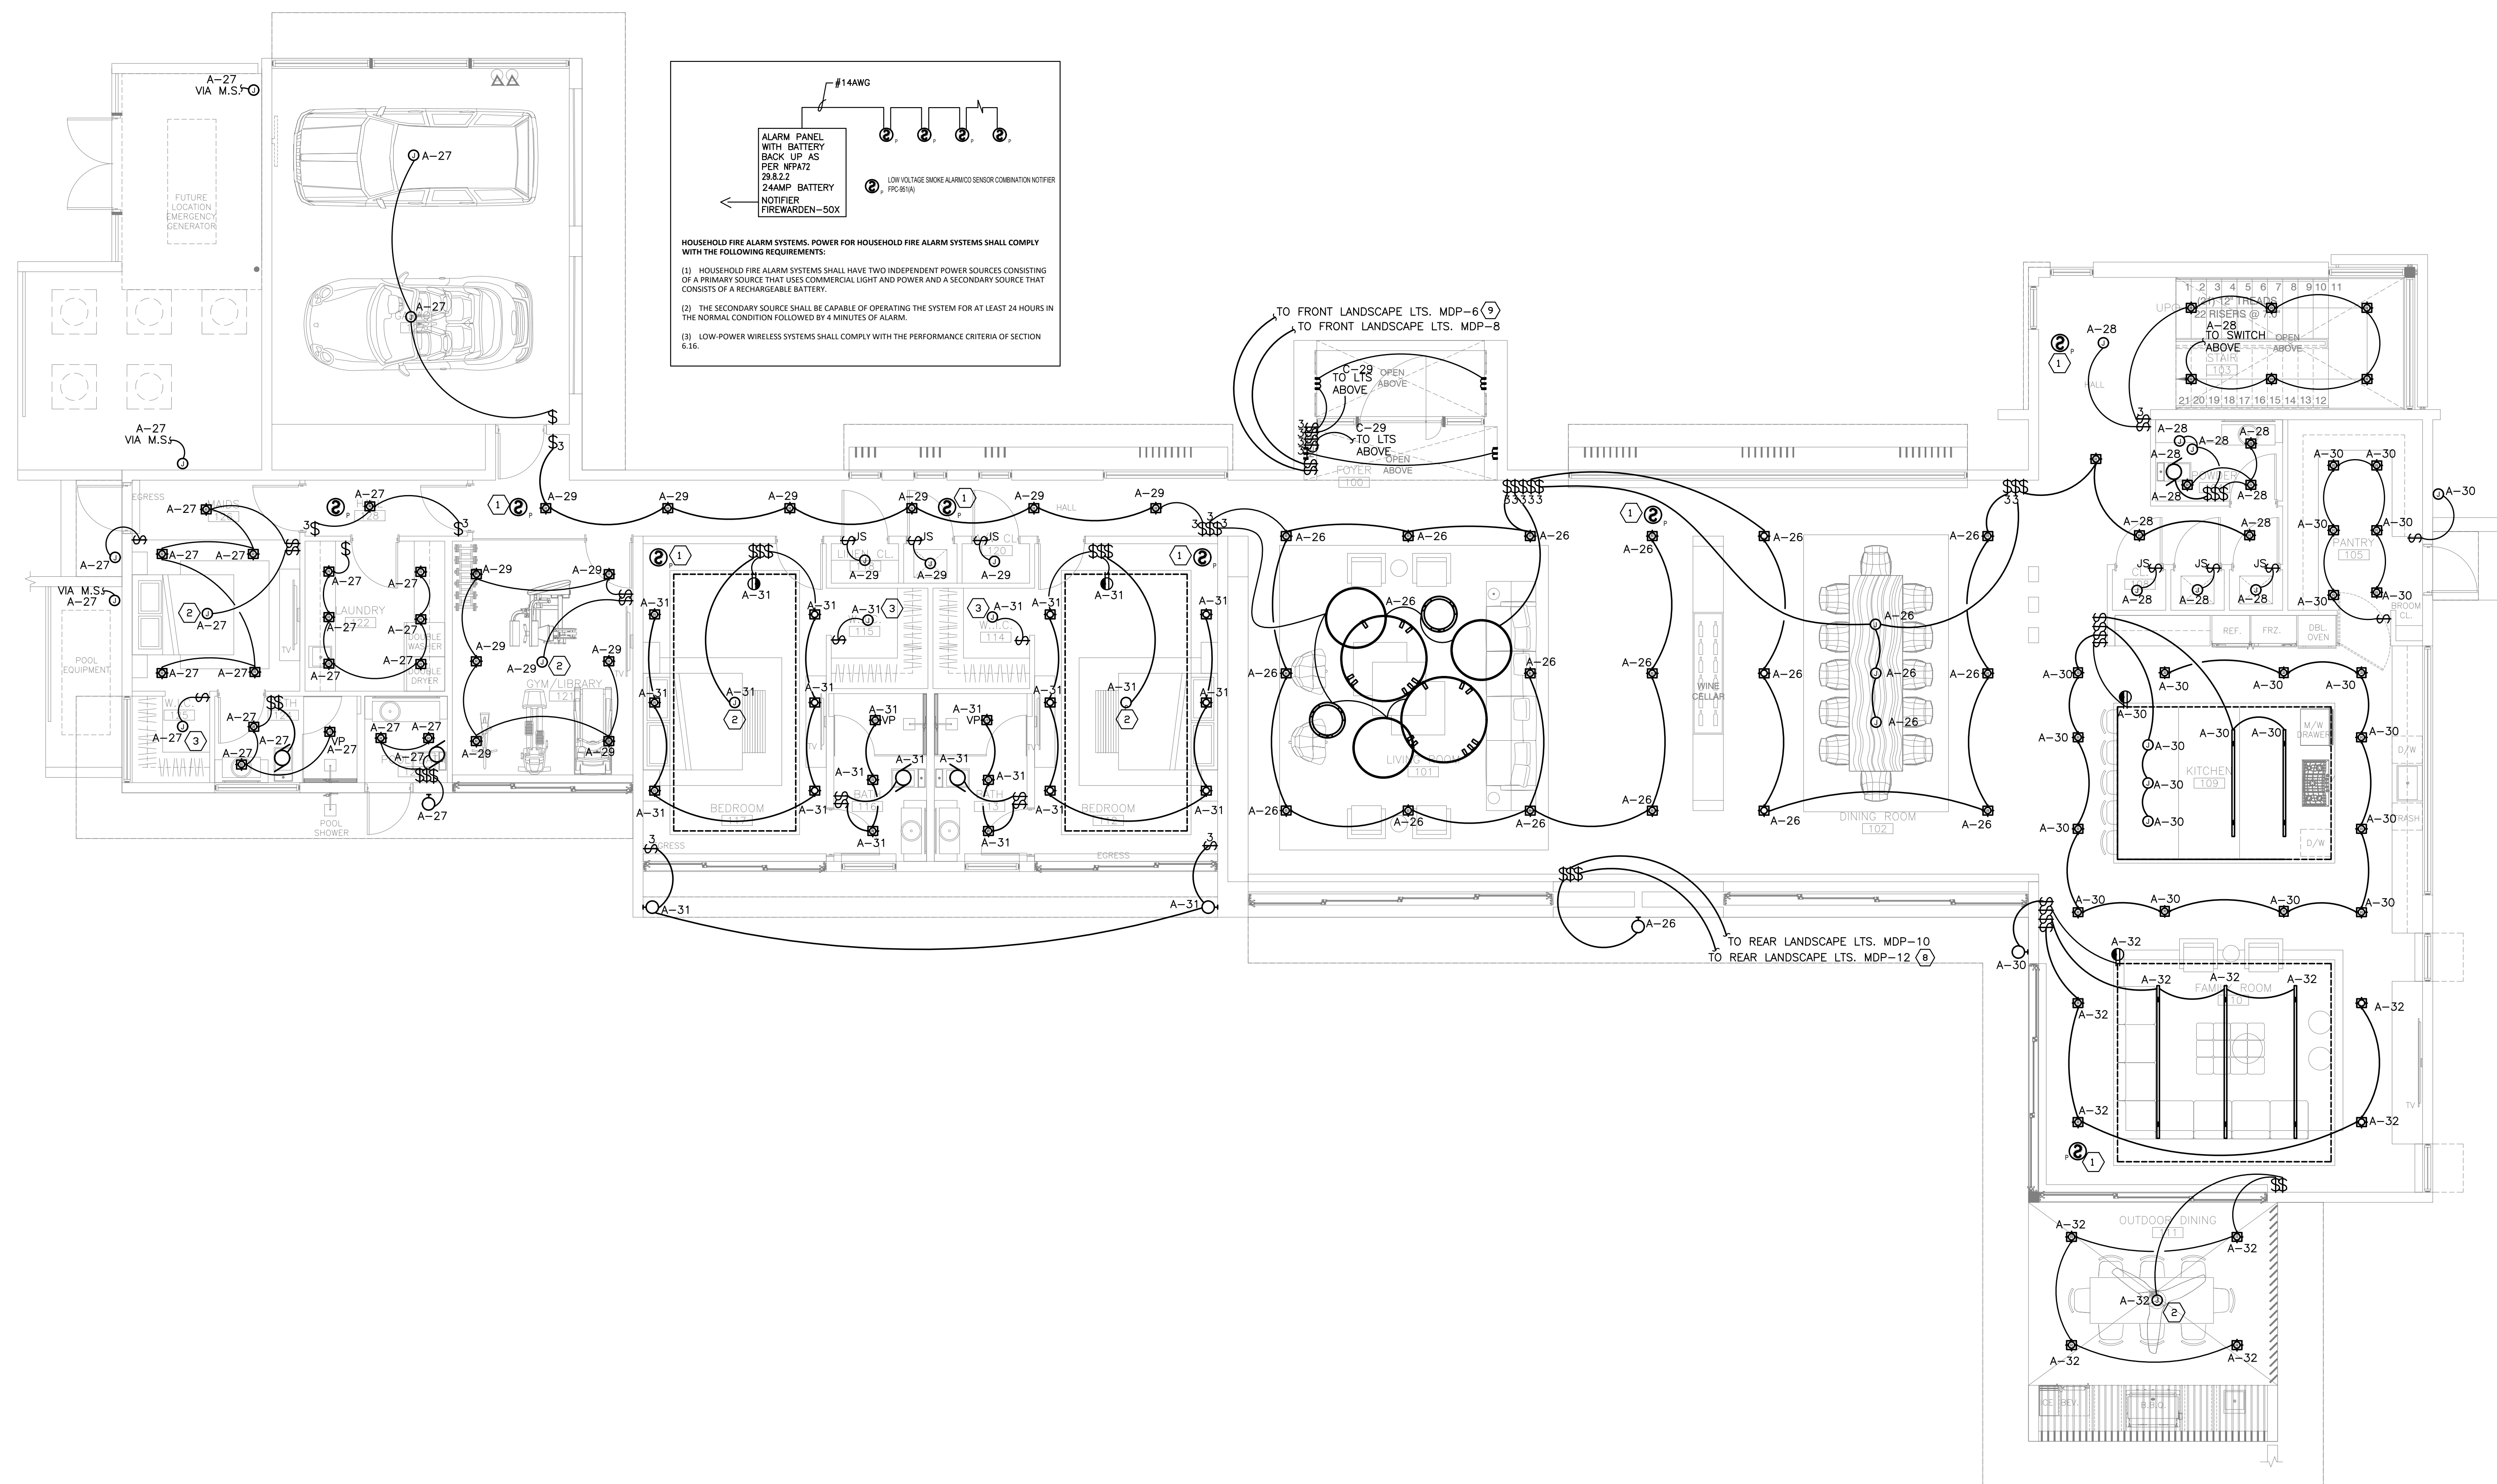

  **LIGHTING FIRST FLOOR PLAN**
SCALE: 3/16"=1'-0"