


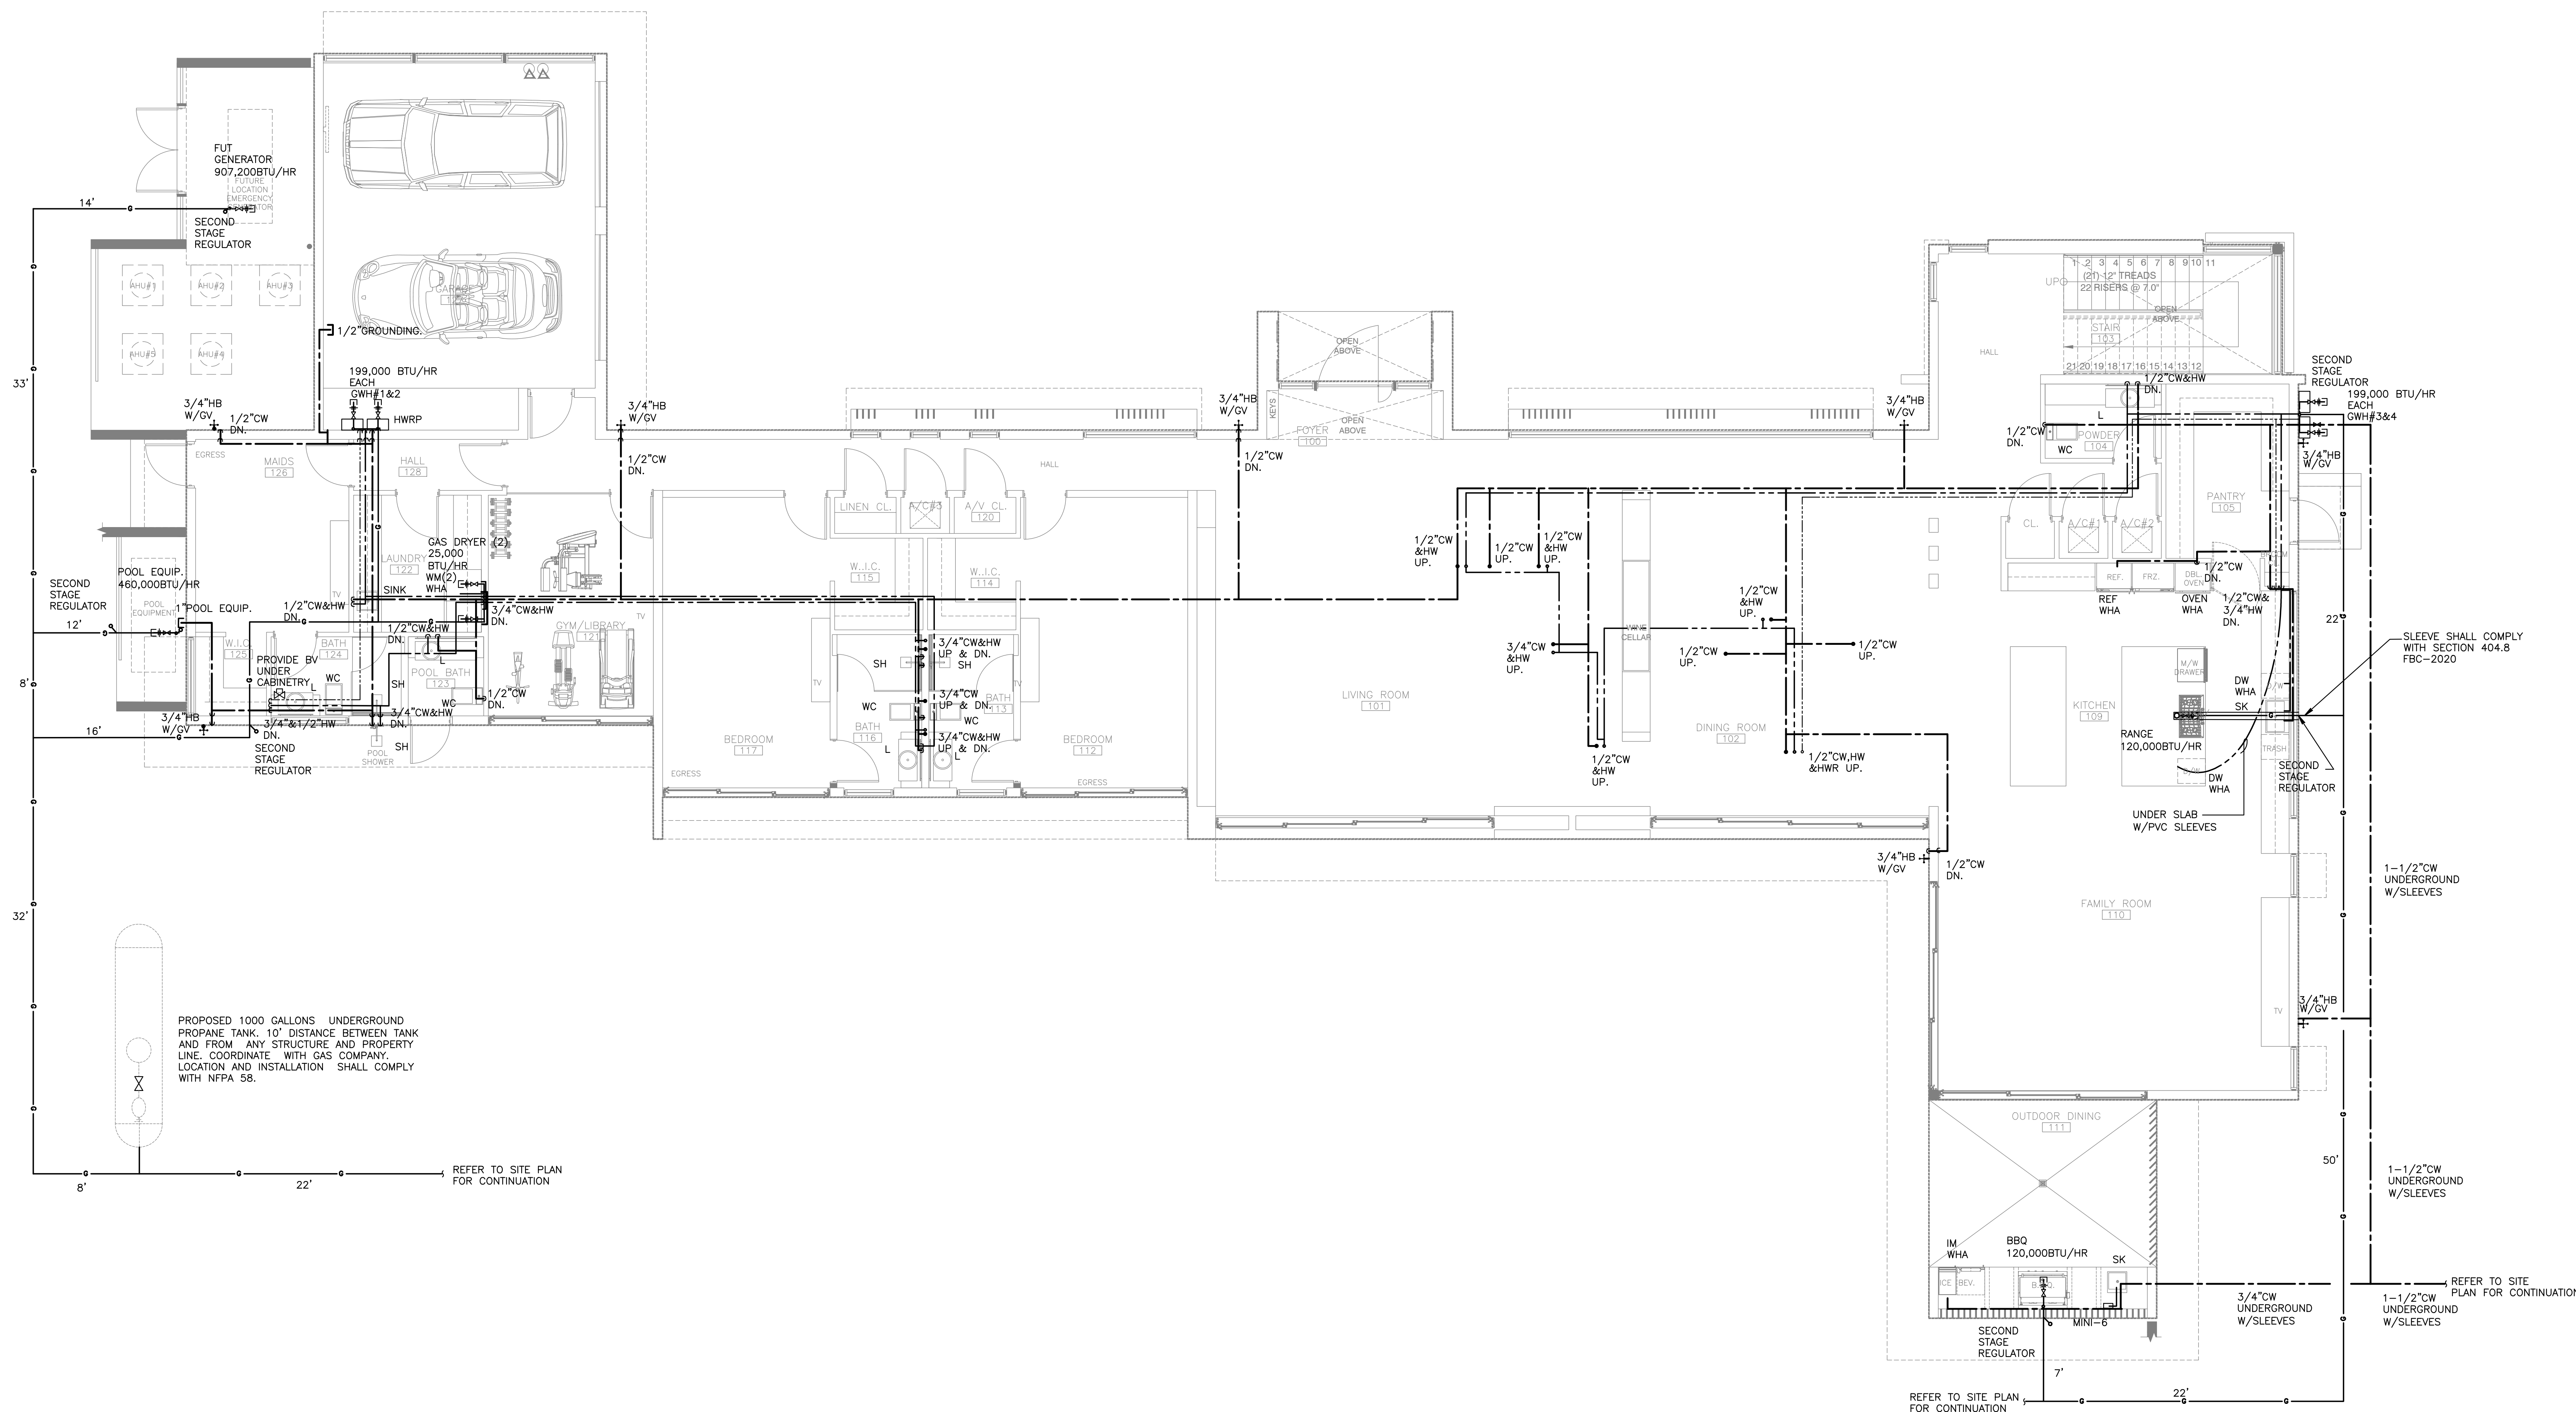

WATER & GAS FIRST FLOOR PLAN
SCALE: 3/16"=1'-0"

This item has been digitally signed and sealed by Amarilis Rodriguez, P.E. on the date adjacent to the seal. Printed copies of this document are not considered signed and sealed and the signature must be verified on any electronic copies.

JOB # 2103 Date: 2023.12.12
Signature: [Signature] Date: 16:04:47
License Number: 114296
Engineering Design
Mechanical - Electrical
Plumbing - Fire Protection
www.arpe-eng.com