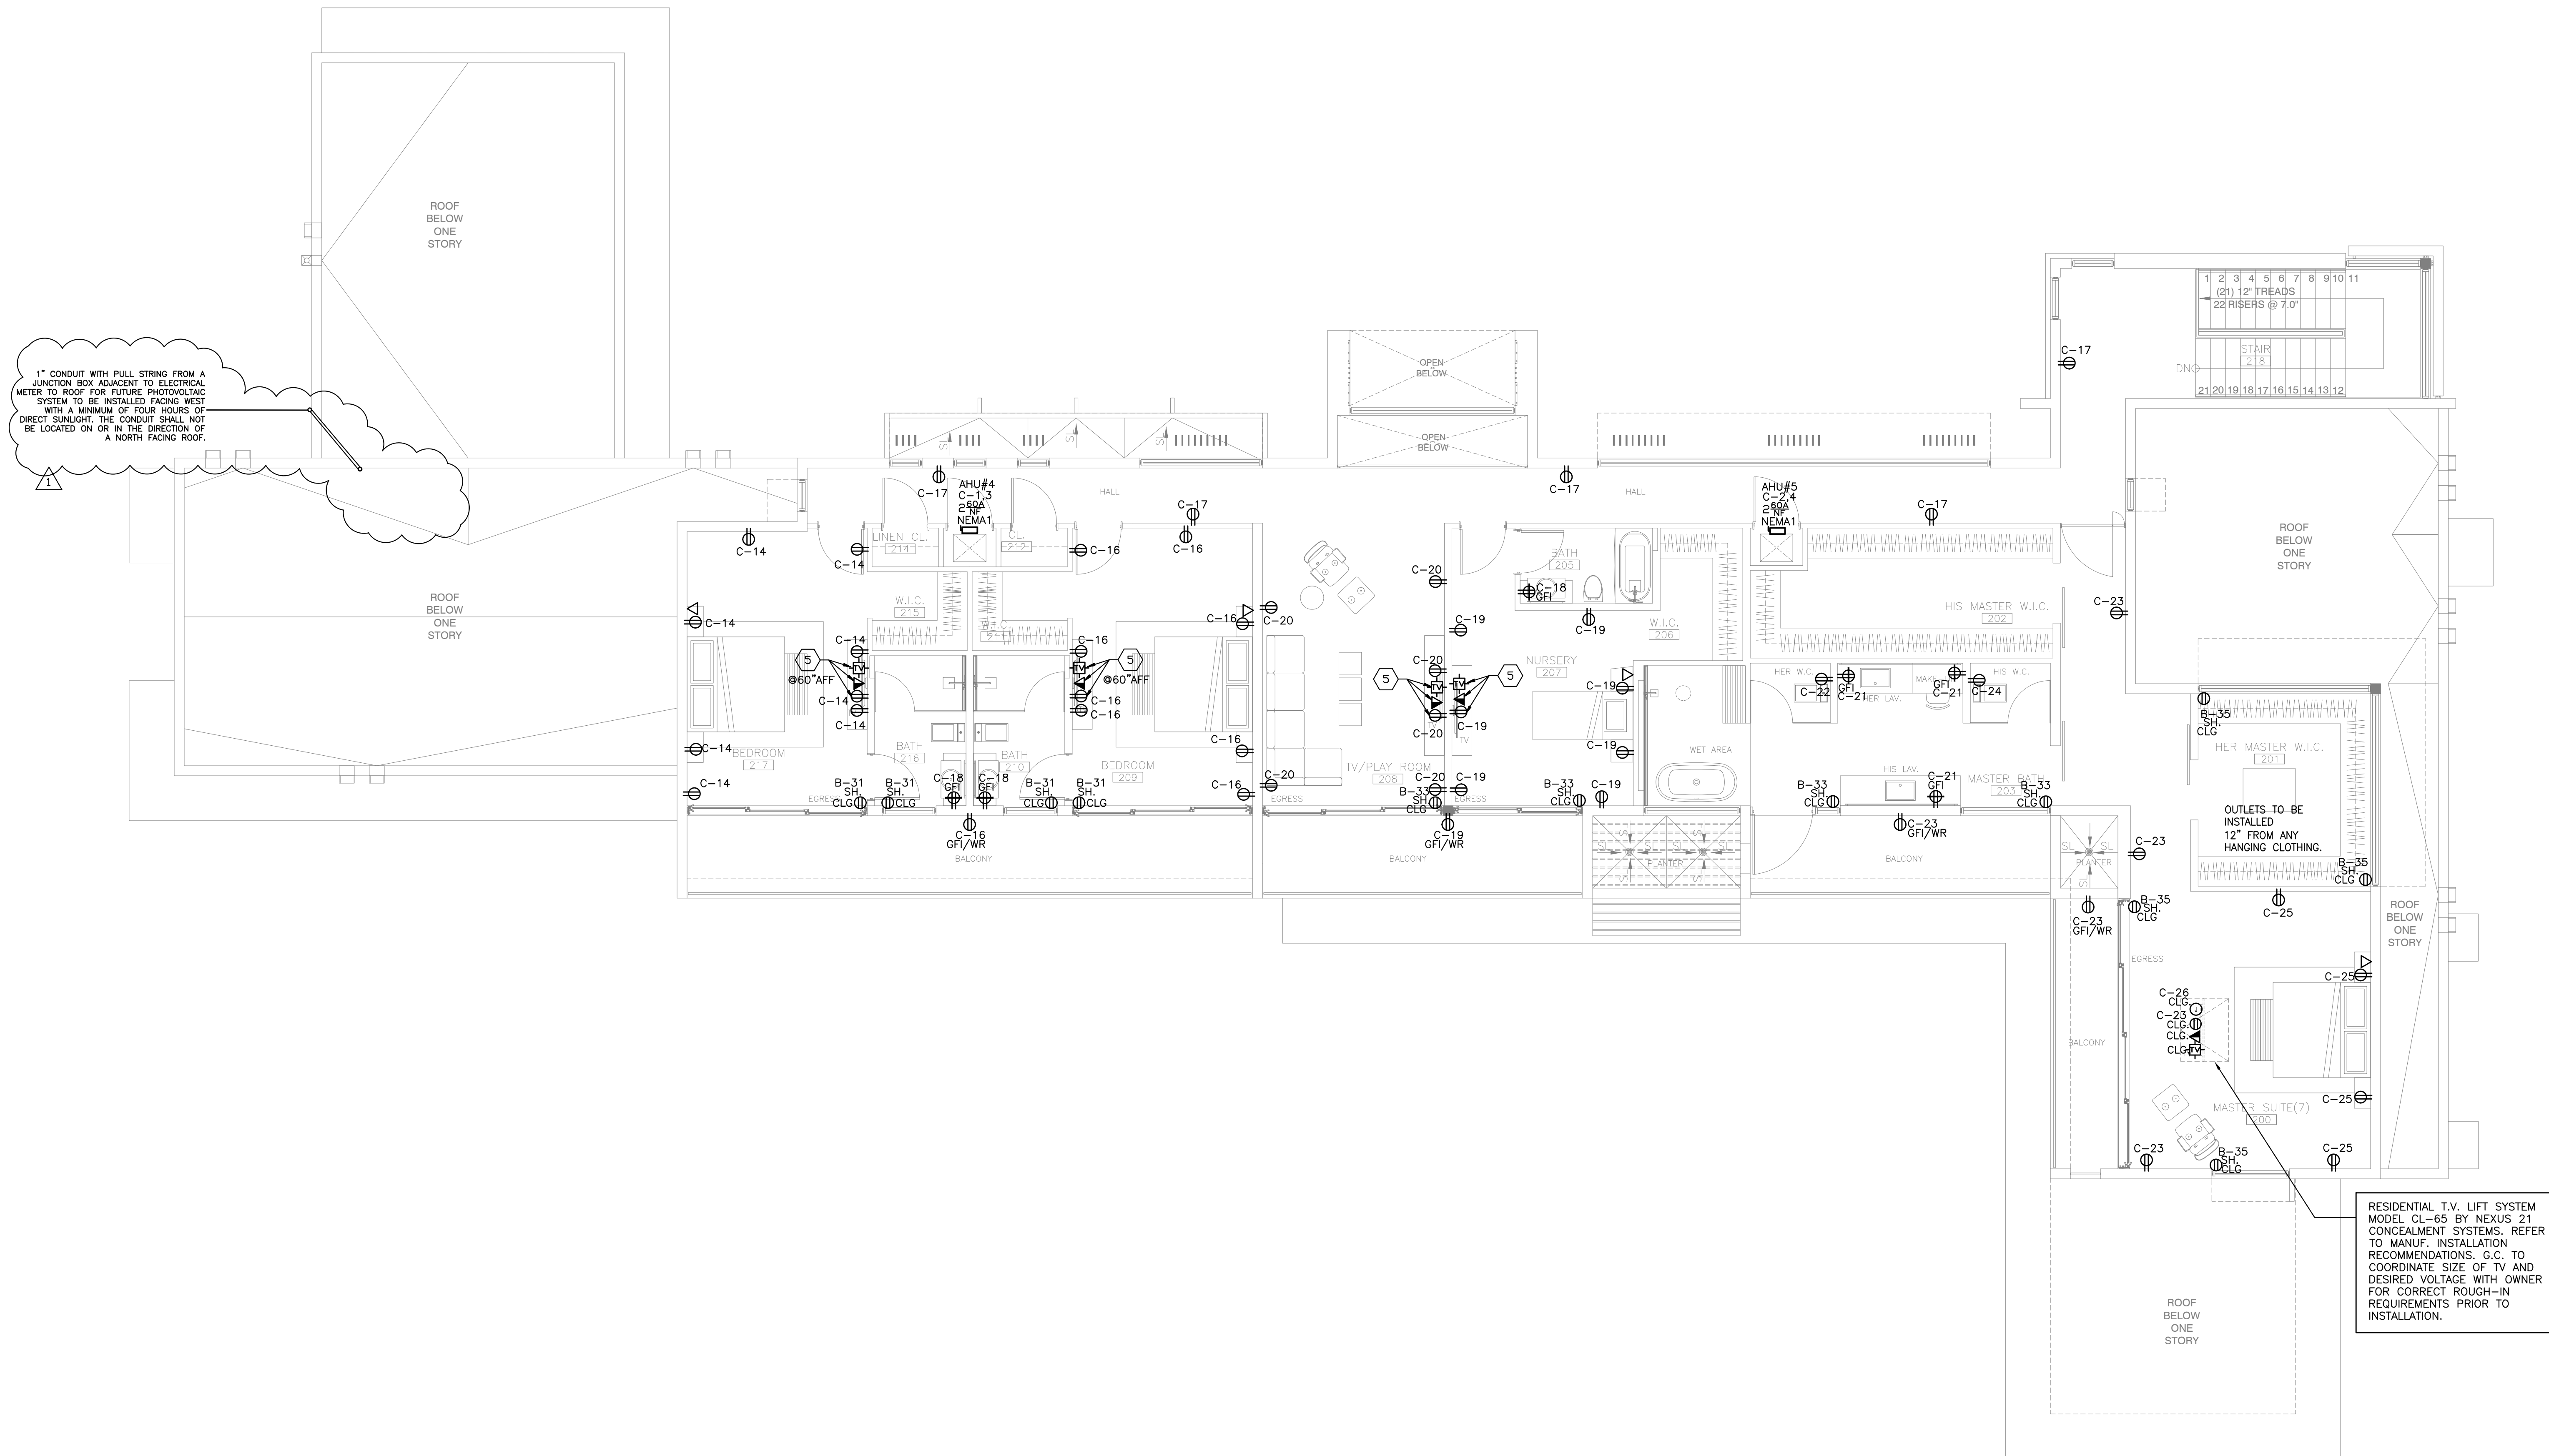
**POWER SECOND FLOOR PLAN**
SCALE: 3/16"=1'-0"

This item has been digitally signed and sealed by Amarilis Rodriguez, P.E. on the date adjacent to the seal.
Printed copies of this document are not considered signed and sealed and the signature must be verified
on any electronic copies.

arpe
Engineering inc
2020 Ponce de Leon Blvd., Suite 1002
Coral Gables, Florida 33134
Phone > 305.444.9809
Fax > 305.444.9827
www.arpe-eng.com

Amarilis Rodriguez, P.E.
License Number 2024.01.
30
Signature
Date 14:18:09
05/00