



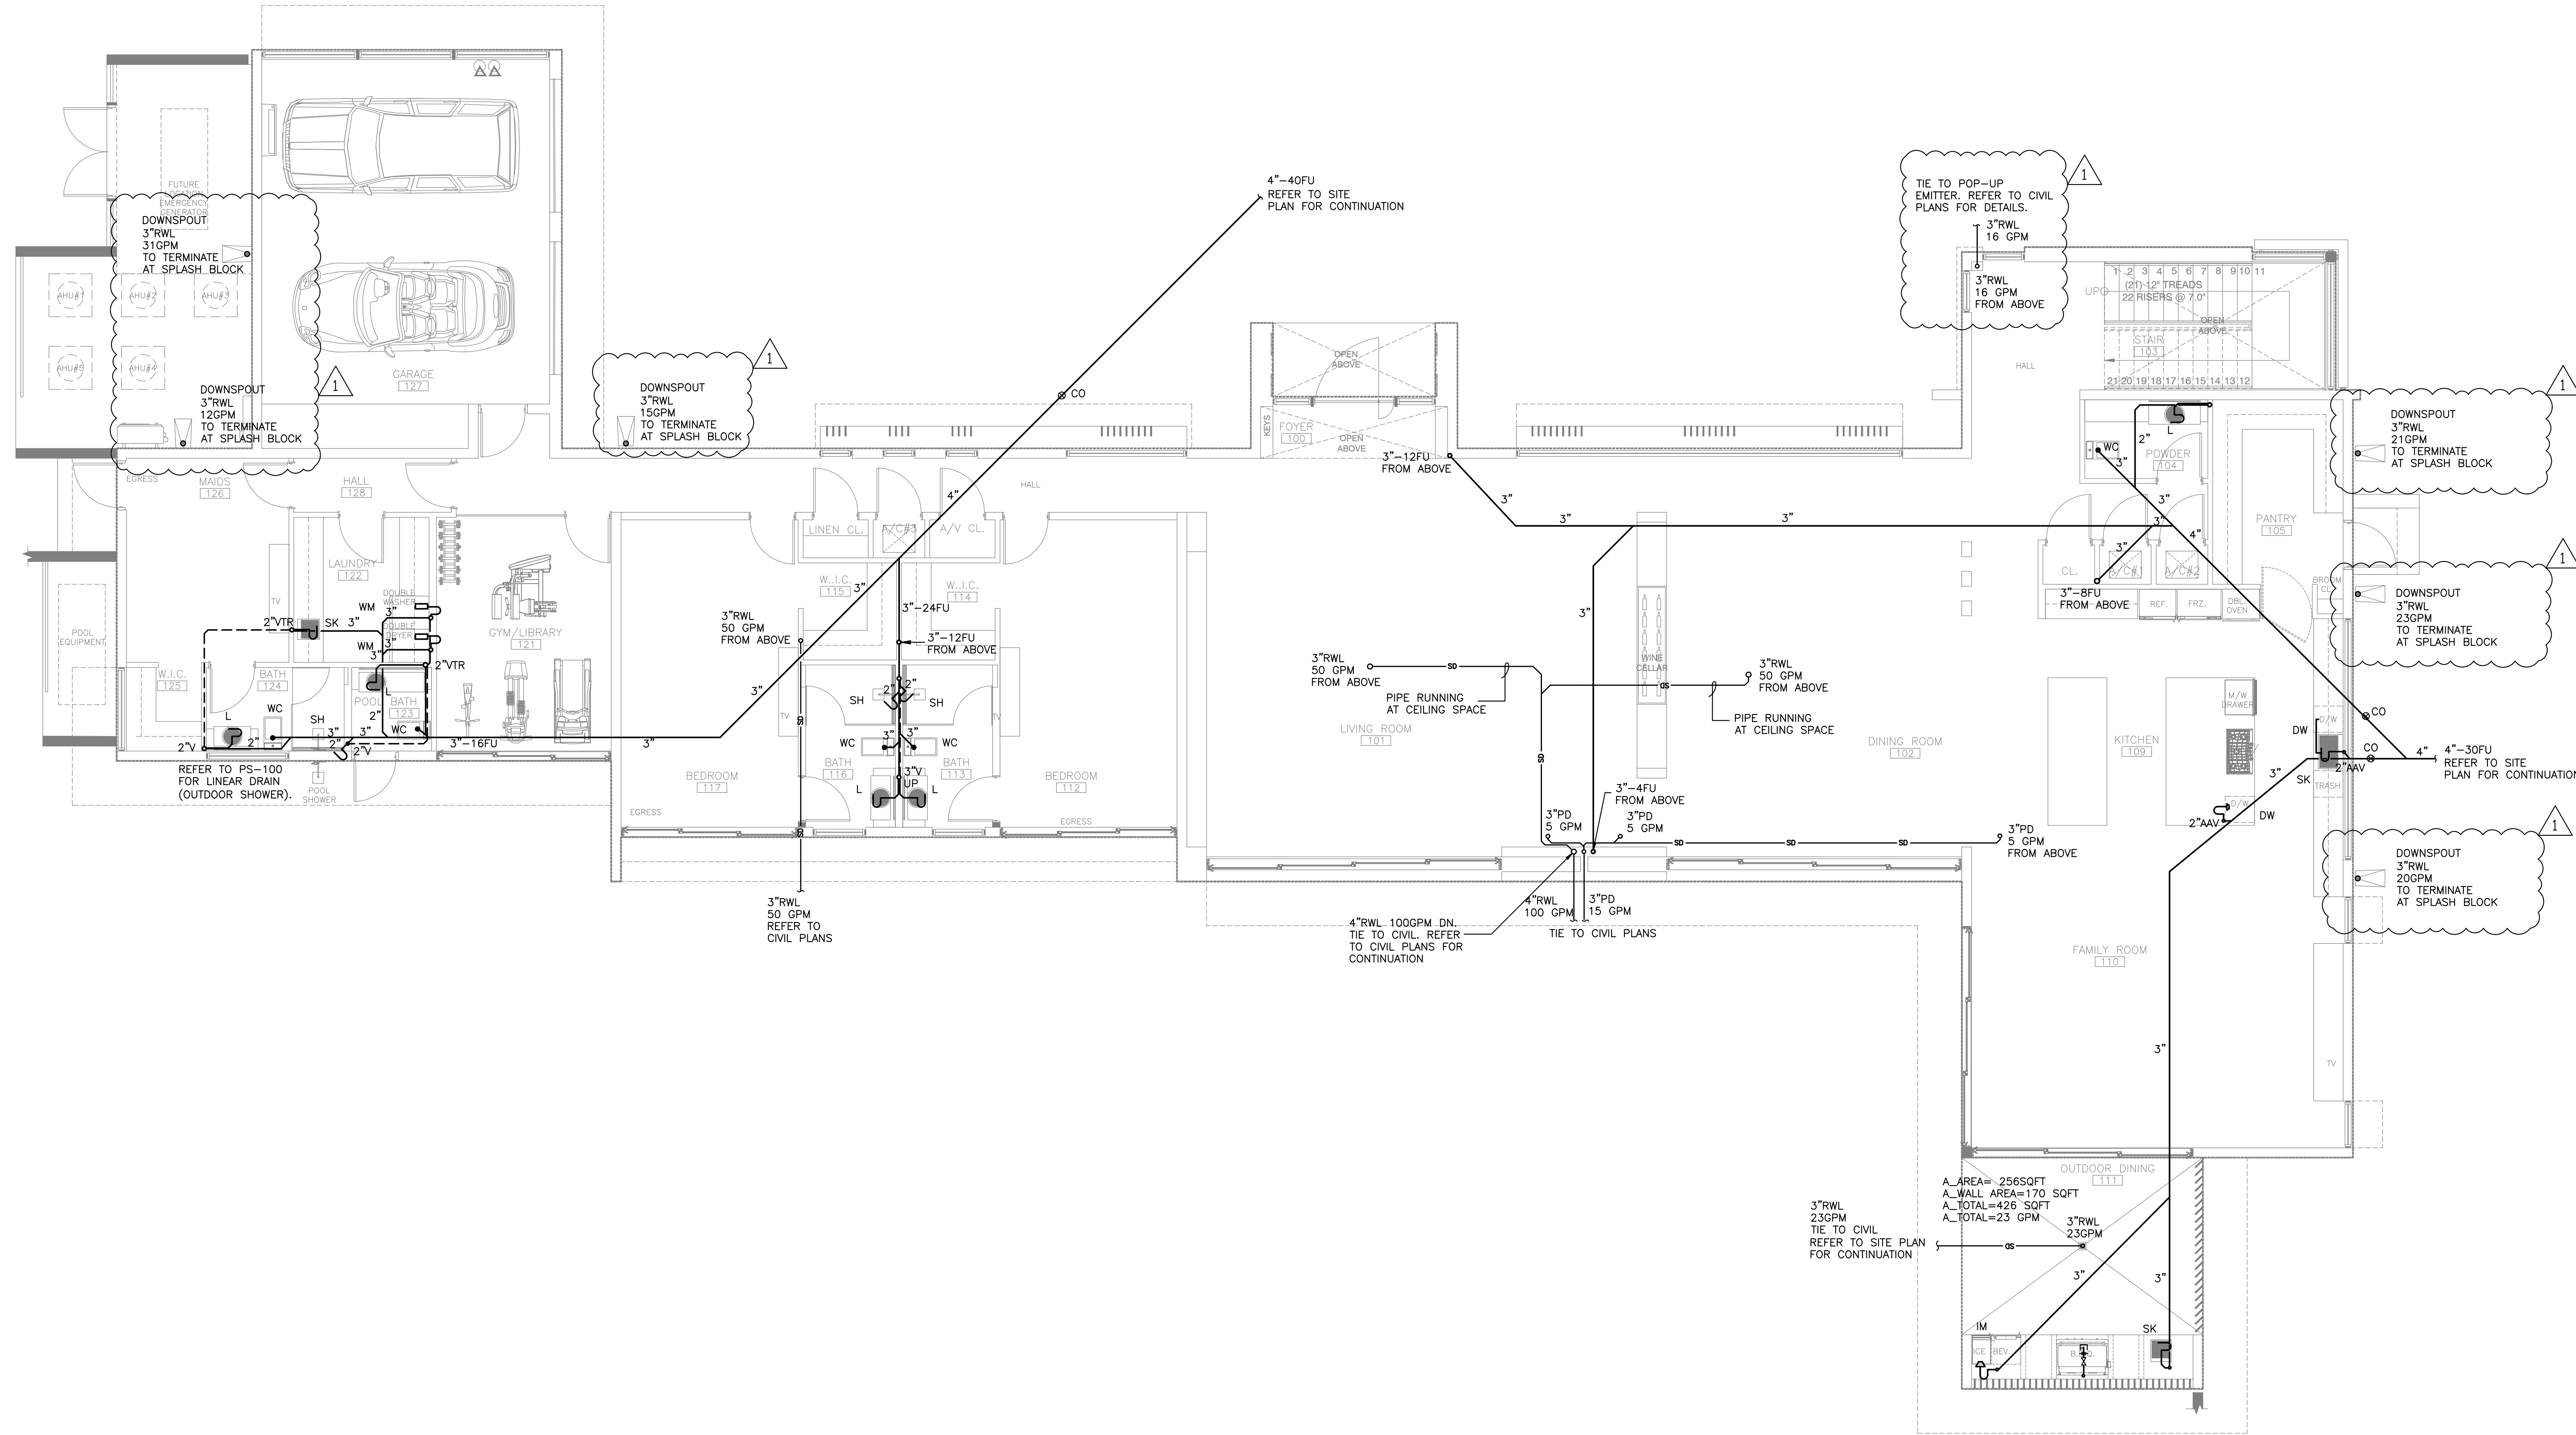

228 10'

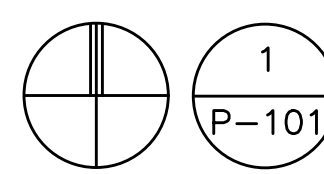

SANITARY FIRST FLOOR PLAN
SCALE: 3/16"=1'-0"

This item has been digitally signed and sealed by Amarilis Rodriguez, P.E. on the date adjacent to the seal. Printed copies of this document are not considered signed and sealed and the signature must be verified on any electronic copies.

JOB # 23-0822
Amarilis Rodriguez, P.E.
Date: 2024.01.30
Signature: [Signature]
Date: 14:16:07
-05'00'

arpe engineering inc
2020 Ponce de Leon Blvd., Suite 1002
Coral Gables, Florida 33134
Phone > 305 444 9809
Fax > 305 444 9827
www.arpe-eng.com

Engineering Design:
Mechanical > Electrical
Plumbing > Fire Protection