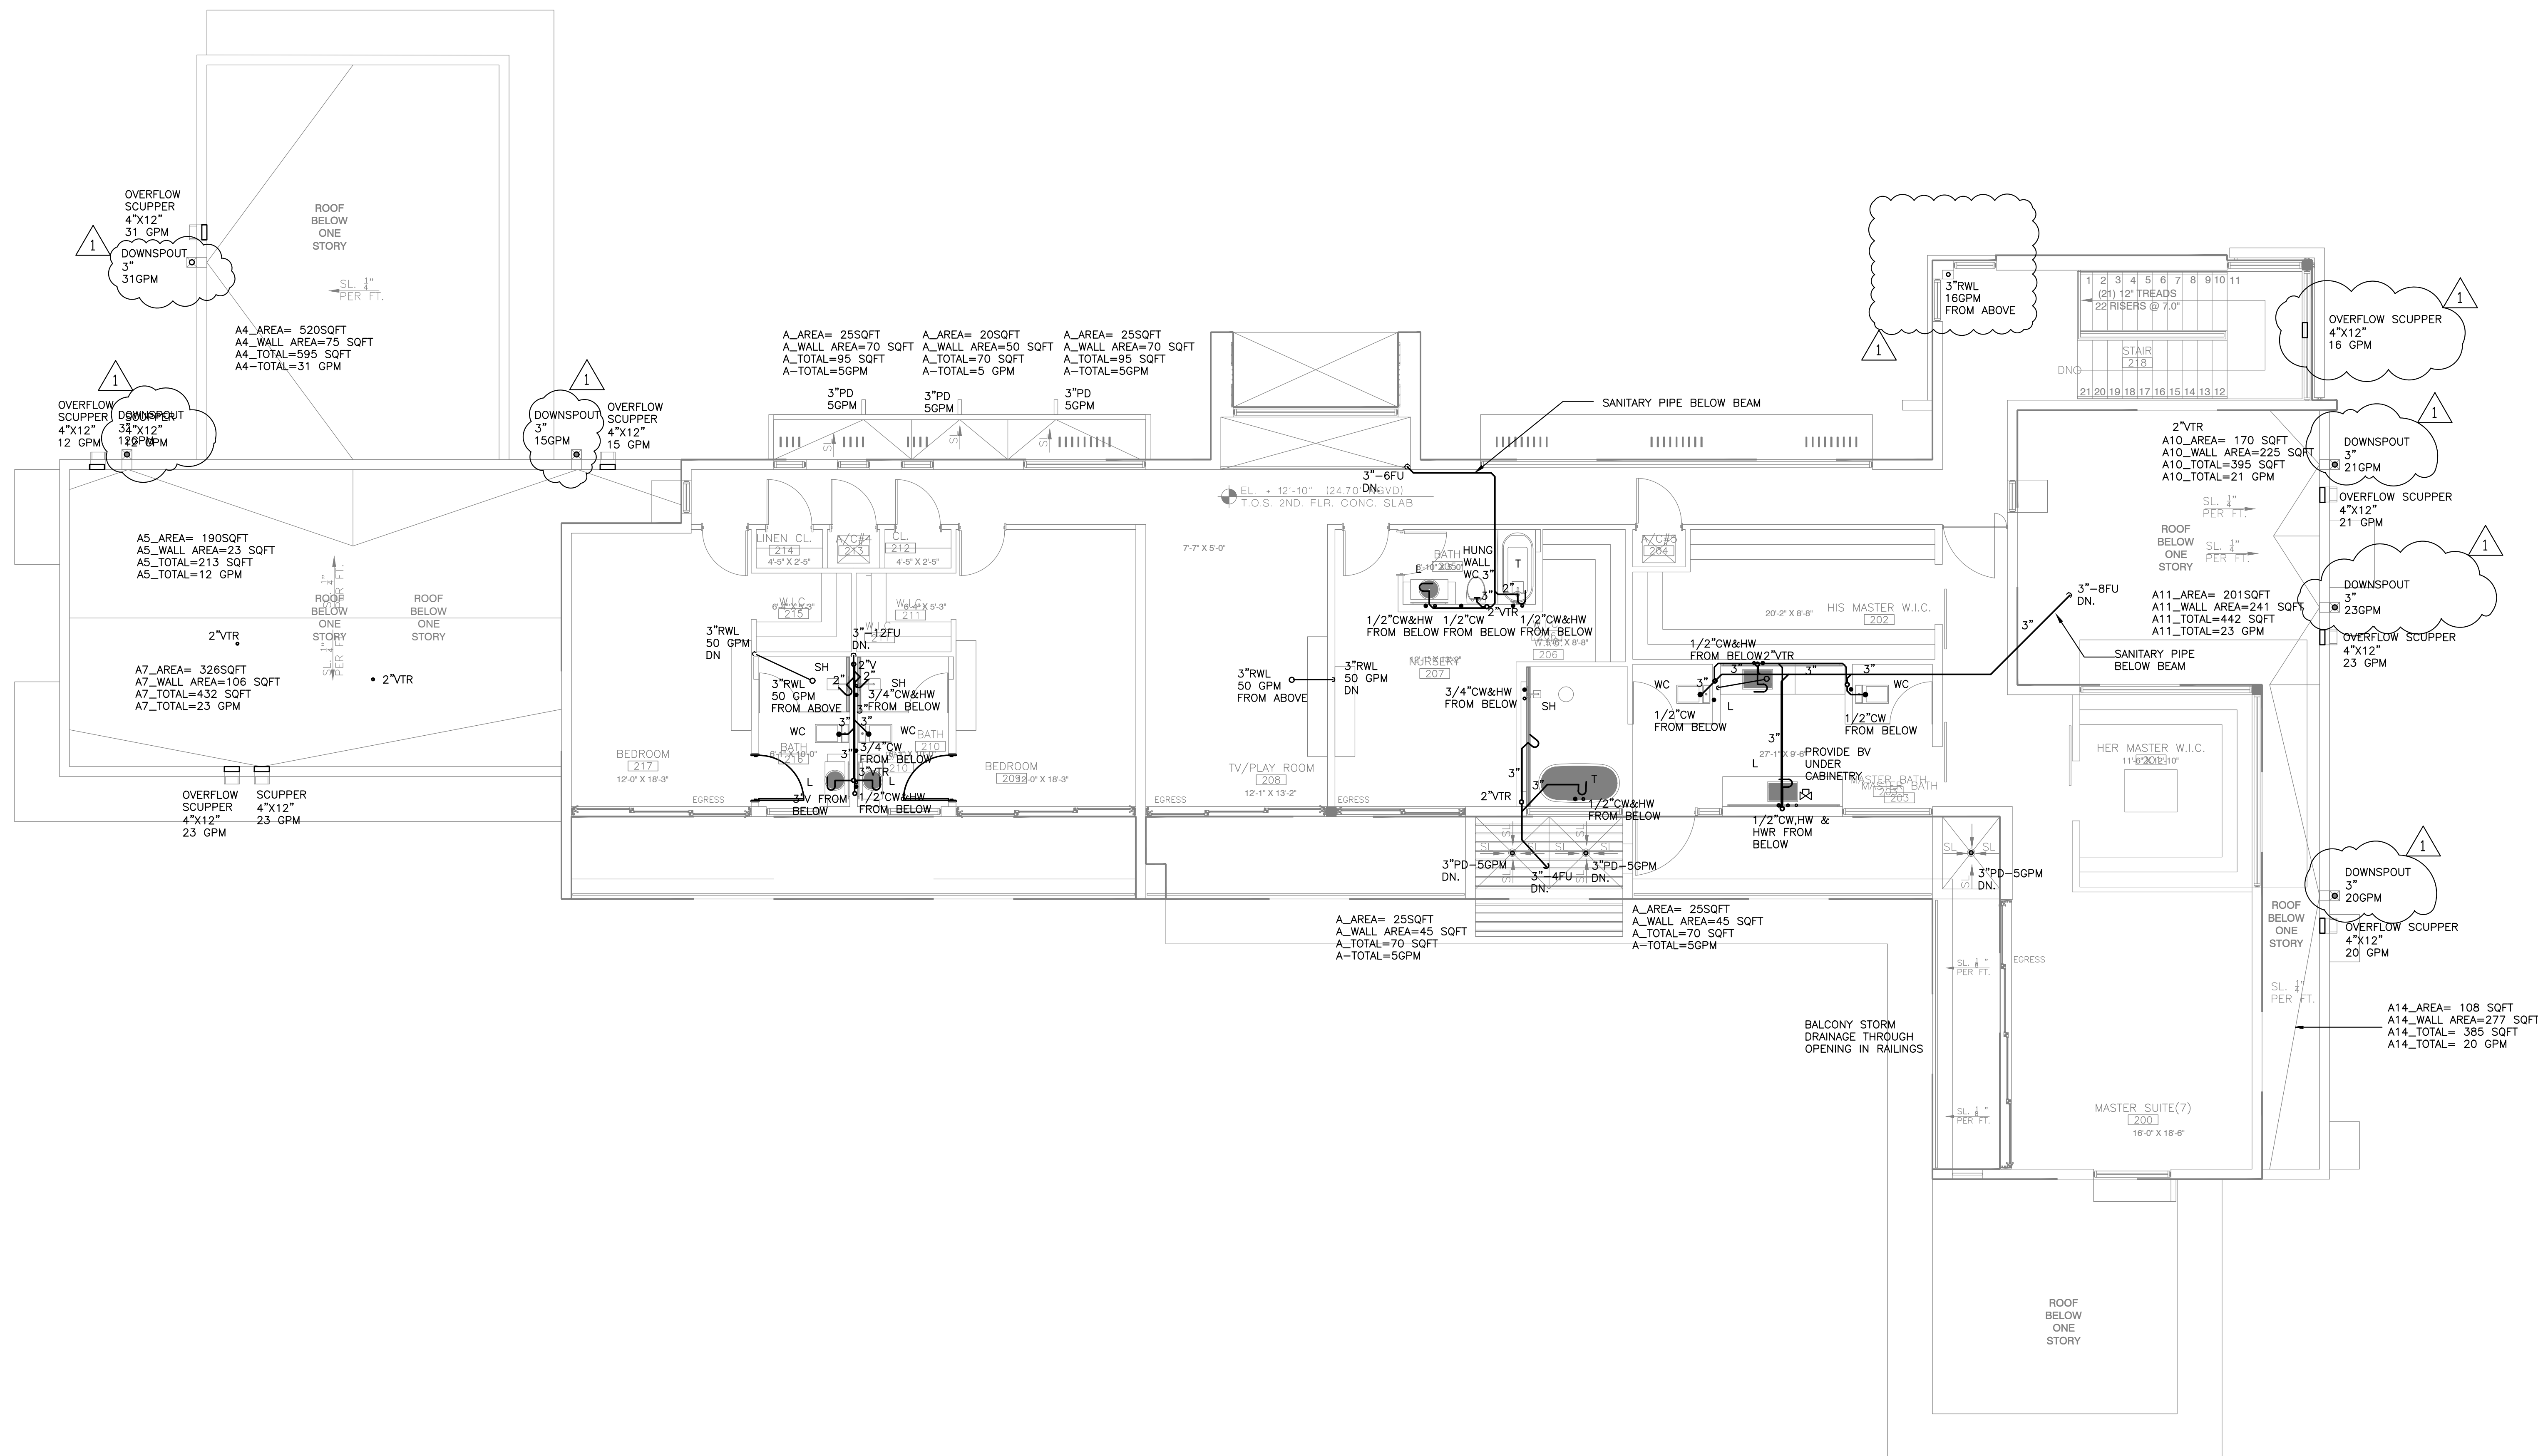


PLUMBING SECOND FLOOR PLAN

SCALE: 3/16"=1'-0"

This item has been digitally signed and sealed by Amaris Rodriguez, P.E. on the date adjacent to the seal.
Printed copies of this document are not considered signed and sealed and the signature must be verified
on any electronic copies.

JOB # 23-0822

arpe
engineering inc
2020 Ponce de Leon Blvd., Suite 1002
Coral Gables, Florida 33134
Phone > 305 444 9809
Fax > 305 444 9827
www.arpe-eng.comEngineering Design:
> Mechanical > Electrical
> Plumbing > Fire ProtectionAmaris Rodriguez, P.E.
License Number 60236

Date: 12/14/23

Signature: [Signature]

Date: 4/15/27 -05'00'