
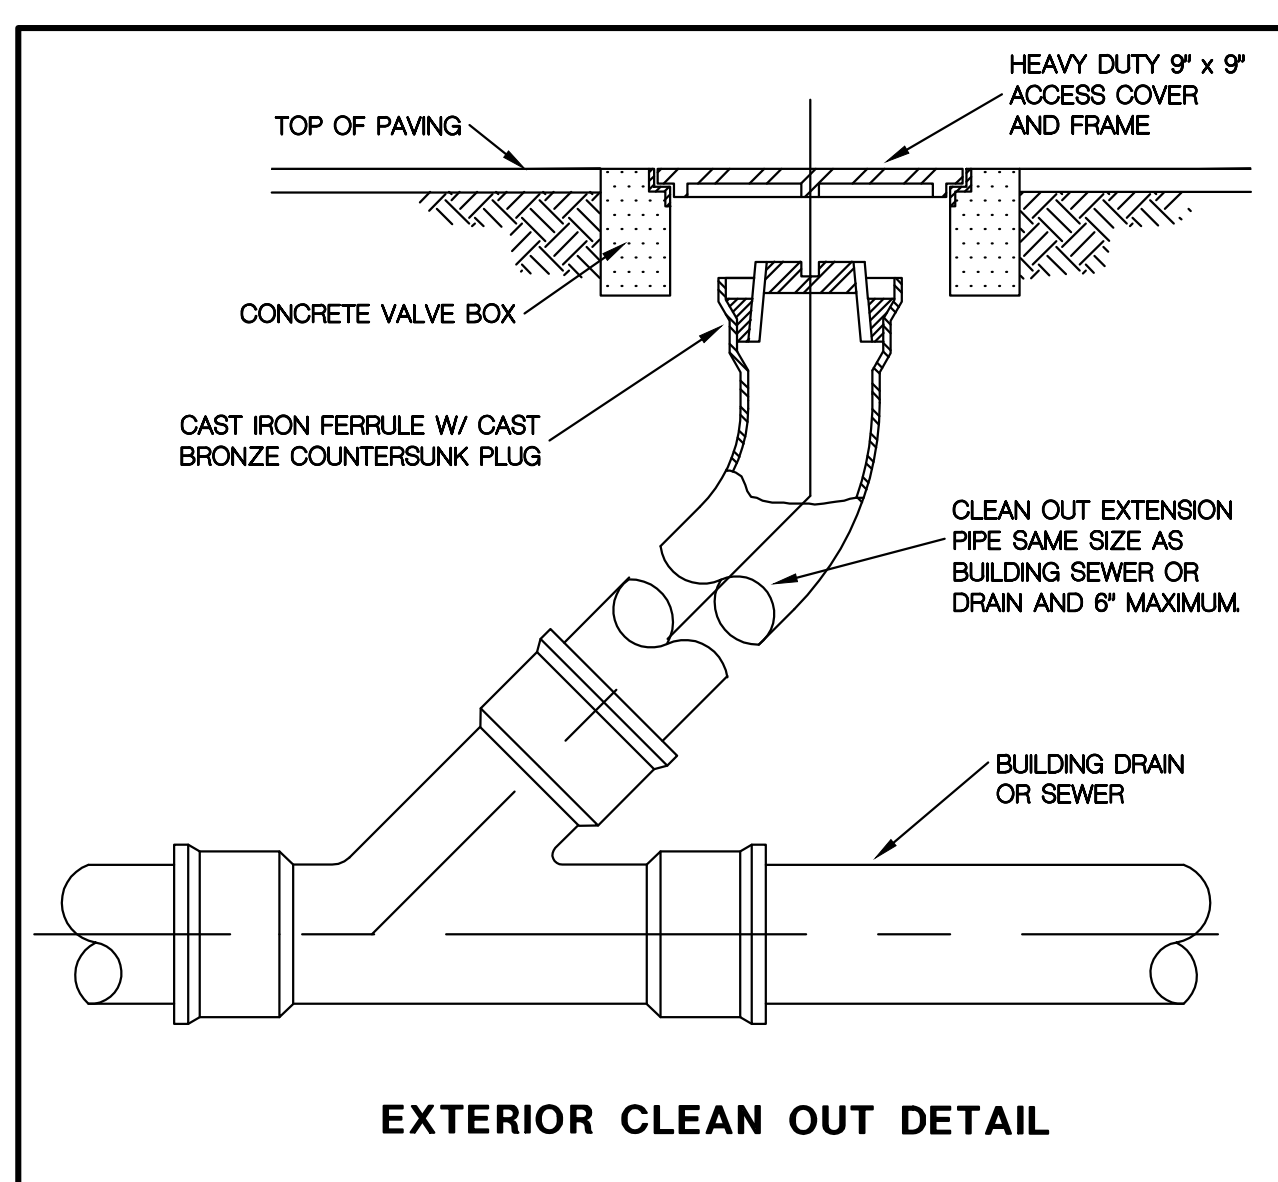
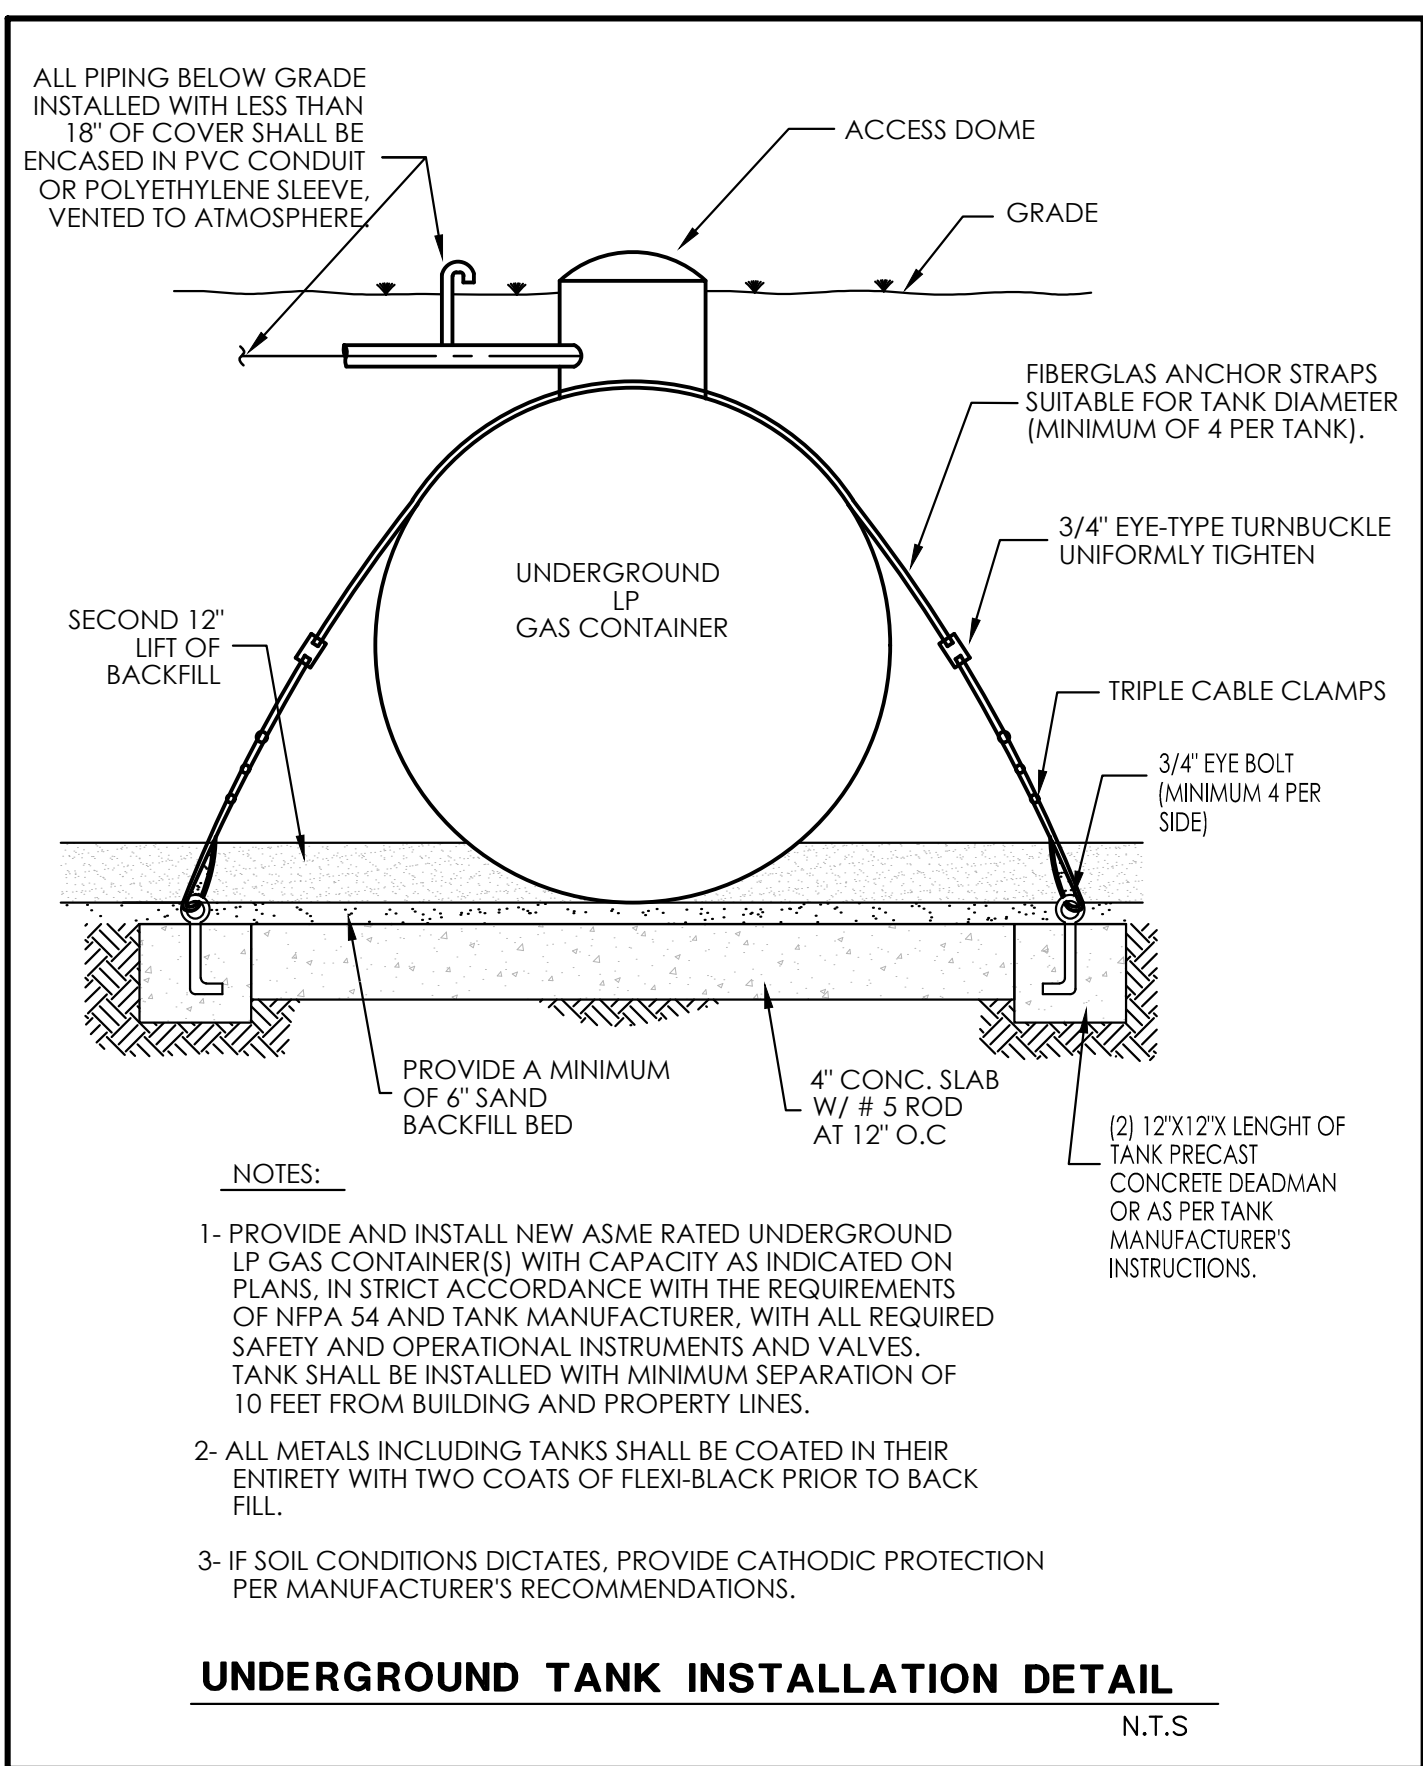
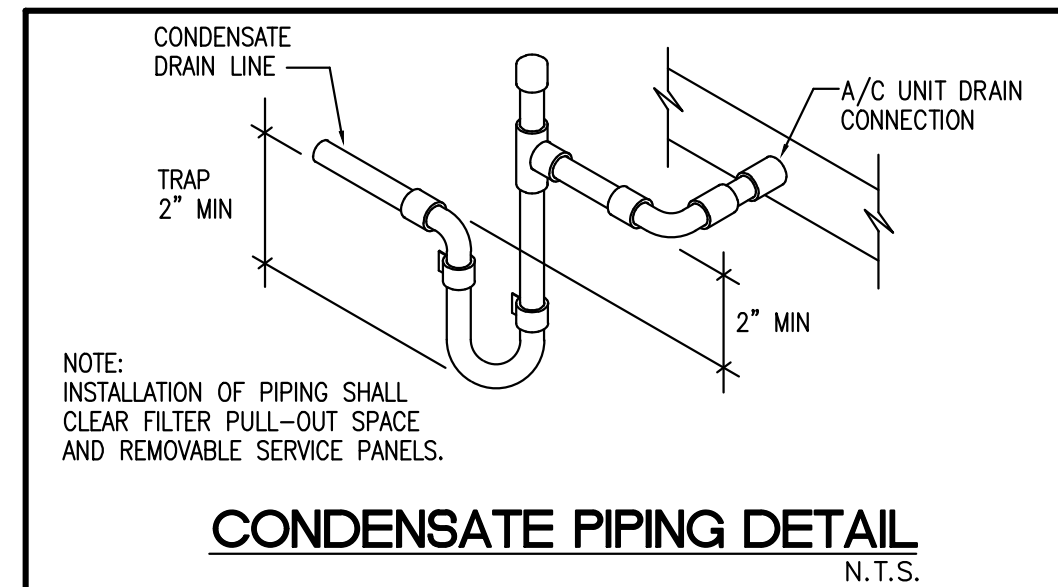
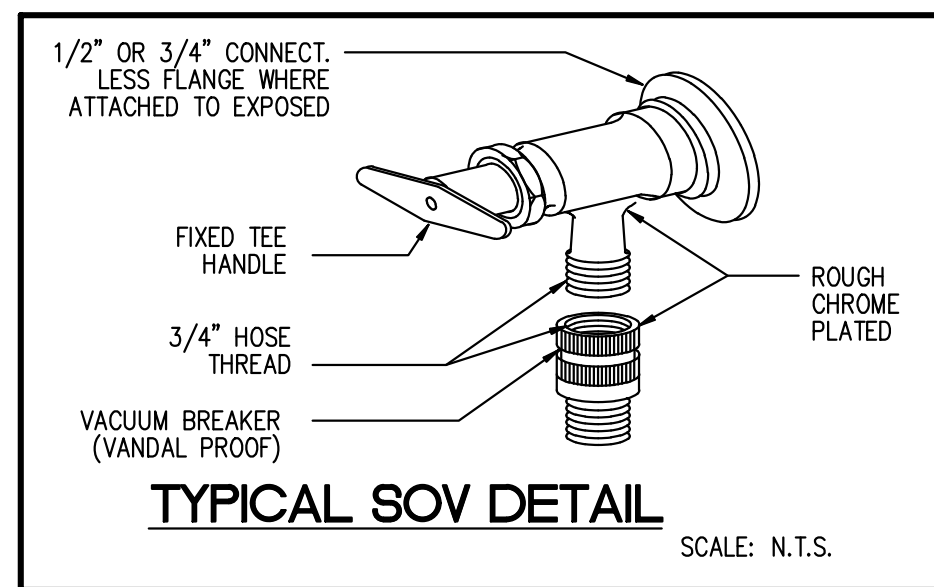
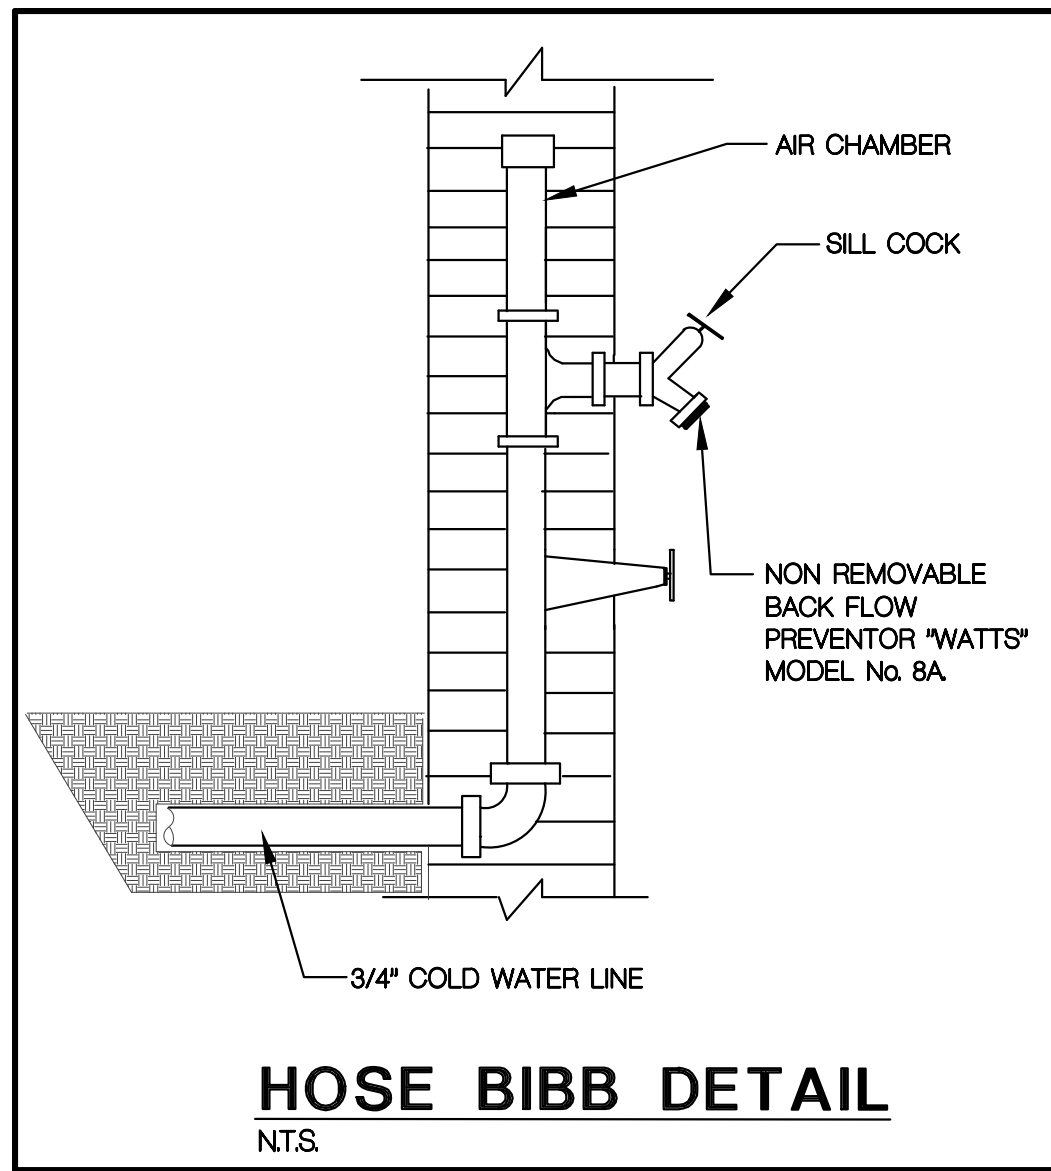
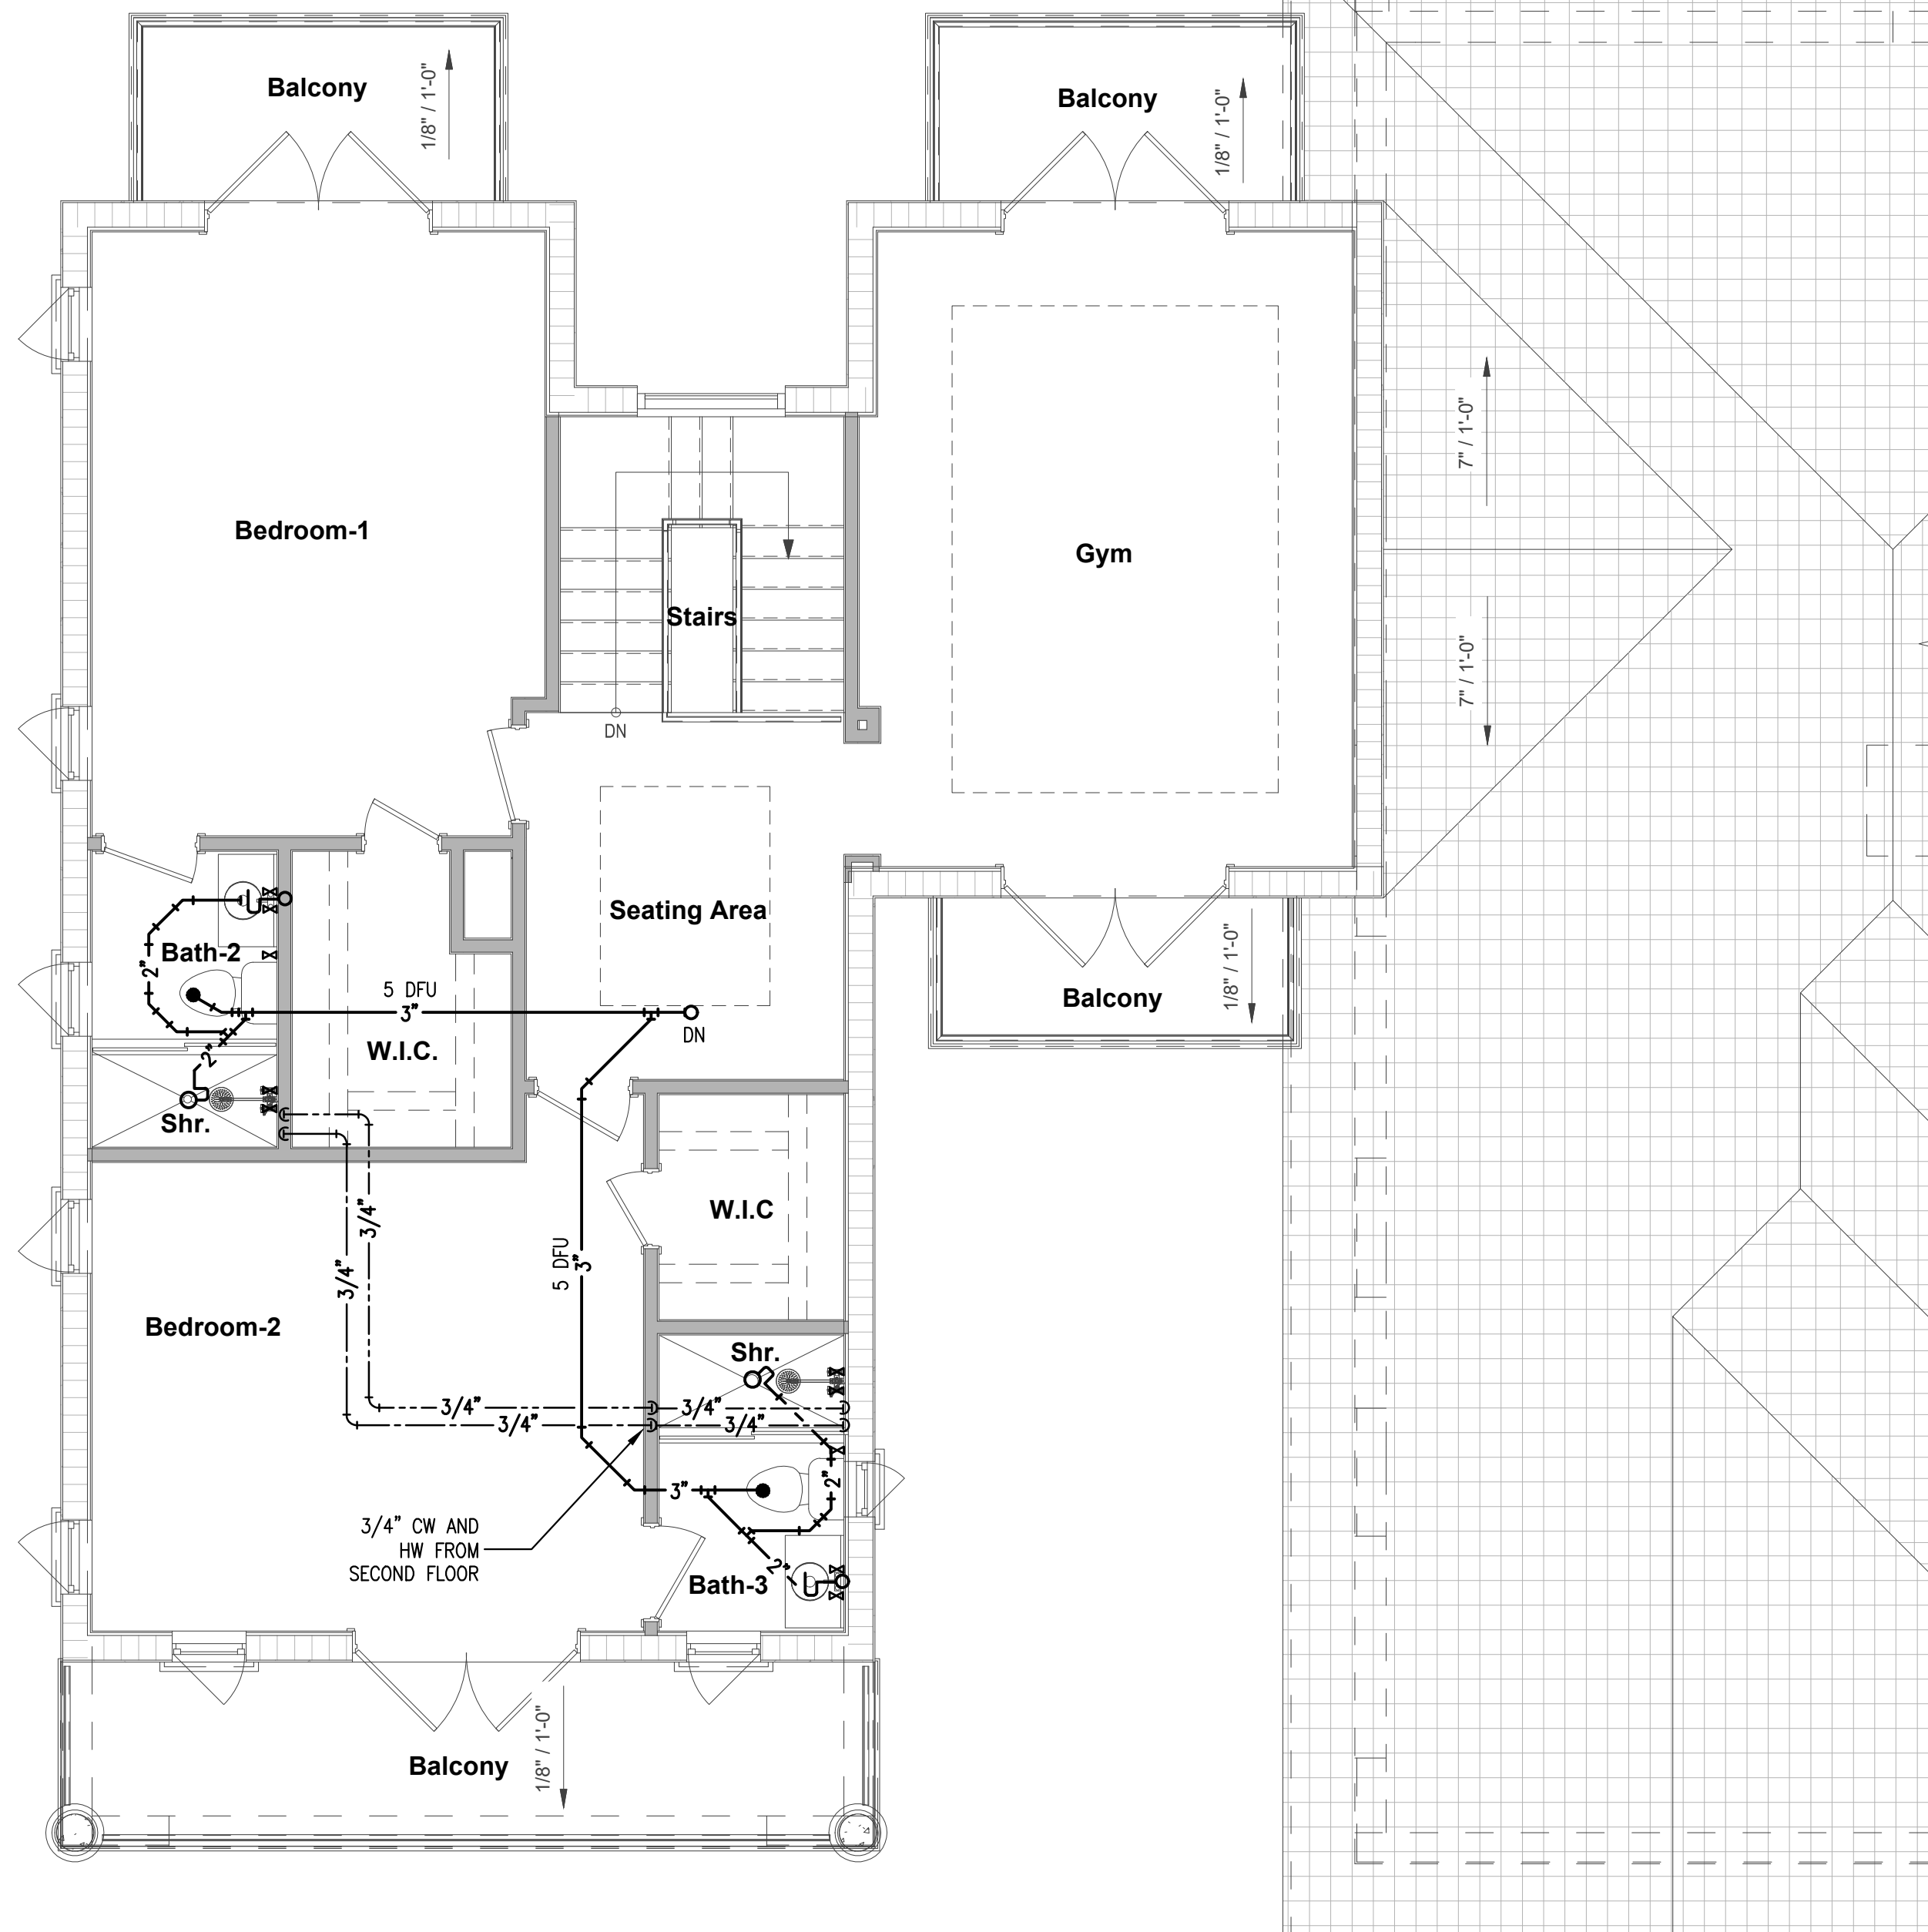


1. ALL WORK SHALL CONFORM WITH FLORIDA BUILDING CODE 2020 7TH EDITION FEDERAL ORDINANCES GOVERNING THE INSTALLATION OF THE PLUMBING SYSTEM. IF WORK AS LAID OUT, INDICATED OR SPECIFIED IS CONTRARY TO OR IN CONFLICT WITH LOCAL ORDINANCES, BUILDING CODES AND REGULATIONS, THE CONTRACTOR SHALL REPORT IN WRITING TO THE ARCHITECT/ENGINEER. BEFORE SUBMITTING A BID, THE ARCHITECT/ENGINEER WILL THEN ISSUE INSTRUCTIONS AS TO HOW TO PROCEED.
2. THE DRAWINGS ARE TO BE CONSIDERED DIAGRAMMATIC, NOT NECESSARILY SHOWING IN DETAIL OR TO SCALE ALL OF THE MINOR ITEMS. UNLESS SPECIFIC DIMENSIONS ARE SHOWN, THE STRUCTURAL, MECHANICAL AND ELECTRICAL DETAILS SHALL GOVERN THE EXACT LOCATIONS. CONTRACTOR SHALL FOLLOW DRAWINGS IN LAYING OUT WORK, CHECK DRAWINGS OF ALL TRADES TO VERIFY SPACES IN WHICH WORK WILL BE INSTALLED AND MAINTAIN MAXIMUM HEAD ROOM, AND SPACE CONDITIONS AT ALL POINTS. WHERE HEAD ROOM, OR SPACE REQUIREMENTS APPEAR INCONGRUOUS, ARCHITECT/ENGINEER SHALL BE NOTIFIED BEFORE PROCEEDING WITH INSTALLATION. THIS CONTRACTOR SHALL, WITHOUT EXTRA CHARGE, MAKE FIELD MODIFICATION IN LAYOUT AS NEEDED TO PREVENT CONFLICT WITH WORK OF VARIOUS TRADES OR FOR PROPER EXECUTION OF THE WORK.
3. EXAMINE ALL DRAWINGS CAREFULLY PRIOR TO SUBMITTING A BID. CONTRACTOR WILL BE REQUIRED TO FURNISH, INSTALL, AND/OR CONNECT WITH APPROPRIATE SERVICES ALL PLUMBING ITEMS, SHOWN ON ANY OF THE ARCHITECTURAL, MECHANICAL, ELECTRICAL, WITHOUT ADDITIONAL EXPENSE TO THE OWNER, IF DISCREPANCIES, CONFLICTS, INTERFERENCE OR OMISSIONS OCCUR BETWEEN DRAWINGS, NOTIFY IN WRITING THE ARCHITECT/ENGINEER IN AMPLE TIME TO PERMIT REVISIONS BEFORE THE BIDS ARE SUBMITTED.
4. INSTALL MATERIALS AND EQUIPMENT IN A NEAT AND FIRST CLASS WORKMANLIKE MANNER. THE OWNER RESERVES THE RIGHT TO DIRECT REMOVAL AND REPLACEMENT OF ITEMS WHICH, IN HIS OPINION, DO NOT PRESENT A NEAT AND WORKMANLIKE APPEARANCE. REMOVAL AND REPLACEMENT IS TO BE DONE IMMEDIATELY WHEN DIRECTED BY THE OWNER IN WRITING, AT THE SOLE EXPENSE OF CONTRACTOR.
5. START OF WORK BY CONTRACTOR SHALL BE CONSIDERED AS ACCEPTANCE BY HIM OF ALL CLAIMS OR QUESTIONS AS TO SUITABILITY OF THE WORK OF OTHER TRADES. ANY CONTRACTORS TO RECEIVE HIS WORK, THIS CONTRACTOR SHALL REMOVE AND REPLACE, AT HIS EXPENSE, ALL PLUMBING WORK WHICH MAY HAVE TO BE REMOVED BECAUSE OF INTERFERENCE WITH OTHER TRADES.
6. THIS CONTRACTOR SHALL OBTAIN AND PAY ALL INSURANCE, FEES, PERMITS, ASSOCIATION DUES, ROYALTIES AND TAXES OF WHATEVER NATURE SHALL APPLY TO THIS WORK. HE SHALL ALSO PAID ALL THE INSPECTION FEES AS REQUIRED BY LAW OR ORDINANCE AND SHALL KEEP THE OWNER HARMLESS FROM ANY DAMAGE AND EXPENSE ARISING FROM ANY VIOLATION OF LAWS,
7. PROVIDE MEANS "FURNISH AND INSTALL".
8. DO A COMPLETE JOB, EVERYTHING CONNECTED, READY FOR USE.
9. SHOP DRAWINGS: CONTRACTOR SHALL FURNISH THE ENGINEER WITH SHOP DRAWINGS OF EQUIPMENT PRIOR TO PURCHASE FOR APPROVAL.
10. AT COMPLETION OF JOB THE PLUMBING CONTRACTOR SHALL GIVE THE OWNER AN AS-BUILT SET OF REPRODUCIBLE SEPIAS SHOWING THE EXACT LOCATION OF ALL INSTALLATIONS.
11. PLUMBING CONTRACTOR SHALL PRESSURE TEST ALL PIPING AS REQUIRED BY CODE. TEST SHALL BE WITNESSED AND APPROVED BY PROPER AUTHORITIES.
12. THE PLUMBING CONTRACTOR SHALL WARRANT ALL WORKMANSHIP AND MATERIALS FOR ONE YEAR FROM THE DATE OF FINAL WORK ACCEPTANCE BY OWNER. ANY BREAKDOWN OCCURRING IN ONE YEAR SHALL BE REPAIRED AT NO EXPENSE TO THE OWNER.
13. PROVIDE BATHROOM FIXTURES AS SPECIFIED OR AS SELECTED BY OWNER
14. PROVIDE SHUTOFF VALVE FOR EACH FIXTURE.
15. WHEREVER NOT SIMILAR METALS ARE TO BE JOINED, A DIELECTRIC FITTING SHALL BE PROVIDED TO CONNECT BOTH TYPES OF PIPES.
16. PLUMBING CONTRACTOR SHALL PROVIDE AIR CONDITIONING CONDENSATE DRAIN AND CONDENSATE PIPING SET AIR CONDITIONING PLANS FOR LOCATION OF UNITS AND DRAINS.
17. ALL SANITARY FITTINGS SHALL BE DIRECTIONAL TYPE.
18. MATERIALS
 - A. COLD WATER PIPING DOWNSIDE OF WATER METER SHALL BE TYPE "L" COPPER BELOW GROUND AND TYPE "M" COPPER ABOVE GROUND.
 - B. COLD WATER PIPES INSIDE OF SLAB SHALL BE TYPE "K" SOFT COPPER INSTALL WITH POLYETHYLENE TUBING, JOINTS TO BE PERMITTED INSIDE SLAB.
 - C. SANITARY WASTE AND VENT 4" AND SMALLER SHALL BE P.V.C., SCHEDULE 40.
 - D. STORM LINES INSIDE BUILDING SHALL BE P.V.C. SCHEDULE 40.
 - E. IN COASTAL AREAS ALL SANITARY AND STORM PIPING OUTSIDE OF BUILDING SHALL BE SCHEDULE 40, P.V.C.
 - F. CONDENSATE DRAIN PIPE SHALL BE SCHEDULE 40, P.V.C. PIPE AND FITTINGS.
 - G. WATER HEATER RELIEF AND DRAIN LINE SHALL BE TYPE "L" COPPER, MIN. 3/4" DIA.
19. ALL CEILING PENETRATIONS, JOINTS, & CRACKS SHALL BE CAULKED, GASKETED, WEATHER STRIPPED OR OTHERWISE SEALED TO AVOID ADDITIONAL CONDITIONED AIR TO GO INTO ATTIC SPACE, AS PER F.B.C. 406.1
20. PROVIDE SLEEVE OR PIPE PROTECTION AS PER SECTION 305 OF F.B.C 2020

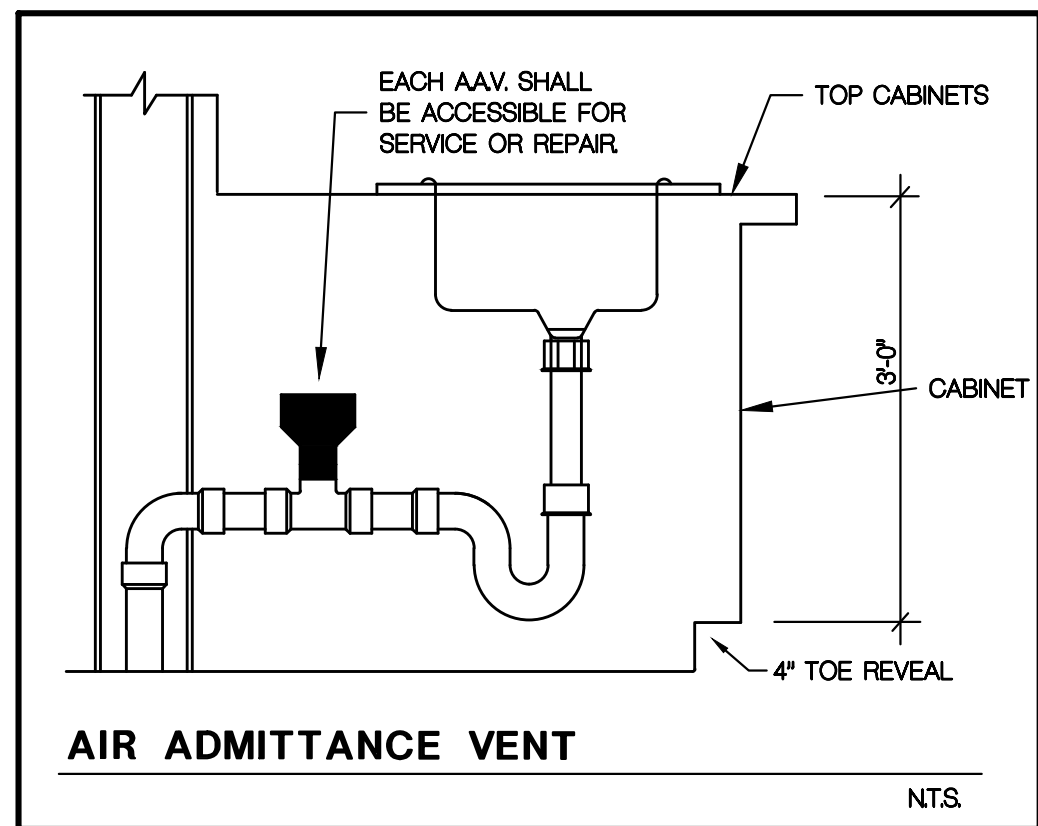

THE EXISTING SOIL INSPECTED IS SUITABLE FOR SUPPORT OF THE PROPOSED CONSTRUCTION AND THE BEARING CAPACITY OF THE SOILS FOUND MEET OR EXCEED 2000 PSF.

[illegible]

Project number	22-012
Date	04-16-2023
Drawn by	NA
Checked by	RM
SHEET TITLE	