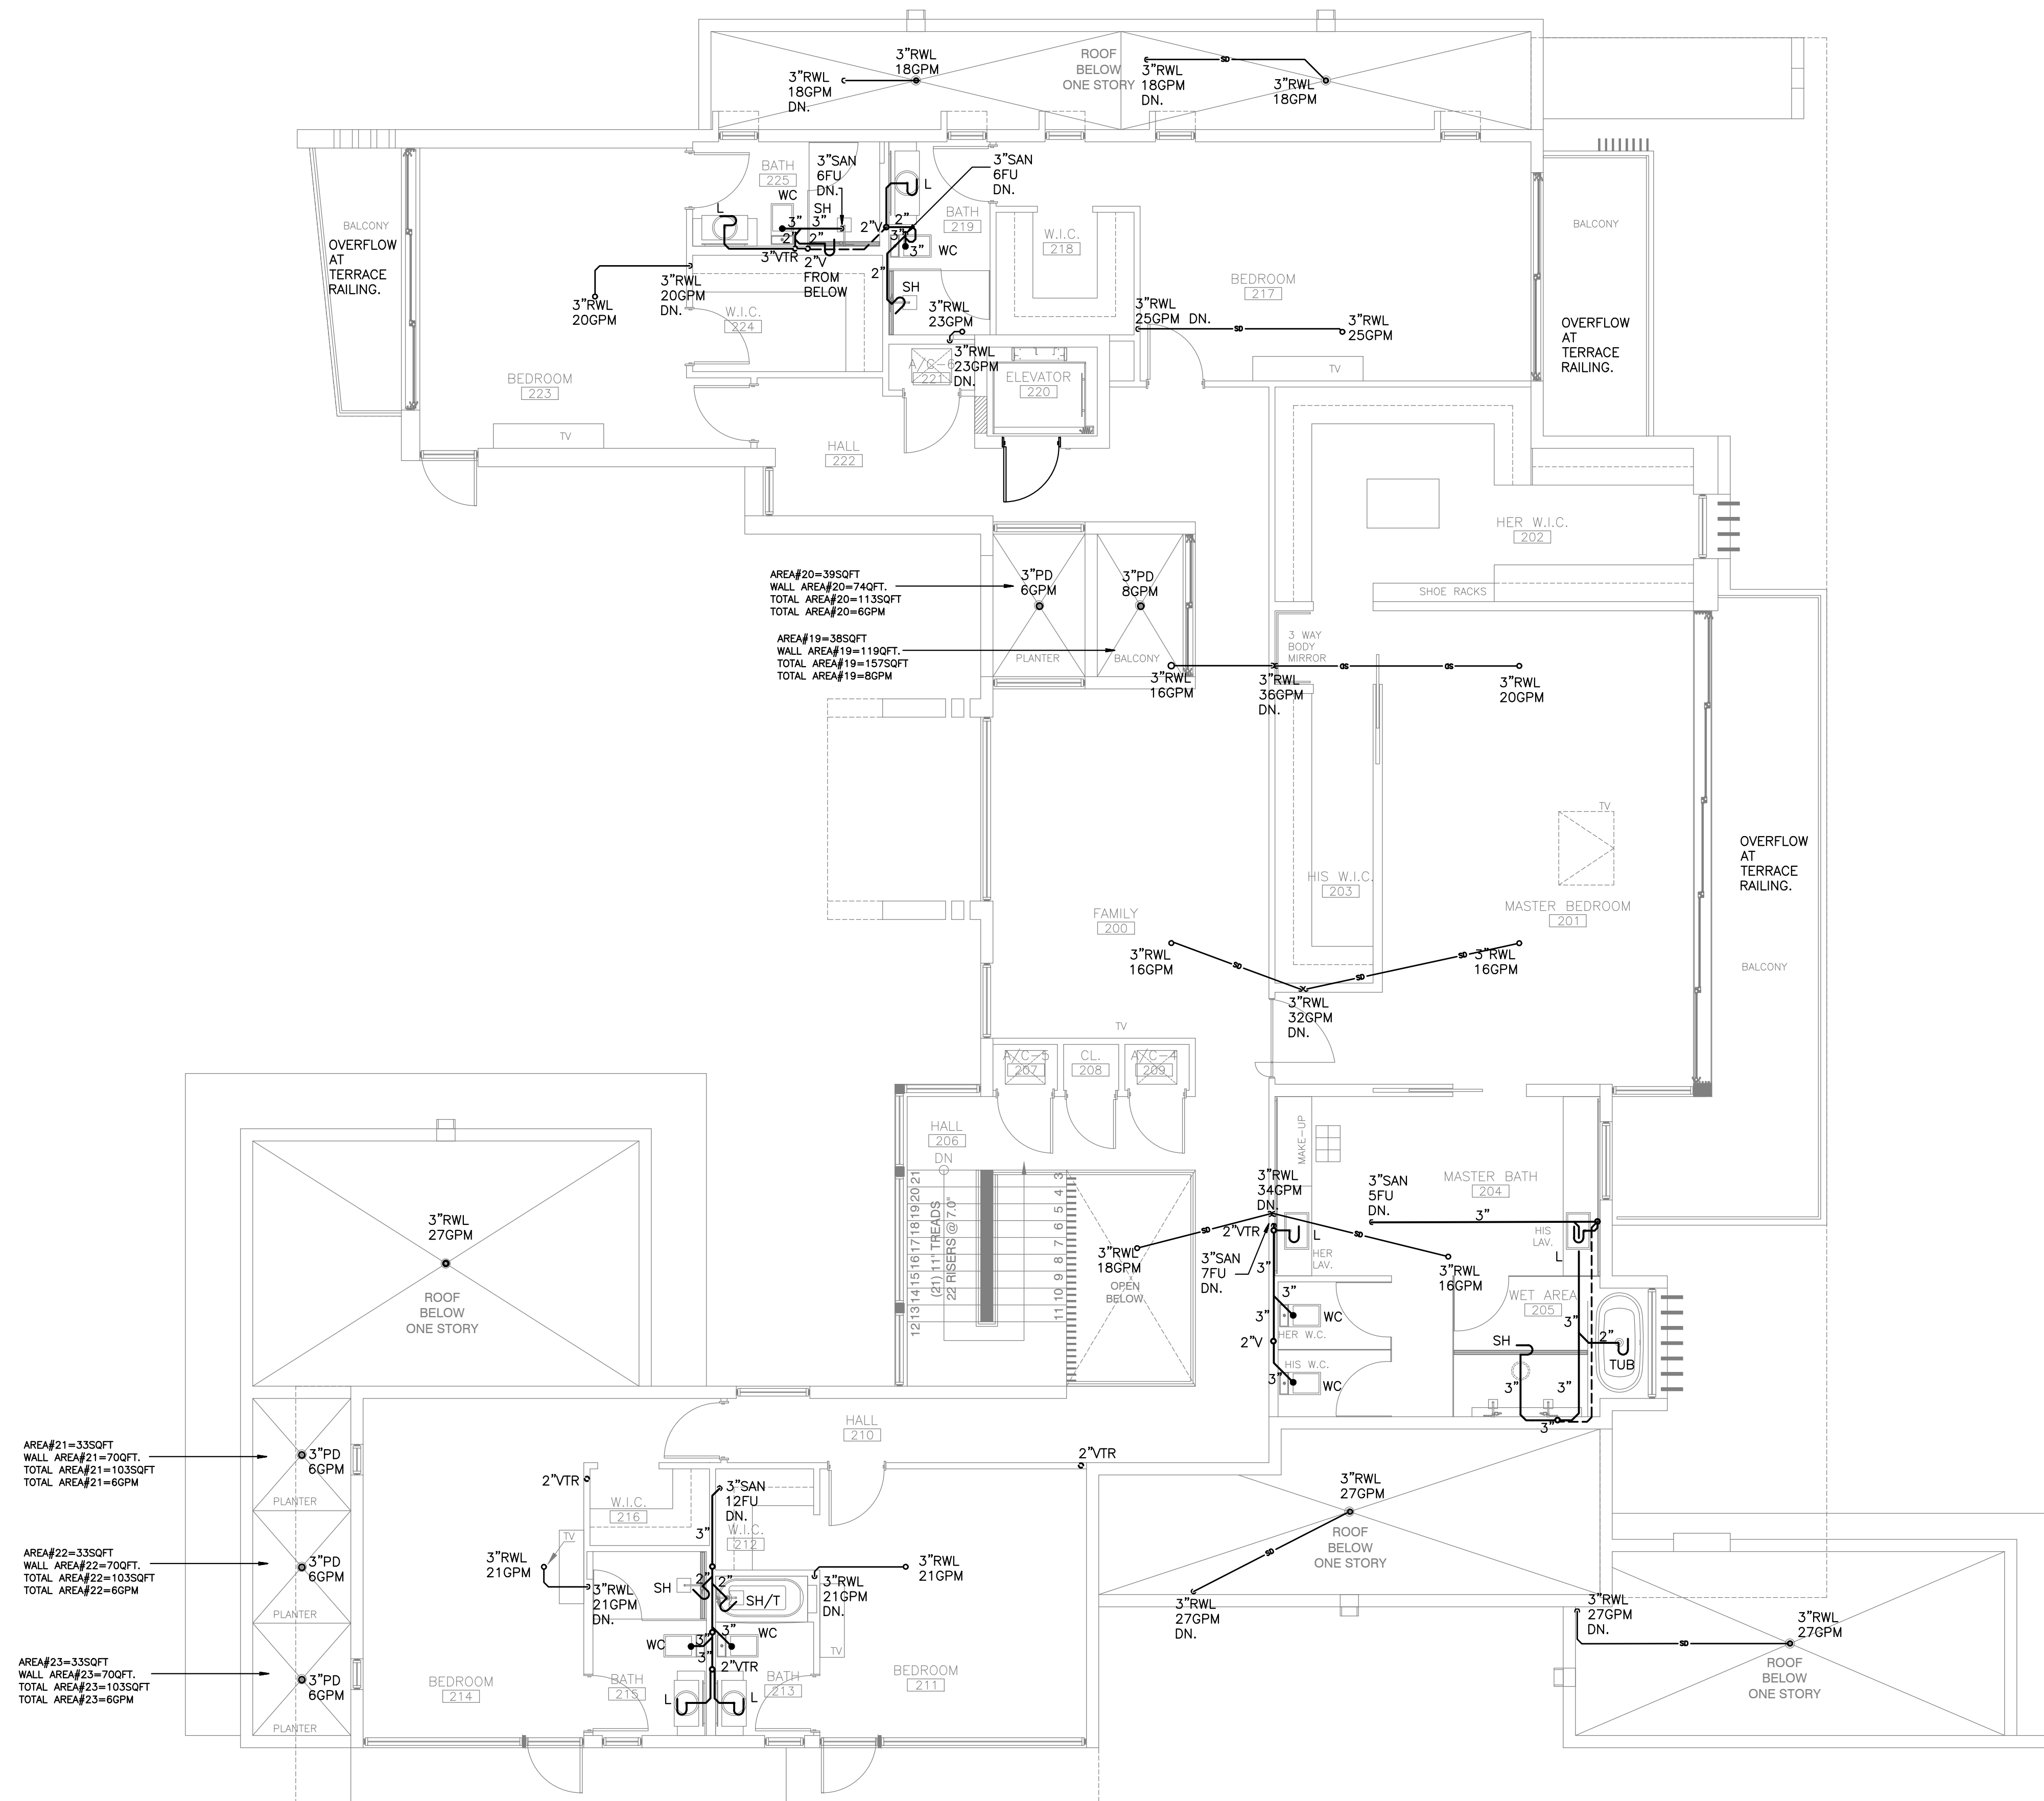


SANITARY & STORM FLOOR PLAN

SCALE: 3/16"=1'-0"

This item has been digitally signed and sealed by Amaris Rodriguez, PE, on
Printed copies of this document are not considered signed and
sealed and the signature must be verified on any electronic copies.

engineering inc
2020 Ponce de Leon Blvd., Suite 1002
Coral Gables, Florida 33134
Phone > 305 444 9809
Fax > 305 444 9827

Engineering Design:
• Mechanical • Electrical
• Plumbing • Fire Protection
www.arpe-eng.com

Date: 2024.06.06 12:19:00
Signature: [Signature]
Date: 04'00'

State of Florida
Professional Engineer
No. 12406
Ex. 60236
FELIPE ALVARADO