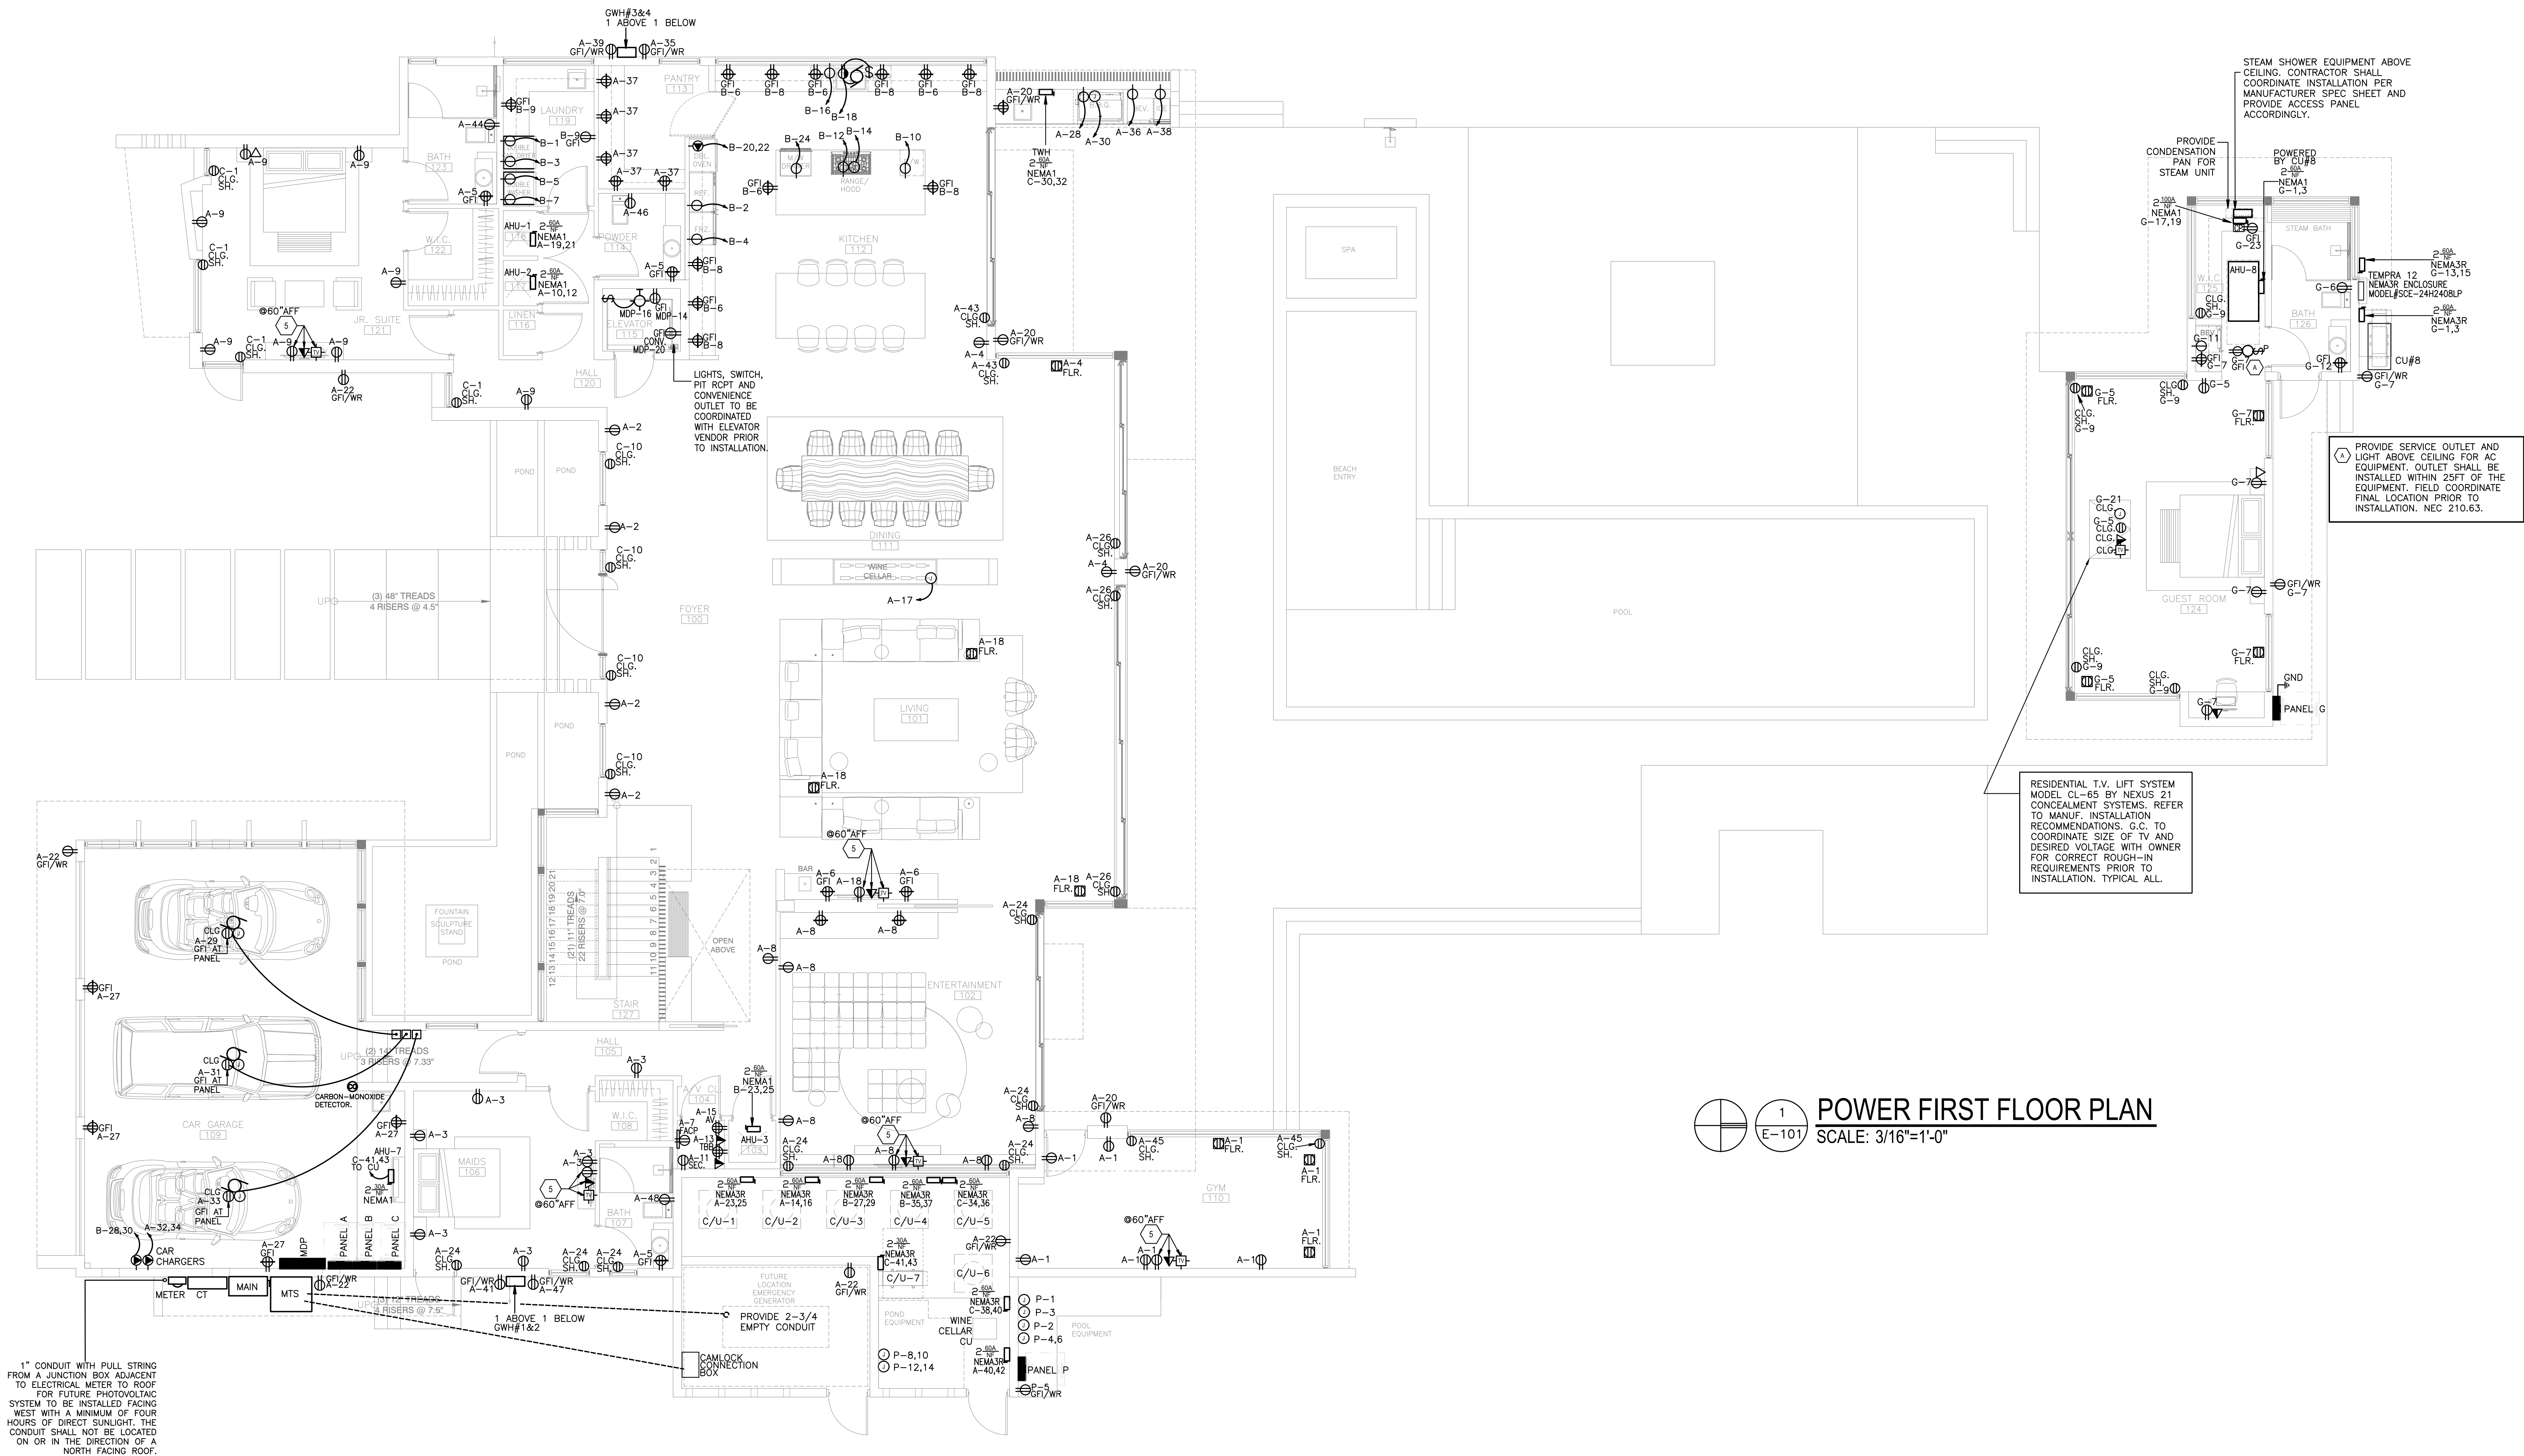


POWER FIRST FLOOR PLAN

SCALE: 3/16"=1'-0"

This item has been digitally signed and sealed by Amarilis Rodriguez, PE, on
Printed copies of this document are not considered signed and
sealed and the signature must be verified on any electronic copies.**arpe**
engineering inc
2020 Ponce de Leon Blvd., Suite 1002
Coral Gables, Florida 33134
Phone > 305 444 9809
Fax > 305 444 9827
Engineering Design:
> Mechanical > Electrical
> Plumbing > Fire Protection
www.arpe-eng.comAmarilis Rodriguez, PE
License Num 1900236

Date: 2024.06.06

13:41:35 -04'00'