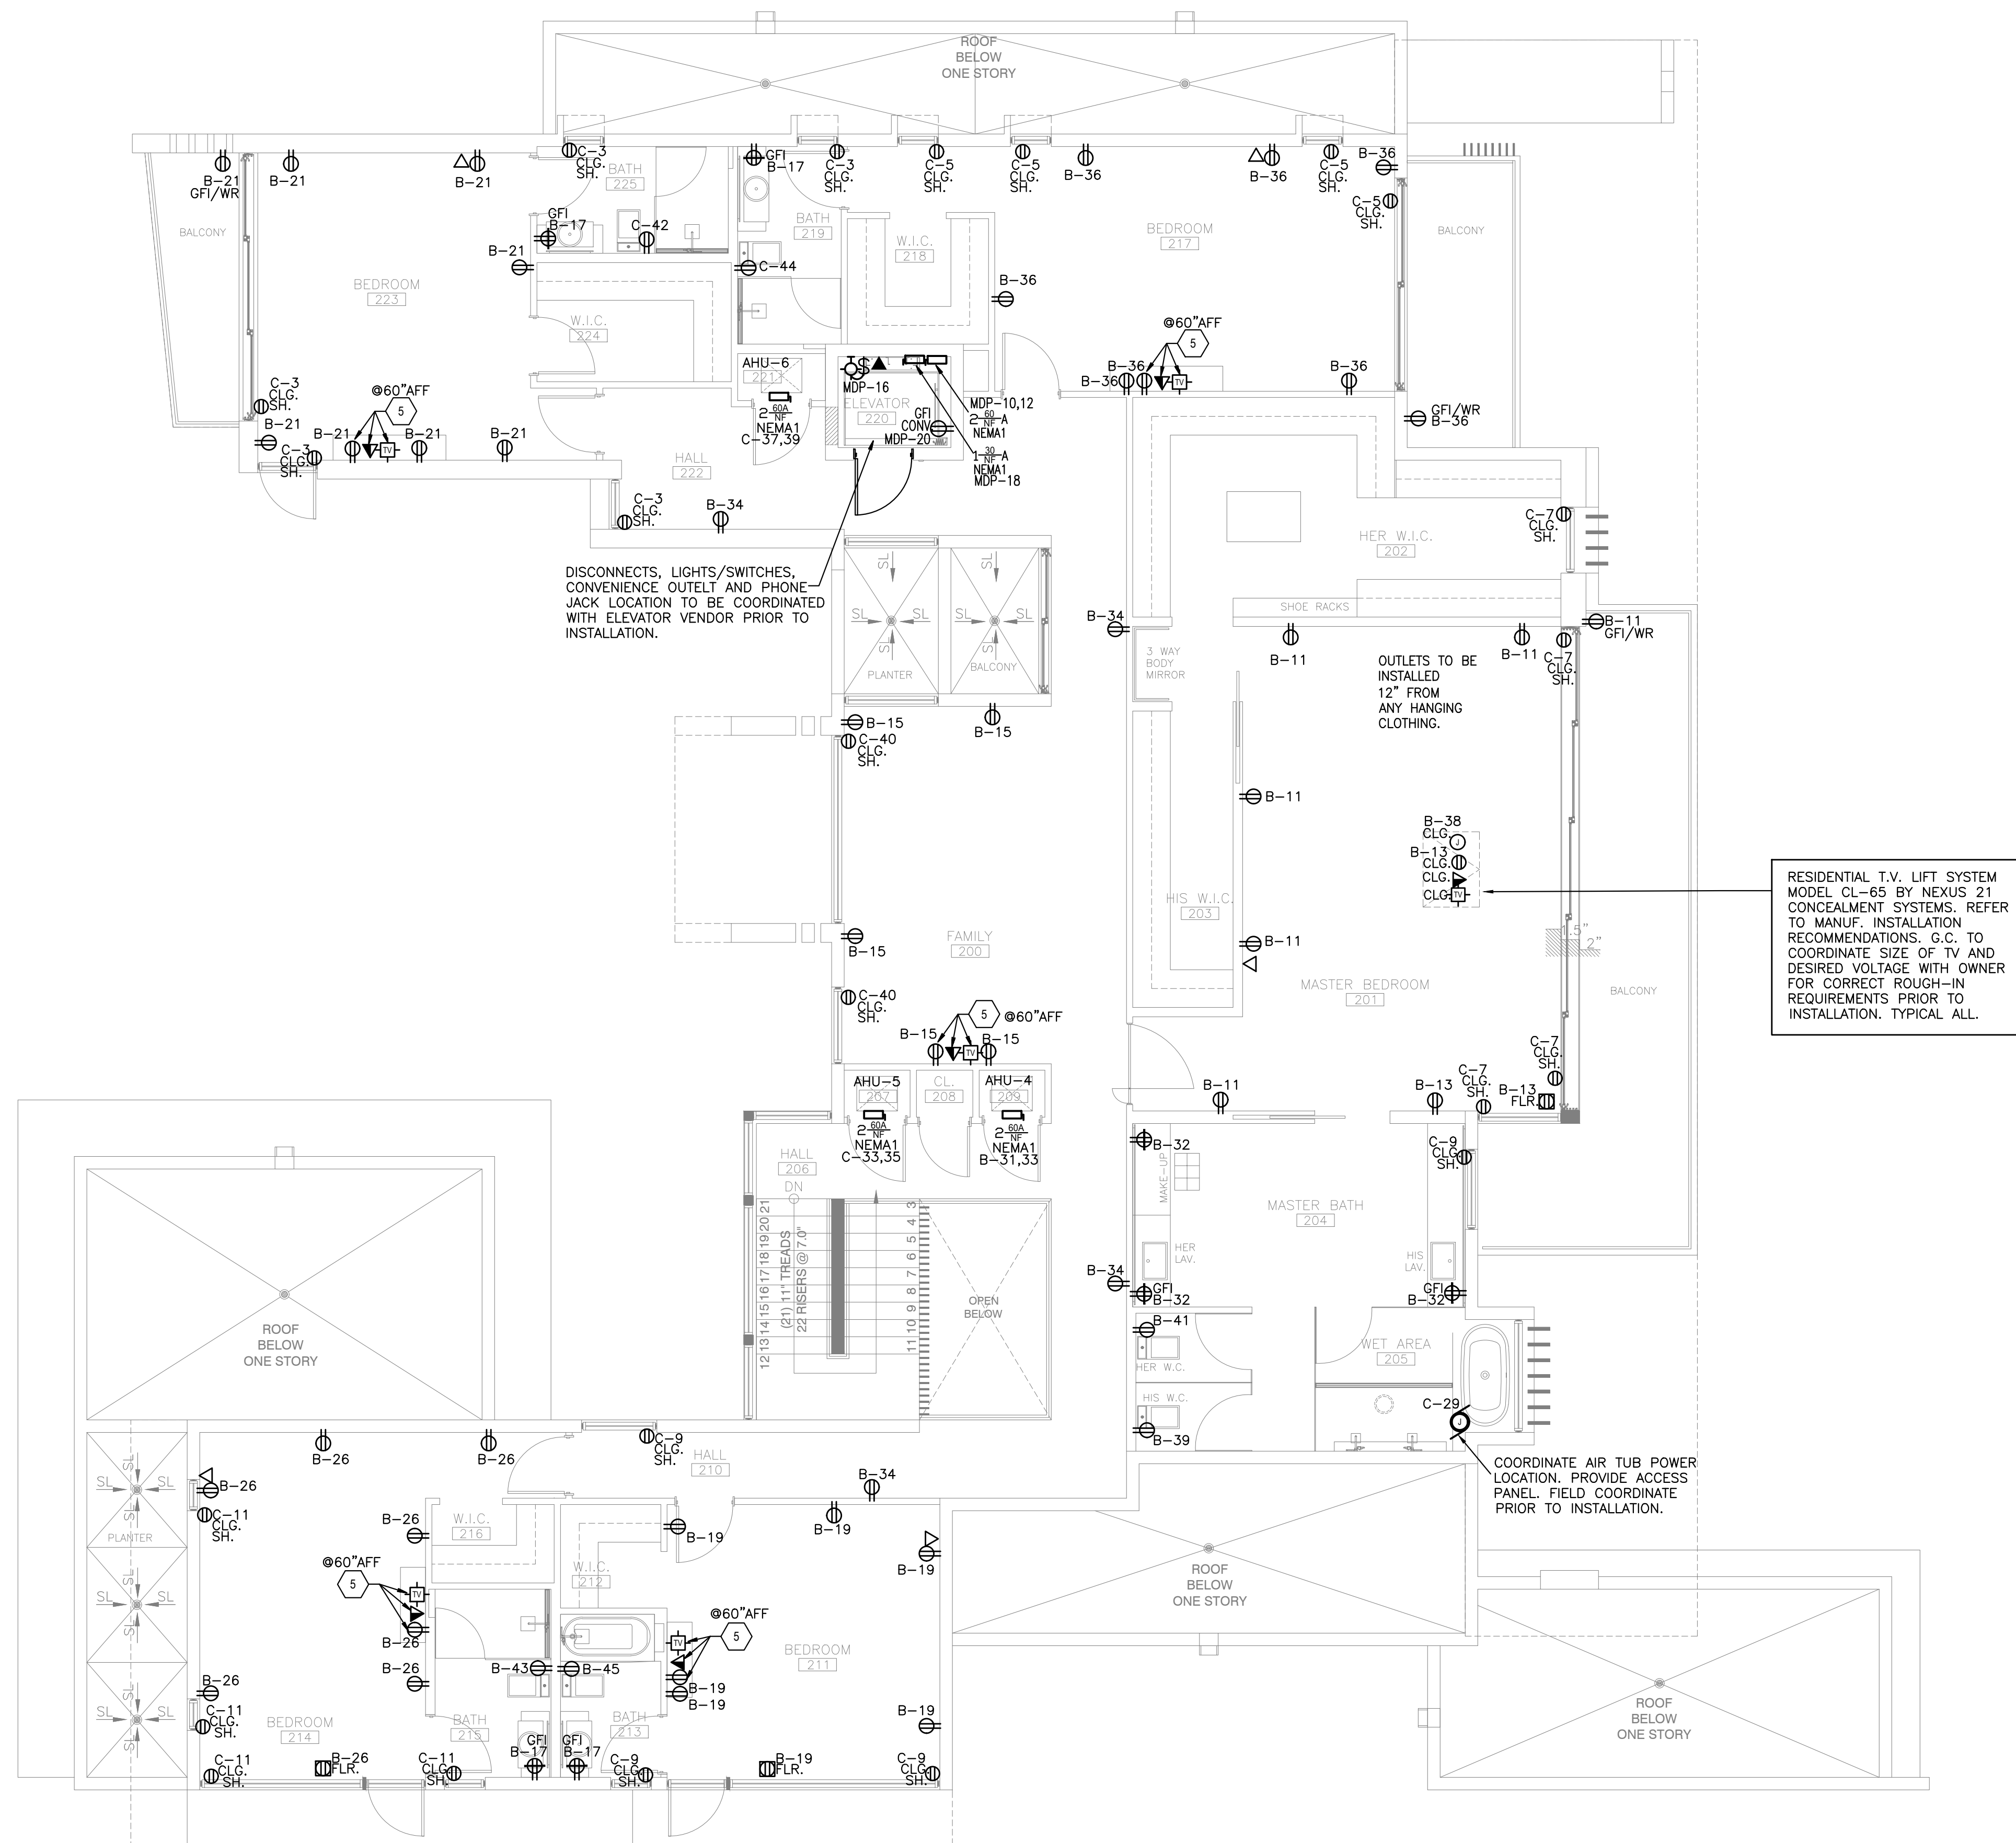


POWER SECOND FLOOR PLAN
SCALE: 3/16"=1'-0"

This item has been digitally signed and sealed by Amarilis Rodriguez, P.E., on 2024.06.06.
Printed copies of this document are not considered signed and sealed and the signature must be verified on any electronic copies.

Date: 24-0307

2024.06.06

Number: 60236

13:41:1

Signature _____

4-04001

Engineering Design:
• Mechanical • Electrical
• Plumbing • Fire Protection

Date _____

www.apd-pe.com