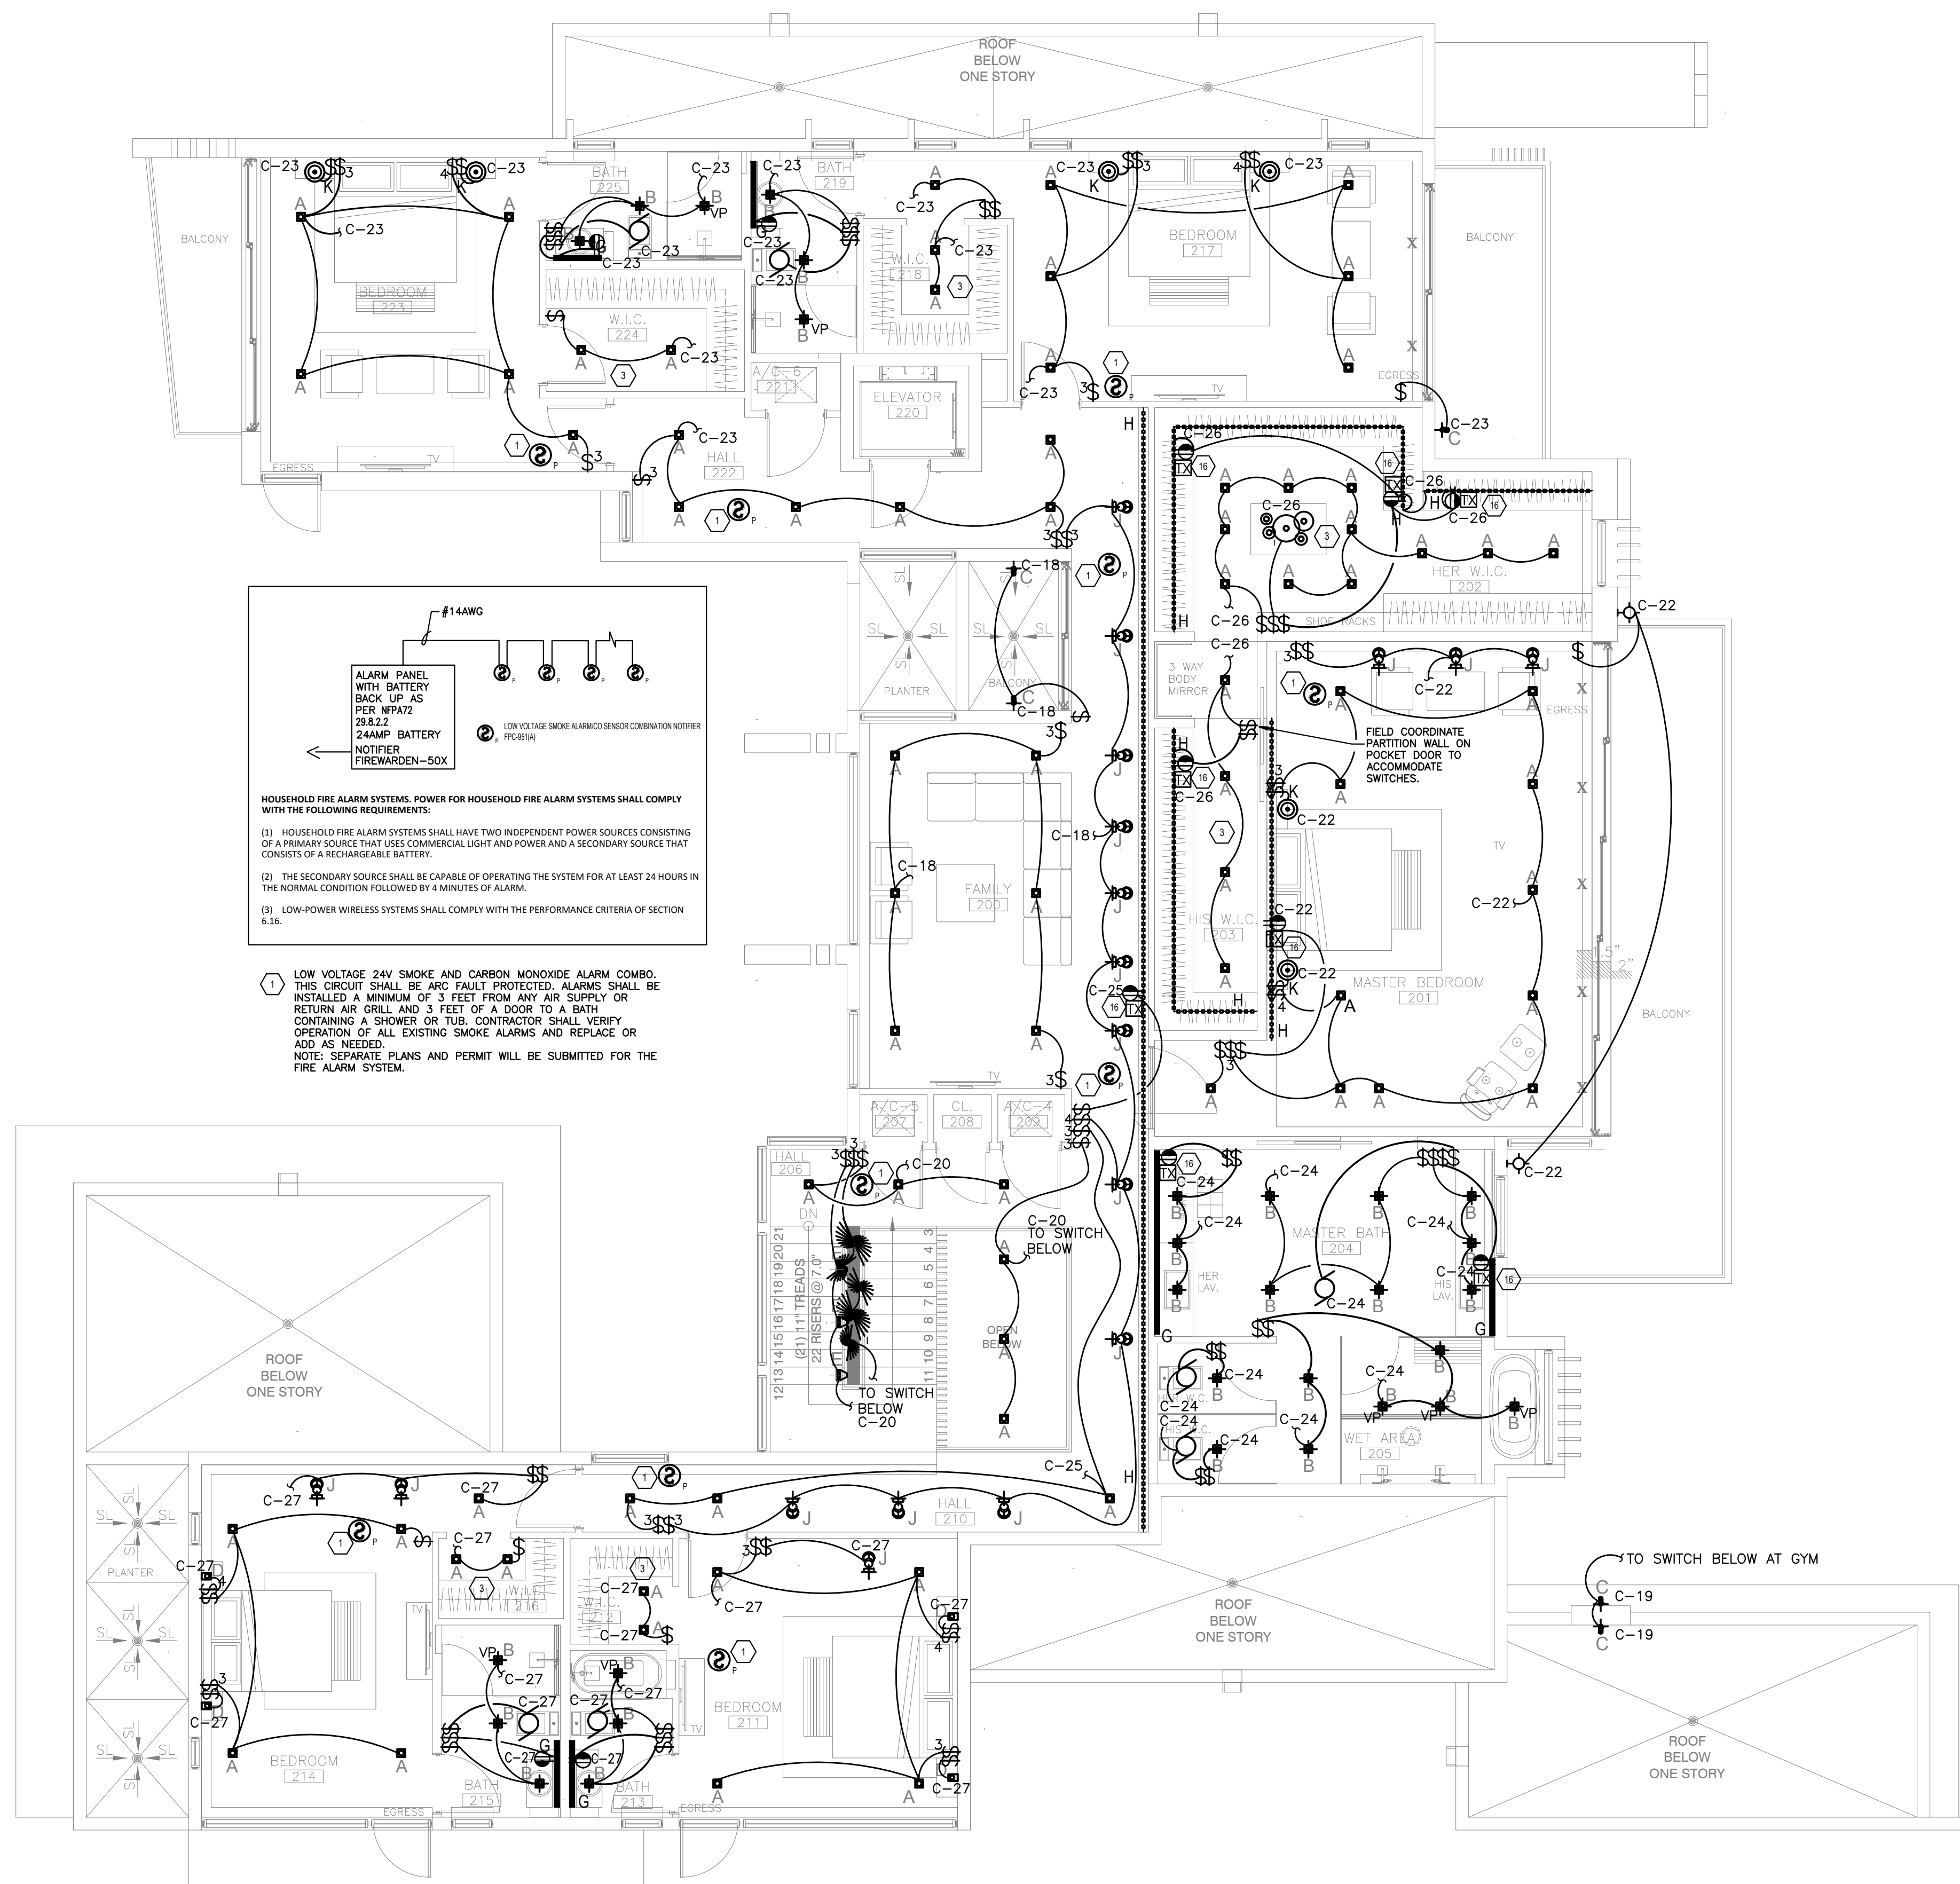
LIGHTING SECOND FLOOR PLAN
SCALE: 3/16"=1'-0"This item has been digitally signed and sealed by Amaris Rodriguez, PE, on
Printed copies of this document are not considered signed and
sealed and the signature must be verified on any electronic copies. JOB# 24-0307

arpe
engineering inc

2020 Ponce de Leon Blvd., Suite 1002
Coral Gables, Florida 33134
Phone > 305 444 8809
Fax > 305 444 9827

Engineering Design:
> Mechanical > Electrical
> Plumbing > Fire Protection
www.arpe-eng.com

Amaris Rodriguez, P.E.
License F-10060236

Date: 2024.06.06
13:41:03 -04'00'