

E

D

C

B

A

1. ALL MATERIALS AND LABOR UNDER THIS PROJECT SHALL BE IN STRICT ACCORDANCE WITH THE REQUIREMENTS OF THE MIAMI-DADE WATER AND SEWER DEPARTMENT AND SHALL CONFORM TO THE STANDARDS AND SPECIFICATIONS AVAILABLE AND ON FILE WITH THE DEPARTMENT. **SUBMIT SHOP DRAWINGS FOR ALL MATERIALS.**
2. COVER OVER WATER OR SEWER FORCE MAINS SHALL BE 4'-0" MIN.
3. ALL MAIN LINE VALVES SHALL BE INSTALLED COMPLETE WITH 10" RISER PIPES AND NO. 3 OR 53 VALVE BOXES FIRE HYDRANTS AND SERVICE VALVES SHALL BE INSTALLED COMPLETE WITH 6" RISER PIPES AND NO. 2 VALVE BOXES.
4. ALL FORCE MAIN SERVICE CONNECTIONS INTO PRESSURE TRANSMISSION MAINS SHALL HAVE A SHUT OFF VALVE AND CHECK VALVE AT THE POINT OF ENTRY.
5. ALL GRAVITY SYSTEMS SHALL BE CONSTRUCTED IN ACCORDANCE WITH DEPARTMENT STANDARDS.
6. ALL WATER METERS WILL BE INSTALLED BY THE MIAMI-DADE WATER AND SEWER DEPARTMENT, PROVIDING THE APPROPRIATE CHARGES HAVE BEEN PREPAID.
7. FIRE HYDRANT REQUIREMENTS (NUMBER AND LOCATION) SHALL BE AS REQUIRED BY MIAMI-DADE COUNTY FIRE DEPARTMENT OR THE APPROPRIATE FIRE AGENCY WITH INSTALLATION IN ACCORDANCE WITH DEPARTMENT STANDARDS.
8. CONTRACTOR MUST CALL MDWASD INSPECTION DIVISION TO ARRANGE FOR A PRECONSTRUCTION MEETING 2 FULL BUSINESS DAYS PRIOR TO PROPOSED START OF CONSTRUCTION. CONTACT ONE CALL CENTER 48 HRS PRIOR TO EXCAVATION.
9. CONTRACT INSPECTOR WILL INSPECT ANY FACILITIES APPROVED BY THE DEPARTMENT. ALL OTHER REQUIREMENTS OF THE PERMITTING AGENCY SHALL BE IN ACCORDANCE WITH THEIR STANDARDS AND REQUIREMENTS.
10. WORK PERFORMED UNDER THIS PROJECT WILL NOT BE CONSIDERED AS COMPLETE UNTIL FINAL ACCEPTANCE OF THE SYSTEM BY THE DEPARTMENT AND UNTIL THE FOLLOWING DOCUMENTS ARE RECEIVED AND APPROVED BY THE DEPARTMENT:
 - a. EASEMENTS, IF REQUIRED
 - b. CONTRACTOR'S WAIVER AND RELEASE OF LIEN
 - c. ABSOLUTE BILL OF SALE
 - d. CONTRACTOR'S LETTER OF WARRANTY (I.E., LETTER AGREEMENT)
 - e. DEVELOPER'S CONTRACT BOND (I.E., CONTRACT AGREEMENT)
11. "RECORD DRAWING" PRINTS (24" X 36") SHOWING SPECIFIC LOCATIONS, DEPTH, ETC. OF ALL WATER AND SEWER FACILITIES AS LOCATED BY A LICENSED SURVEYOR & MAPPER, ALONG WITH PRINTS OF "RECORD DRAWINGS" WHICH HAVE BEEN SIGNED AND SEALED BY A REGISTERED SURVEYOR & MAPPER. (No. OF PRINTS: 3-FOR WATER, 4-FOR GRAVITY SEWER AND 5-FOR FORCE MAIN OR PUMP STATION PROJECTS). Submit all of final CAD Files required.
12. N/A: LETTER OF RELEASE REQUIRED FOR ALL WATER PROJECTS
13. BILL OF SALE SKETCH (96" X 11") FOR WATER AND SEWER, SEPARATELY
14. ALL NEW CONNECTIONS FROM EXISTING DEPARTMENT MAINS TO BE MADE BY DEPARTMENT FORCES ONLY. THE CONTRACTOR TO EXCAVATE AT REQUIRED LOCATIONS, PROVIDE AND INSTALL MATERIAL WITH FITTINGS, PRIOR TO TAP.
15. AN APPROVED PAVING AND DRAINAGE PLAN MUST BE SUBMITTED TO MDWASD FOR ALL NEW SUBDIVISIONS PRIOR TO APPROVAL OF WATER AND SEWER PERMIT PLANS, UPON REQUEST.
16. UNLESS OTHERWISE SPECIFIED, ALL TAPS 20 INCHES AND SMALLER FOR CONNECTIONS TO EXISTING MAINS WILL BE DONE BY DEPARTMENT FORCES. UNDER NO CIRCUMSTANCES WILL THE CONTRACTOR BE PERMITTED TO TAP EXISTING MAINS IN THE SIZE RANGE SPECIFIED ABOVE. THE TAPPING SLEEVE AND TAPPING VALVE ARE FURNISHED AND INSTALLED BY THE CONTRACTOR UNDER THE SUPERVISION OF THE INSPECTOR.

MIAMI-DADE COUNTY	ISSUE DATE	APPROVED BY	STANDARD DETAIL	CROSS REF.	SPEC. REF.
Water & Sewer Department	03/01/2010	V.F.C.	STANDARD REQUIREMENTS WATER AND SEWER CONSTRUCTION	GS	0.5
	07/20/2016	D.V.			
					SHEET 1 OF 2

1. AT THE COMPLETION OF ANY WATER AND SEWER JOB EITHER DONATION OR CONTRACT, THE CONTRACTOR SHALL SUBMIT:
 - a. RECORD DRAWING PRINTS WHICH HAVE BEEN SIGNED AND SEALED BY A FLORIDA LICENSED PROFESSIONAL SURVEYOR AND MAPPER (QTY. OF PRINTS AS REQUIRED BY THE DEPARTMENT).
2. "RECORD DRAWING" FORMAT:
 - a. 24" X 36" PRINTS
 - b. PDF FILE
 - c. CAD FILE (DWG OR DXF) ROTATED AND TRANSLATED TO STATE PLANE COORDINATES NAD 83 FLORIDA EAST ZONE
 - d. THE WORDS "RECORD DRAWING" IN LARGE LETTERS
 - e. TITLE BLOCK WITH DEPARTMENT DS, DW OR ER NUMBER AND PERTINENT INFORMATION
 - f. PREFERRED SCALE TO BE 1"= 40' HORIZONTALLY AND 1"= 4' VERTICALLY
 - g. STREET NOMENCLATURE
 - h. SEPARATE RECORD DRAWINGS FOR WATER AND SEWER
 - i. SEPARATE WATER AND SEWER PROFILE
 - j. STATIONING STARTING WITH 0+00 AT PERMANENT REFERENCE POINT (I.E. E, S, ETC.) OR AS SHOWN ON DESIGN PERMIT PLANS, AND TO RUN CONTINUOUSLY TO END OF MAIN
 - k. EASEMENTS, IF ANY, TIED TO PERMANENT REFERENCE POINT
 - l. IDENTIFY ALL CONTROL LINES (I.E. BLOC. LINE, PROPERTY LINE, R/W, ETC.)
 - m. ALL "PROPOSED" INFORMATION TO BE REMOVED FROM PRINTS, LEAVING ONLY RECORD DRAWING INFORMATION REFLECTED IN DRAWINGS
3. WATER "RECORD DRAWINGS" MUST INCLUDE:
 - a. PLANS SHOWING PIPE SIZE, MATERIAL AND OFFSET OF MAIN, DEFLECTIONS (IF ANY), STATION OF SERVICES, HYDRANTS, VALVES, FITTINGS, IF ANY, ALL IN STATE PLANE COORDINATES. UTILITY CROSSINGS SHALL BE CLEARLY IDENTIFIED AND LOCATED.
 - b. PROFILE SHOWING TOP OF GROUND AND TOP OF PIPE ELEVATIONS AT EVERY 100' STATION AND AT ANY CHANGE IN GRADE (WITH CORRESPONDING STATION), PIPE SIZE AND PIPE MATERIALS REFERENCED TO PLAN.
4. SEWER "RECORD DRAWINGS" MUST INCLUDE:
 - a. PLAN SHOWING MANHOLE NUMBER, PIPE SIZE AND PIPE MATERIAL OF PIPE, DEFLECTION, SLOPE OF GRAVITY SEWER, LOCATION OF LATERALS WITH REFERENCE TO MANHOLE AND CLEANOUTS.
 - b. THE NORTHERLY AND EASTERLY COORDINATES ON ALL FIELD OBTAINED MEASUREMENTS AND PROVIDED ON ALL RECORD DRAWING SUBMITTALS
 - c. PROFILE SHOWING MANHOLE NUMBER (AS PER PLAN), RIM AND INVERT ELEVATIONS (IF MORE THAN ONE INVERT, LABEL NORTH, SOUTH, ETC.), AND STATION STARTING AT 0+00 AT DOWNSTREAM MANHOLE.
5. FORCE MAIN "RECORD DRAWING" SAME AS WATER MAIN.
6. EACH RECORD DRAWING SHALL SHOW THE FLORIDA STATE PLANE COORDINATES (CURRENT READJUSTMENT) OF ALL THE MANHOLES AND VALVES AND OF AT LEAST TWO HORIZONTAL CONTROL POINTS PROPERLY IDENTIFIED AND LOCATED WITHIN THE PROJECT.

MIAMI-DADE COUNTY	ISSUE DATE	APPROVED BY	STANDARD DETAIL	CROSS REF.	SPEC. REF.
Water & Sewer Department	03/11/2009	V.F.C.	"RECORD DRAWING" REQUIREMENTS	GS	0.5
	07/20/2016	D.V.			
					SHEET 2 OF 2

HEALTH DEPARTMENT NOTES

(NOT A PART OF M-DWASD NOTES OR APPROVAL)

WATER MAIN HORIZONTAL SEPARATIONS

SEPARATIONS SHALL BE MEASURED OUTSIDE EDGE TO OUTSIDE EDGE BETWEEN WATER MAINS AND, STORM SEWERS, STORMWATER FORCE MAINS, OR RECLAIMED WATER LINES, SHALL BE 3 FT. MINIMUM.

BETWEEN WATER MAINS AND VACUUM TYPE SEWER PREFERABLY 10 FT. AND AT LEAST 3 FT. MINIMUM.

GRAVITY OR PRESSURE SANITARY SEWERS, WASTEWATER FORCE MAINS OR RECLAIMED WATER PREFERABLY 10 FT. AND AT LEAST 6 FT. MAY BE REDUCED TO 3 FT. WHERE BOTTOM OF WATER MAINS IS AT LEAST 6 INCHES ABOVE TOP OF SEWER.

10 FT. TO ANY PART OF ON-SITE SEWER TREATMENT OR DISPOSAL SYSTEM.

WATER MAIN VERTICAL SEPARATIONS

SEPARATIONS BETWEEN WATER MAINS AND GRAVITY SEWER, VACUUM TYPE SEWER, OR STORM SEWERS, TO BE PREFERABLY 12 INCHES, OR AT LEAST 6 INCHES ABOVE, OR AT LEAST 12 INCHES IF BELOW.*

PRESSURE SANITARY SEWER, WASTEWATER OR STORMWATER FORCE MAIN, OR RECLAIMED WATER, AT LEAST 12 INCHES ABOVE OR BELOW.*


* NOTE: CENTER 1-FULL LENGTH OF WATER MAIN PIPE AT CROSSINGS; ALTERNATIVELY ARRANGE PIPES SO JOINTS ARE AT LEAST 3 FEET FROM JOINTS IN VACUUM, STORM OR STORM FORCE MAINS. AT LEAST 6 FEET FROM JOINTS IN GRAVITY OR PRESSURE SEWERS, WASTEWATER FORCE MAINS OR RECLAIMED WATER.

RER-DERM WATER-SEWER GENERAL NOTES

1. A horizontal distance of at least 6 feet, and preferably 10 feet (outside to outside), shall be maintained between gravity or pressure sewer pipes and water pipes. The minimum horizontal separation can be reduced to 3 feet for vacuum-type sewers or for gravity sewers where the top of the sewer pipe is at least 6 inches below the bottom of the water pipe. When the above specified horizontal distance criteria cannot be met due to an existing underground facility conflict, smaller separations are allowed if one of the following is met:
 - a) The sewer pipes are designed and constructed equal to the water pipe and pressure tested at 150 psi.
 - b) The sewer is encased in a watertight carrier pipe or concrete.
 - c) The top of the sewer is at least 18 inches below the bottom of the water pipe.
2. A vertical distance of at least 12 inches (outside to outside) shall be maintained between any water and sewer mains with sewer pipes preferably crossing under water mains. The minimum vertical separation can be reduced to 6 inches for vacuum-type sewers or for gravity sewers where the sewer pipe is below the water main. The crossing shall be arranged so that all water main joints are at least 6 feet from all joints in gravity and pressure sewer pipes. This distance can be reduced to 3 feet for vacuum-type sewers. When the above specified vertical distance criteria cannot be met due to an existing underground facility conflict, smaller separations are allowed if one of the following is met:
 - a) The sewer pipes are designed and constructed equal to the water pipe and pressure tested at 150 psi.
 - b) The sewer is encased in a watertight carrier pipe or concrete.
3. Air release valves shall be provided at high points of new force main sanitary sewers.
4. Gravity sanitary sewers constructed within a public wellfield protection area shall be C-900 PVC or Ductile Iron Pipe. The maximum allowable exfiltration rate of gravity sanitary sewers constructed in a public wellfield protection area shall be:
 - a) Residential Land Uses. Fifty (50) gallons per inch pipe diameter per mile per day, based on a minimum two (2) hour test having a minimum of two (2) feet of positive head above the crown of the pipe.
 - b) Non-Residential Land Uses. Twenty (20) gallons per inch pipe diameter per mile per day, based on a minimum two (2) hour test having a minimum of two (2) feet of positive head above the crown of the pipe.
 - c) Any observed leaks or any obviously defective joints or pipes shall be replaced even when the total leakage is below that allowed.
5. The maximum allowable exfiltration rate of gravity sanitary sewers constructed outside a public wellfield protection area shall be one hundred (100) gallons per inch pipe diameter per mile per day, based on a minimum two (2) hour test having a minimum of two (2) feet of positive head above the crown of the pipe. Any observed leaks or any obviously defective joints or pipes shall be replaced even when the total leakage is below that allowed.
6. Forcemain sanitary sewers constructed within a public wellfield protection area shall be ductile iron, C-900 PVC, HDPE or reinforced concrete pressure sewer pipes.
7. The maximum allowable exfiltration/leakage rate of forcemain sanitary sewers shall be:
 - a) Ductile Iron, C-900 PVC, HDPE and PVC Pipe. The allowable leakage rate specified in American Water Works Association Standard (AWWAS) C600-82 at a test pressure of 100 psi for a duration of not less than two (2) hours.
 - b) Reinforced Concrete Pressure Pipe. Half (1/2) the allowable leakage rate specified in AWWA C600-82 at a test pressure of 100 psi for a duration of not less than two (2) hours.
 - c) Any observed leaks or any obviously defective joints or pipes shall be replaced even when the total leakage is below that allowed.
8. The contractor shall verify nature, depth, and character of existing underground utilities prior to start of construction.
9. In no case shall a contractor install utility pipes, conduits, cables, etc. in the same trench above an existing water or sewer pipe except where they cross.
10. If any area of the work site is found to contain buried solid waste and/or ground or ground water contamination, the following shall apply:
 - a) All work in the area shall follow all applicable safety requirements (e.g., OSHA, etc.) and notification must be provided to the appropriate agencies.
 - b) Immediately notify the Environmental Monitoring and Restoration Division (EMRD). The EMRD can be contacted at (305) 372-6700.
 - c) If contaminated soils and/or buried solid waste material is excavated during construction, then they require proper handling and disposal in accordance with the local, state and federal regulations. Be advised that the landfill owner/operator is the final authority on disposal and may have requirements beyond those provided by herein. If disposal within a Miami-Dade County owned landfill (Class I landfill) is appropriate and selected, please contact the Miami-Dade County Department of Solid Waste Management at (305) 594-6666 for information.
 - d) The reuse of contaminated soils that are not returned to the original excavation requires prior approval of a Soil Management Plan from the Environmental Monitoring and Restoration Division. The EMRD can be contacted at (305) 372-6700.
11. Pumps must comply with the National Electrical Code (NEC) requirements for Class I, Group D, Division 1 locations (Explosion Proof).
12. The contractor is advised that a Tree Removal/Relocation Permit may be required prior to the removal and/or relocation of tree resources. Prior to removing or relocating any trees, the Contractor shall notify the Tree and Forest Resources Section of DERM at (305) 372-6574 or via e-mail at: tree@miamidade.gov, or contact the municipality with tree ordinance jurisdiction to obtain any required permits. Those trees not interfering with the construction shall be protected in place in accordance with the provisions of Section 24-49.5 of the Miami-Dade Code.
13. Please note that the demolition, removal, and/or disturbance of existing underground utilities that contain asbestos-cement pipes (ACP) are subject to the provisions of 40 CFR-61 Subpart M. Therefore, pursuant to the provisions of 40 CFR-61.145, a NOTICE OF DEMOLITION OR ASBESTOS RENOVATION form must be filed with the Air Quality Management Division (AQMD) of DERM, at least ten (10) working days prior to starting of any work. Note that the backfilling and burial of crushed ACP would cause these locations to be considered active disposal sites and subject to 40 CFR-61.154, and 40 CFR-61.151 a year after project completion. Existing standard operating procedures, as well as applicable federal, state and local regulatory criteria, must be followed and implemented to minimize any potential release of fugitive emissions, especially during project construction activities. The AQMD can be contacted via email at asbestos@miamidade.gov or 305-372-6925.

Rev. 4/30/2018
If published regulations change any permitting or construction related forms and packages in application package per permit package package month 2017 for derm-derm official use use revised 2017 04/30/2018


NOT PART OF M-D WASD
NOTES NOR APPROVAL

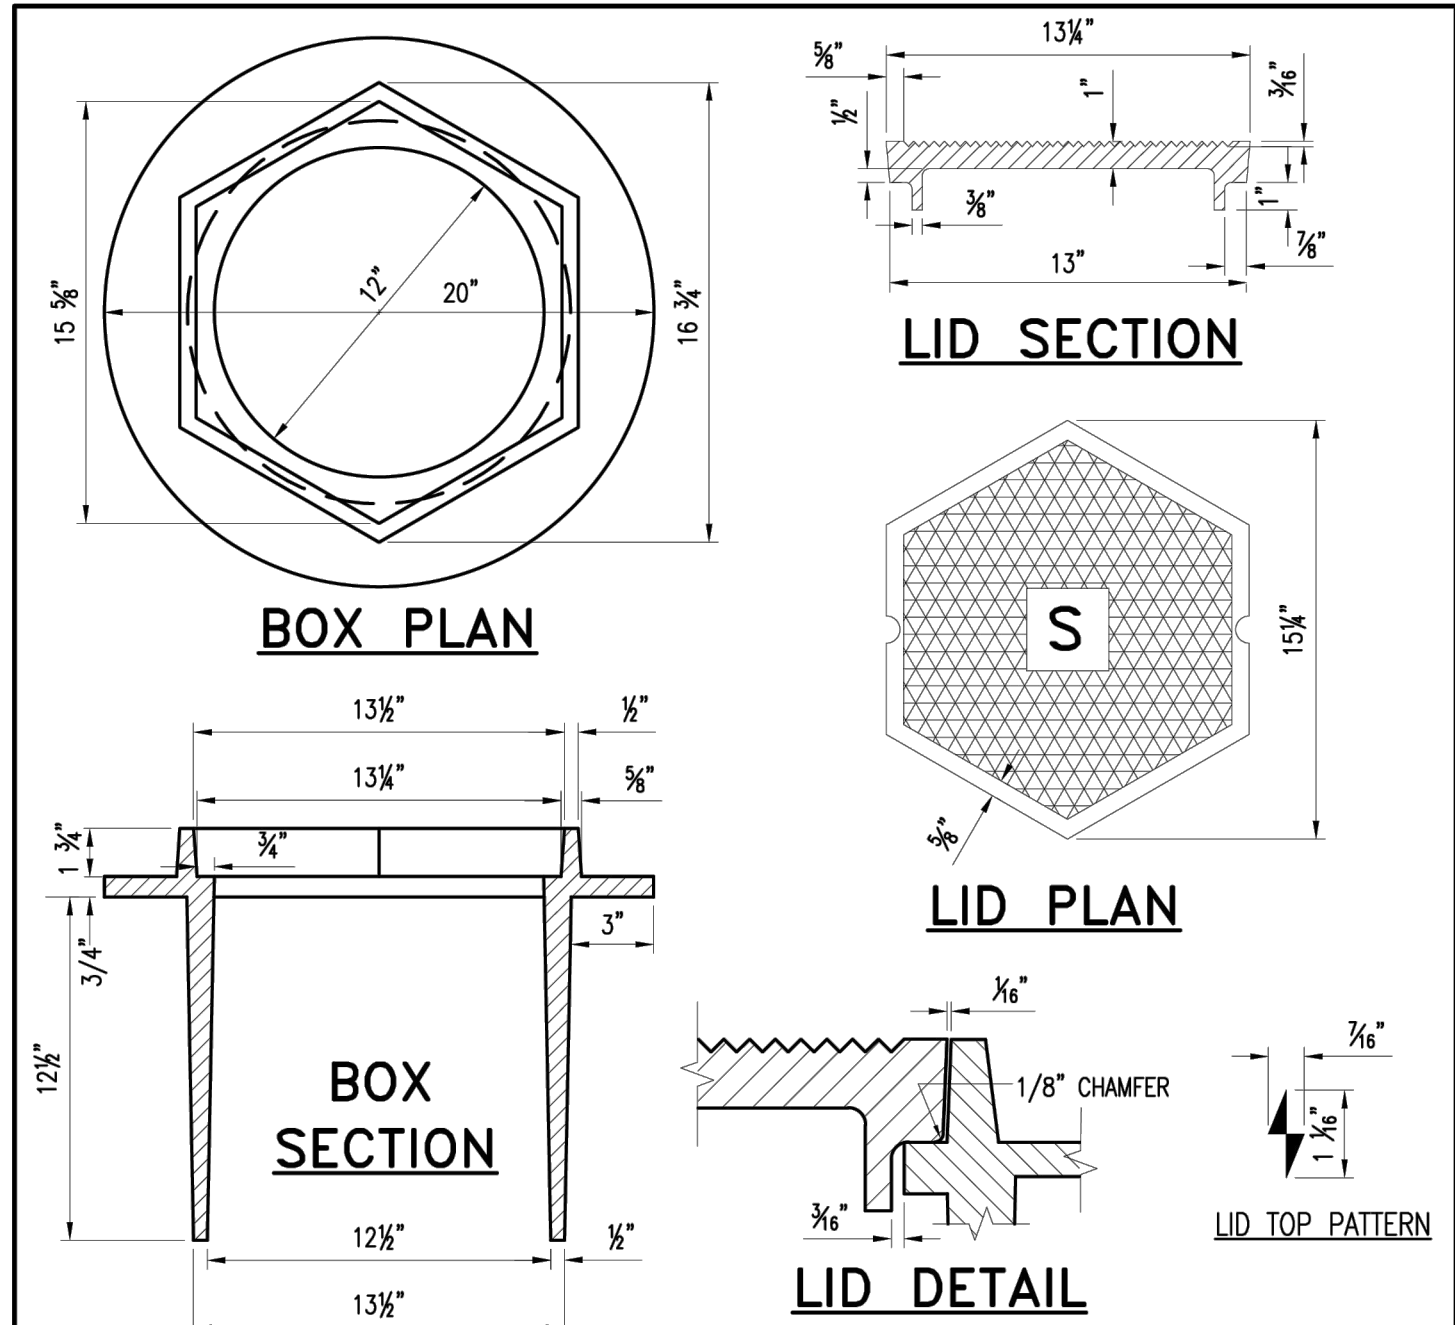

NOTES:

1. MACHINE FINISH BOTTOM OF COVER AND SEAT OF FRAME.
2. ALL DIMENSIONS ARE NET CASTING, NOT PATTERN.
3. FOUNDARY AND LOCATION SHALL BE CAST ON BOTTOM OF THE LID. (SEE WS 2.05)
4. MINIMUM WEIGHTS: RING: 134 LBS
COVER: 44 LBS


MIAMI-DADE COUNTY	ISSUE DATE	APPROVED BY	STANDARD DETAIL	CROSS REF.	SPEC. REF.
Water & Sewer Department	06/25/2015	J.B.F.	No. 53 C.I. VALVE BOX AND LID	SS	13.0
					SHEET 1 OF 1

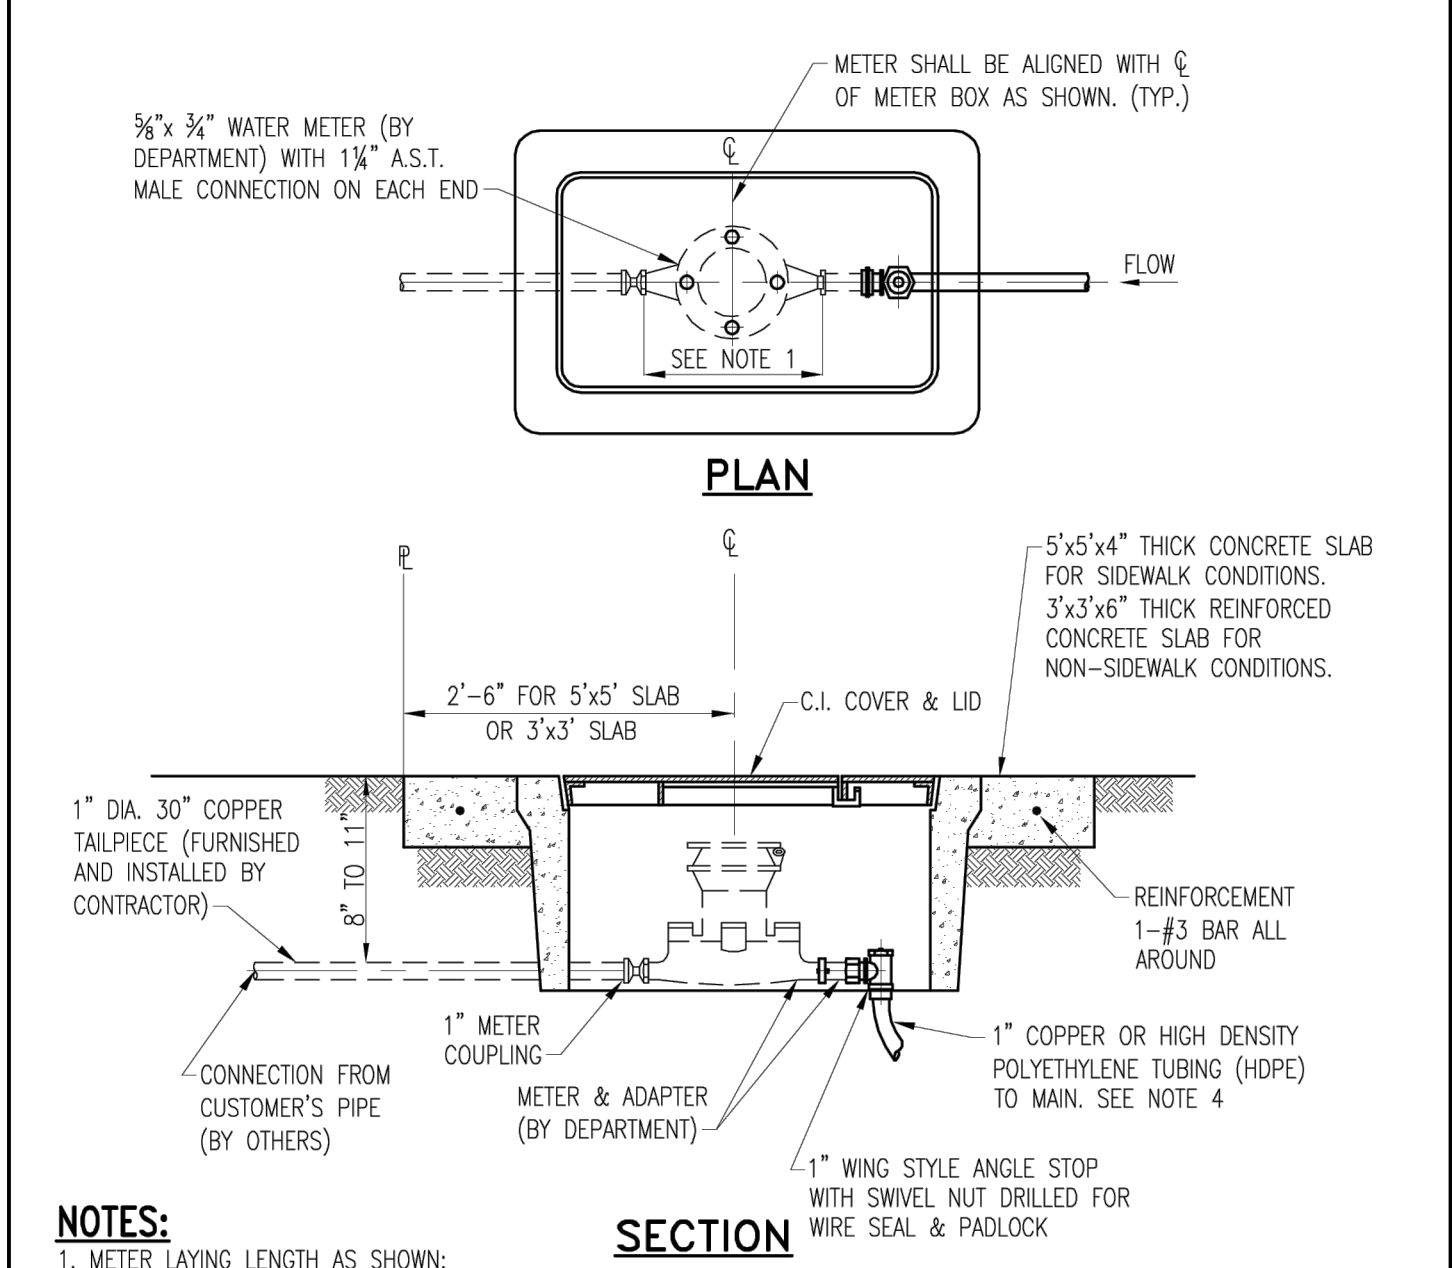

NOTES:

1. METER LAYING LENGTH AS SHOWN:
108" (OUTLET TO OUTLET) FOR 3/4" OR 1" METER (11" WITH GASKETS).
2. USE SINGLE METER BOX.
3. CONCRETE SLAB REINFORCEMENT SHALL HAVE 1-#3 BAR ALL AROUND.
4. USE 1" BLUE COLOR HDPE OR 1" COPPER TUBING FOR POTABLE WATER SERVICE. USE ONLY 1" PURPLE COLOR HDPE (NO COPPER ALLOWED) FOR RECLAIMED WATER SERVICE.
5. METERS WILL NOT BE INSTALLED IF THE METER BOX IS IN A DRIVING SURFACE.
6. WHEN USING 1" HDPE SERVICE A TEN GAUGE (BLUE (PURPLE FOR RECLAIMED WATER) DIRECT BURY STANDARD COPPER TRACE WIRE IS TO BE TAPED CONTINUOUSLY WITH POLY OR DUCT TAPE TO THE SERVICE FOR LOCATION PURPOSES. WIRE SHALL BE ATTACHED TO WATER MAIN WIRE MUST EXTEND INTO METER BOX.
7. IF USED FOR RECLAIMED WATER, THE COVER SHALL BE PERMANENTLY EMBOSSED WITH THE WORDING: "RECLAIMED WATER-DO NOT DRINK-NO BEER-PA BOUT".
8. ALL SPACER TUBES AND TAILPIECES SHALL BE FURNISHED AND INSTALLED BY CONTRACTOR.
9. REPAIRS TO SLAB AND METER ARE PROHIBITED.

MIAMI-DADE COUNTY	ISSUE DATE	APPROVED BY	STANDARD DETAIL	CROSS REF.	SPEC. REF.
Water & Sewer Department	06/01/2008	V.F.C.	SINGLE METER BOX INSTALLATION	WS	2.10
					SHEET 1 OF 3

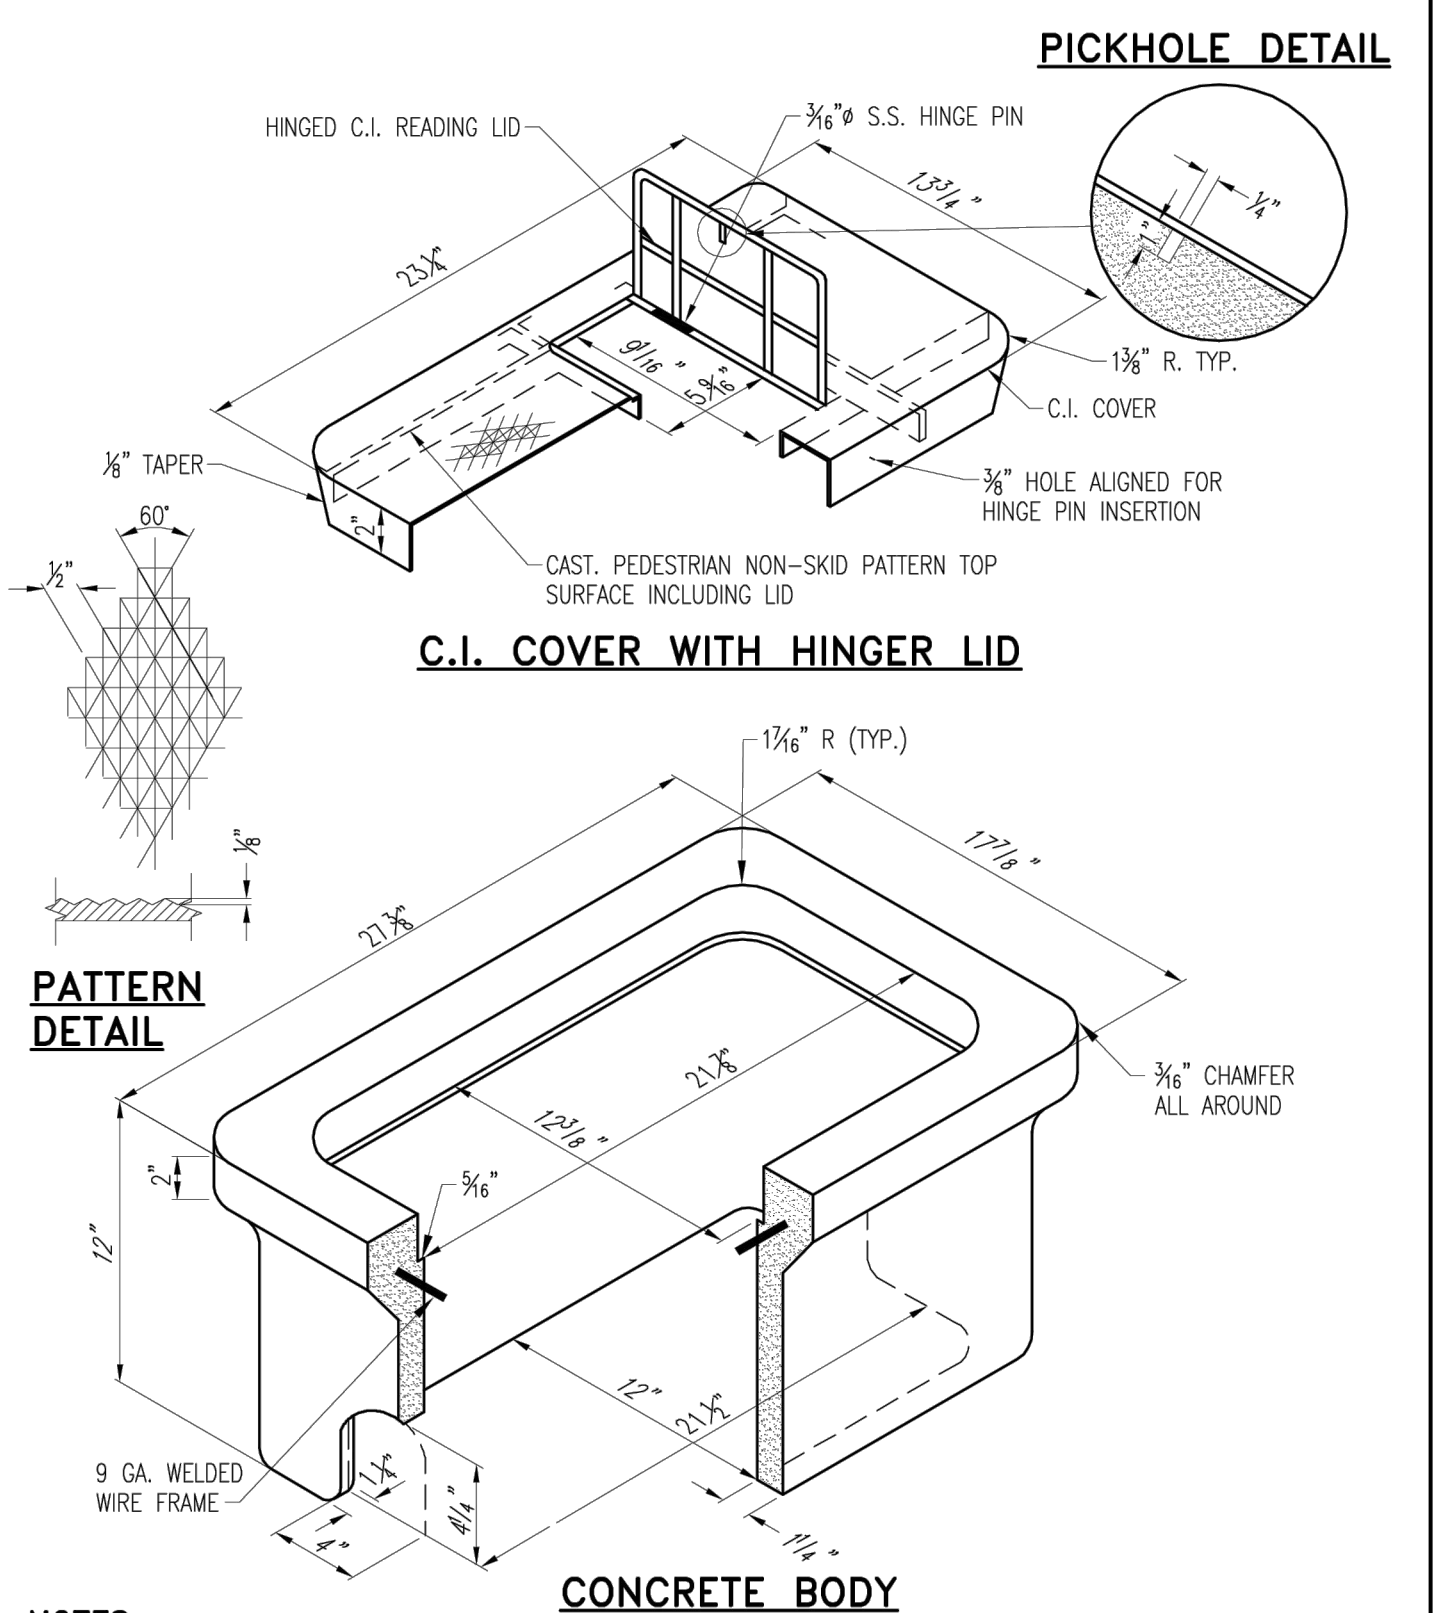

NOTES:

1. SOME DIMENSIONS MAY VARY WITH DEPARTMENT APPROVAL.
LID WT. - MAX. 53 LBS., MIN. 42 LBS.
2. METERS WILL NOT BE INSTALLED IF THE METER BOX IS IN A DRIVING SURFACE.

MIAMI-DADE COUNTY	ISSUE DATE	APPROVED BY	STANDARD DETAIL	CROSS REF.	SPEC. REF.
Water & Sewer Department	06/01/2008	V.F.C.	SINGLE METER BOX DETAIL	WS	2.10
					SHEET 2 OF 3

MDWASD AGREEMENT # _____

PROJECT LEAD & CIVIL ENGINEERING:

301 EAST ATLANTIC BLVD.
FOURMANS BEACH, FL 33060
PH: (954) 788-3400
Florida Engineering Business License: CA7928
Florida Surveyor and Mapper Business License: LB6660
Florida Landscape Architecture Business License: LC26000457

LANDSCAPE ARCHITECT:

801 INTERNATIONAL PARKWAY
LAKE MARY, FL 32746
407.871.9807
MKSSTUDIOS.COM

ARCHITECT:

WANNEMACHER, JENSEN ARCHITECTS
815 NORTHWEST 57 AVE. SUITE 219
MIAMI, FLORIDA 33126
727-822-5568
WJARC.COM AAO002277

MECHANICAL, PLUMBING, & ELECTRICAL ENGINEERING:

5301 WATERFORD DISTRICT DR.
SUITE 750
954-421-1944
SGMENGINEERING.COM CA-0006208

REVISIONS

NO.	DESCRIPTION	DATE

PRELIMINARY PLAN
NOT FOR CONSTRUCTION

THESE PLANS ARE NOT FULLY PERMITTED
AND ARE SUBJECT TO REVISIONS MADE
DURING THE PERMITTING PROCESS.
RESPONSIBILITY FOR THE USE OF THESE
PLANS PRIOR TO OBTAINING PERMITS FROM
ALL AGENCIES HAVING JURISDICTION OVER
THE PROJECT WILL FALL SOLELY UPON THE
USER.

ISSUE DATE: 08/12/2024

DESIGNED BY: DS

DRAWN BY: HA

CHECKED BY: TD

CLIENT

VILLAGE OF
PINECREST
PINECREST PARKS & RECREATION

PROJECT

GARY MATZNER
PARK

SHEET TITLE

WATER AND SEWER
DETAILS

SHEET NUMBER

CU-501

KEITH PROJECT
NUMBER

13861.00

Plotted by: dslalzar On 8/30/2024 6:28 PM
Drawing name: K:\13861.00 - Gary Matzner Park Design - Village of Pinecrest\Engineering\Cadd\13861.00-CU-501.dwg
STATUS: 60% CONSTRUCTION DOCUMENTS