


E

D

C


B

A

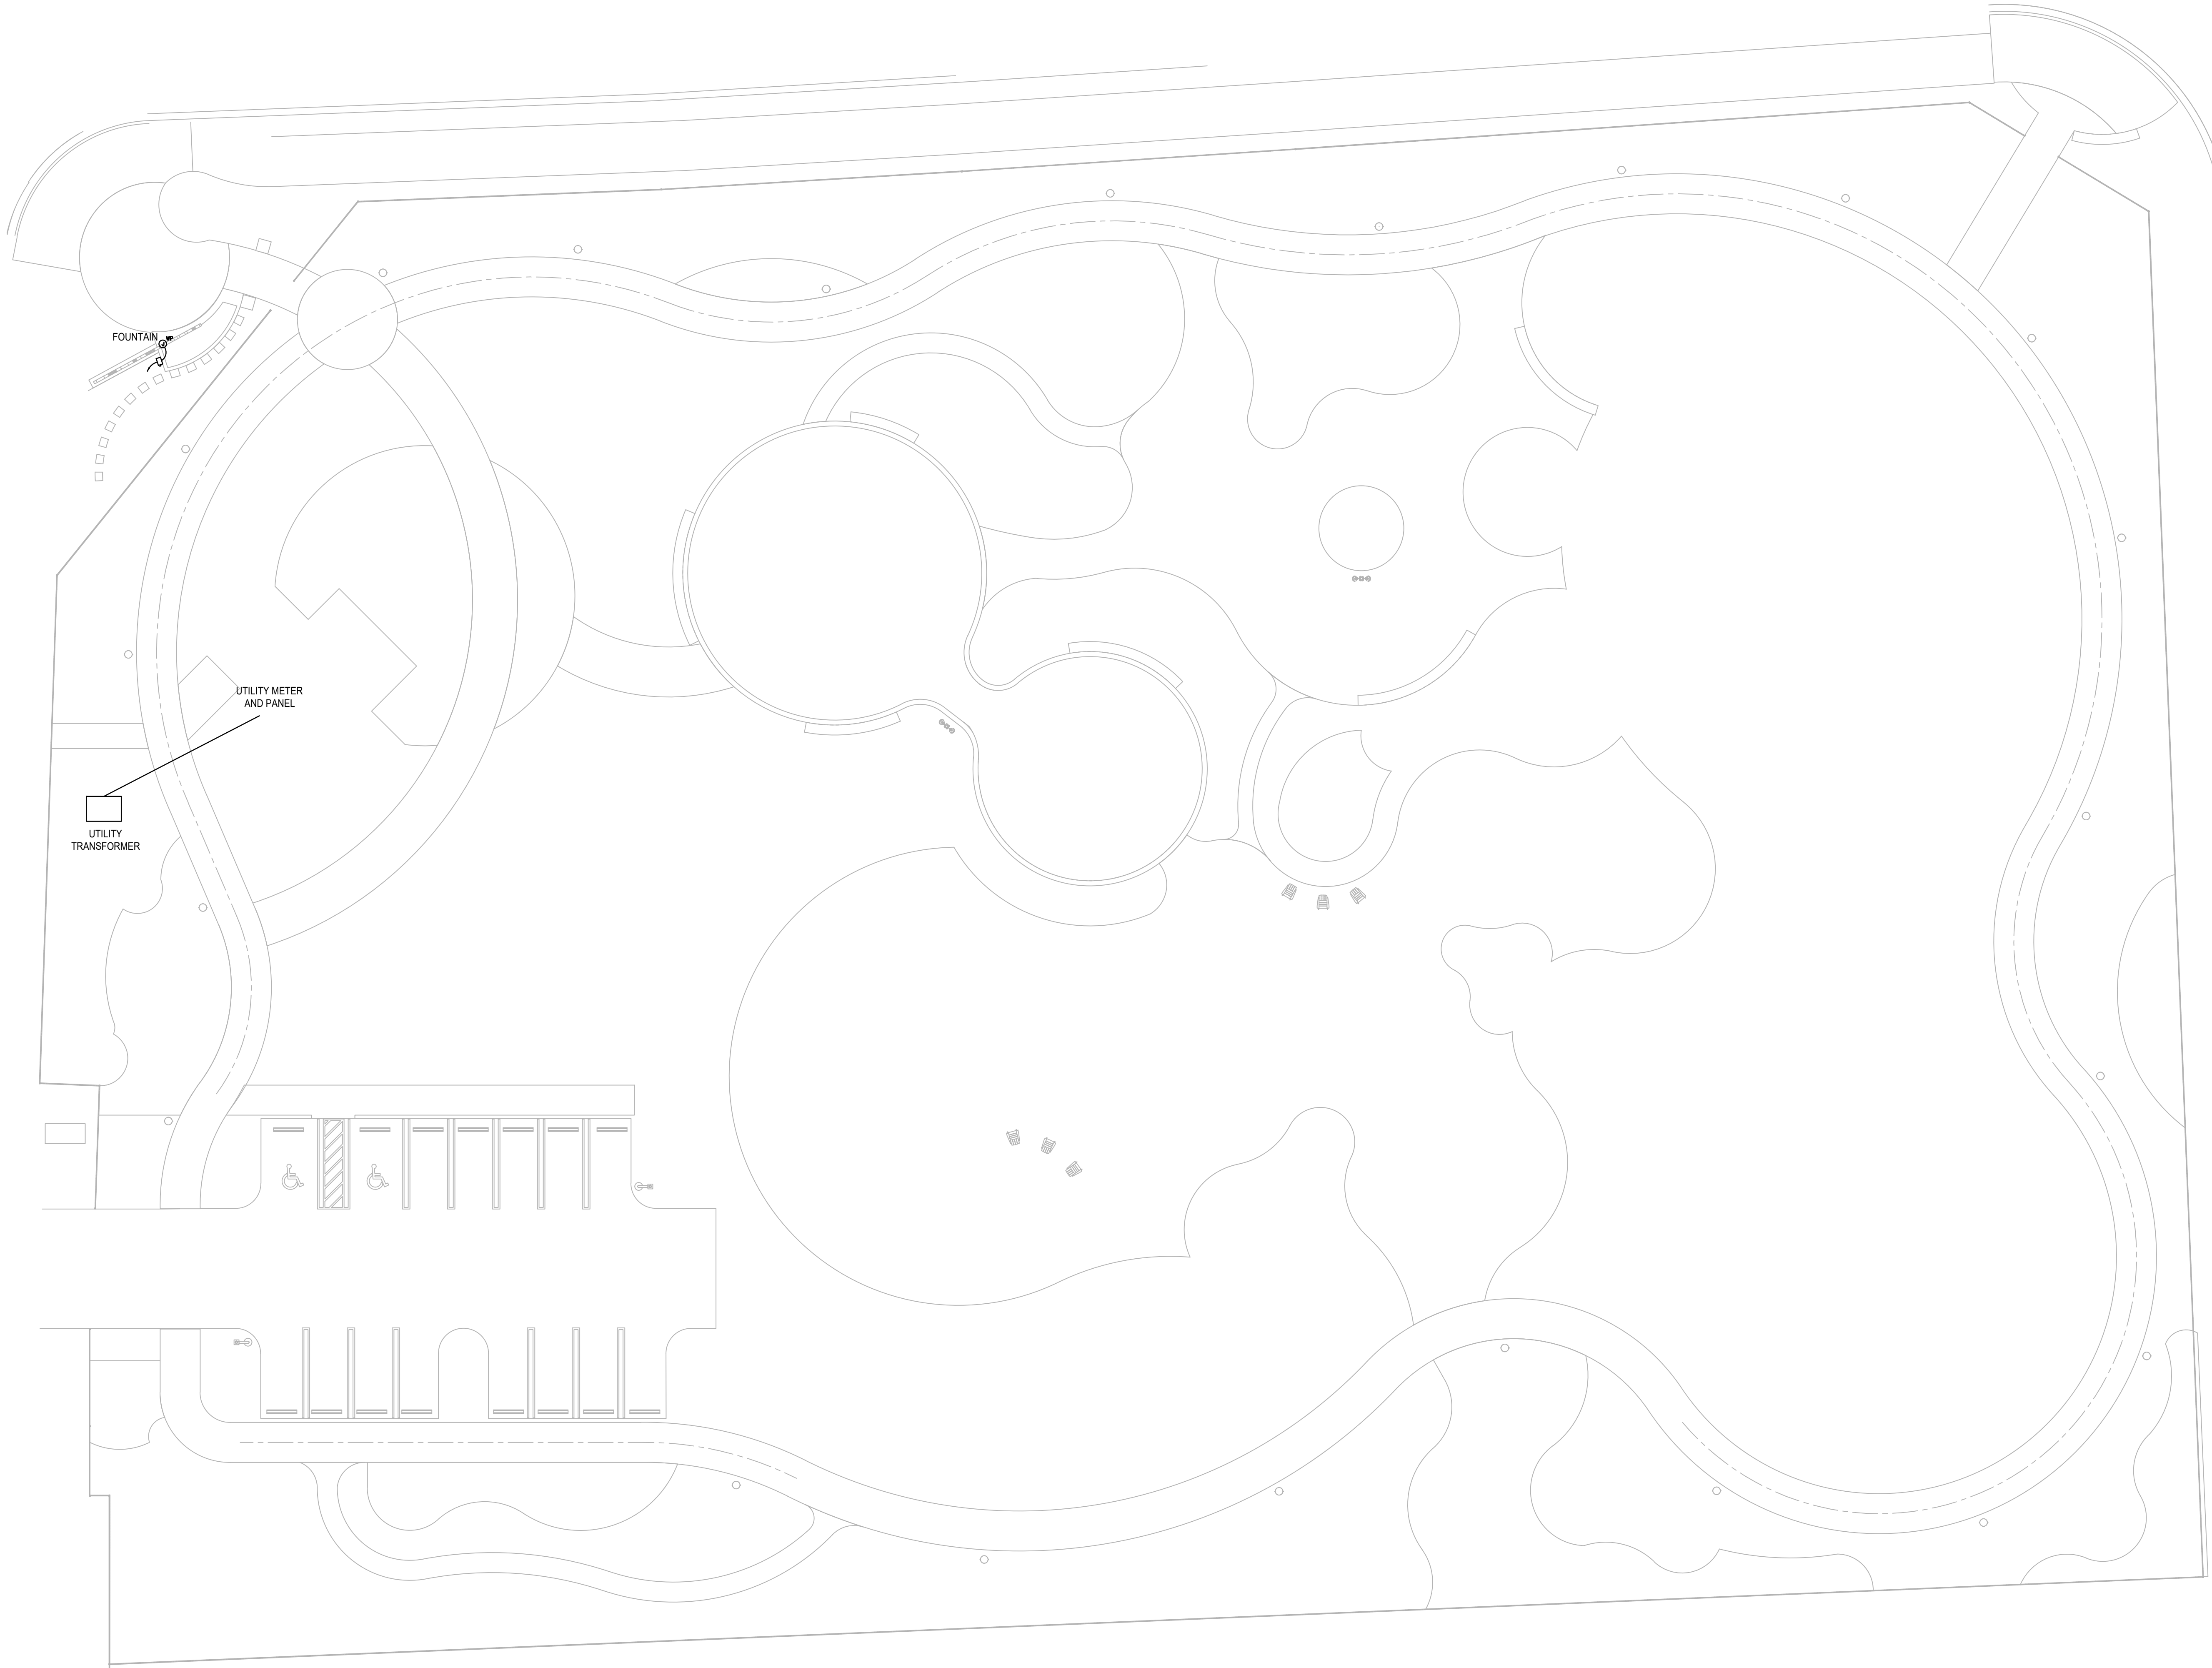

ELECTRICAL SITE PLAN

SCALE: 1/16"=1'-0"

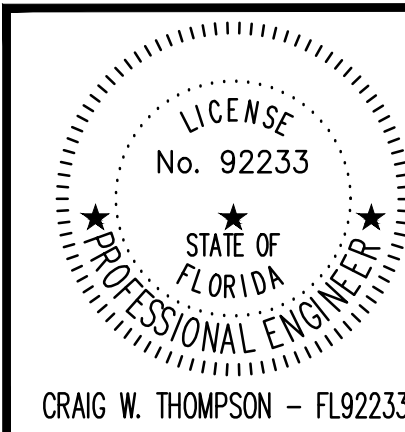

SGM
ENGINEERING

SGM #:
2024-256

935 LAKE BALDWIN LANE
ORLANDO, FL 32814
TEL: 407-767-5188
FAX: 407-767-5772
CA-00006208

WWW.SGMENGINEERING.COM
COPYRIGHT © 2024 SGM ENGINEERING, INC.

PROJECT LEAD
& CIVIL ENGINEERING:



301 EAST ATLANTIC BLVD.
POMPAHO BEACH, FL 33060
PH: (954) 788-3400
Florida Engineering Business License: CA7928
Florida Surveyor and Mapper Business License: LB6860
Florida Landscape Architecture Business License: LC26000457

LANDSCAPE ARCHITECT:




801 INTERNATIONAL PARKWAY
LAKE MARY, FL 32746
407.871.9607
MKSKSTUDIOS.COM

ARCHITECT:



WANNEMACHER, JENSEN ARCHITECTS
815 NORTHWEST 57 AVE. SUITE 219
MIAMI, FLORIDA 33126
727-822-5568
WJARC.COM AA0002277

MECHANICAL, PLUMBING,
& ELECTRICAL ENGINEERING:

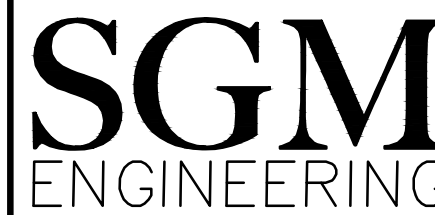

5301 WATERFORD DISTRICT DR.
SUITE 750
954-421-1944
SGMENGINEERING.COM CA-00006208

REVISIONS

NO.	DESCRIPTION	DATE

**PRELIMINARY PLAN
NOT FOR CONSTRUCTION**
THESE PLANS ARE NOT FULLY PERMITTED
AND ARE SUBJECT TO REVISIONS MADE
DURING THE PERMITTING PROCESS.

ISSUE DATE: XX/XX/20

DESIGNED BY: XXX

DRAWN BY: XXX

CHECKED BY: XXX

THOMAS F. DONAHUE, P.E.
FLORIDA REG. NO. 60529
(FOR THE FIRM)

CLIENT
**VILLAGE OF
PINECREST**
PINECREST PARKS & RECREATION



PROJECT

SHEET TITLE

ELECTRICAL
SITE PLAN

SHEET
NUMBER E101

KEITH PROJECT
NUMBER 13861.00

STATUS: PRELIMINARY