


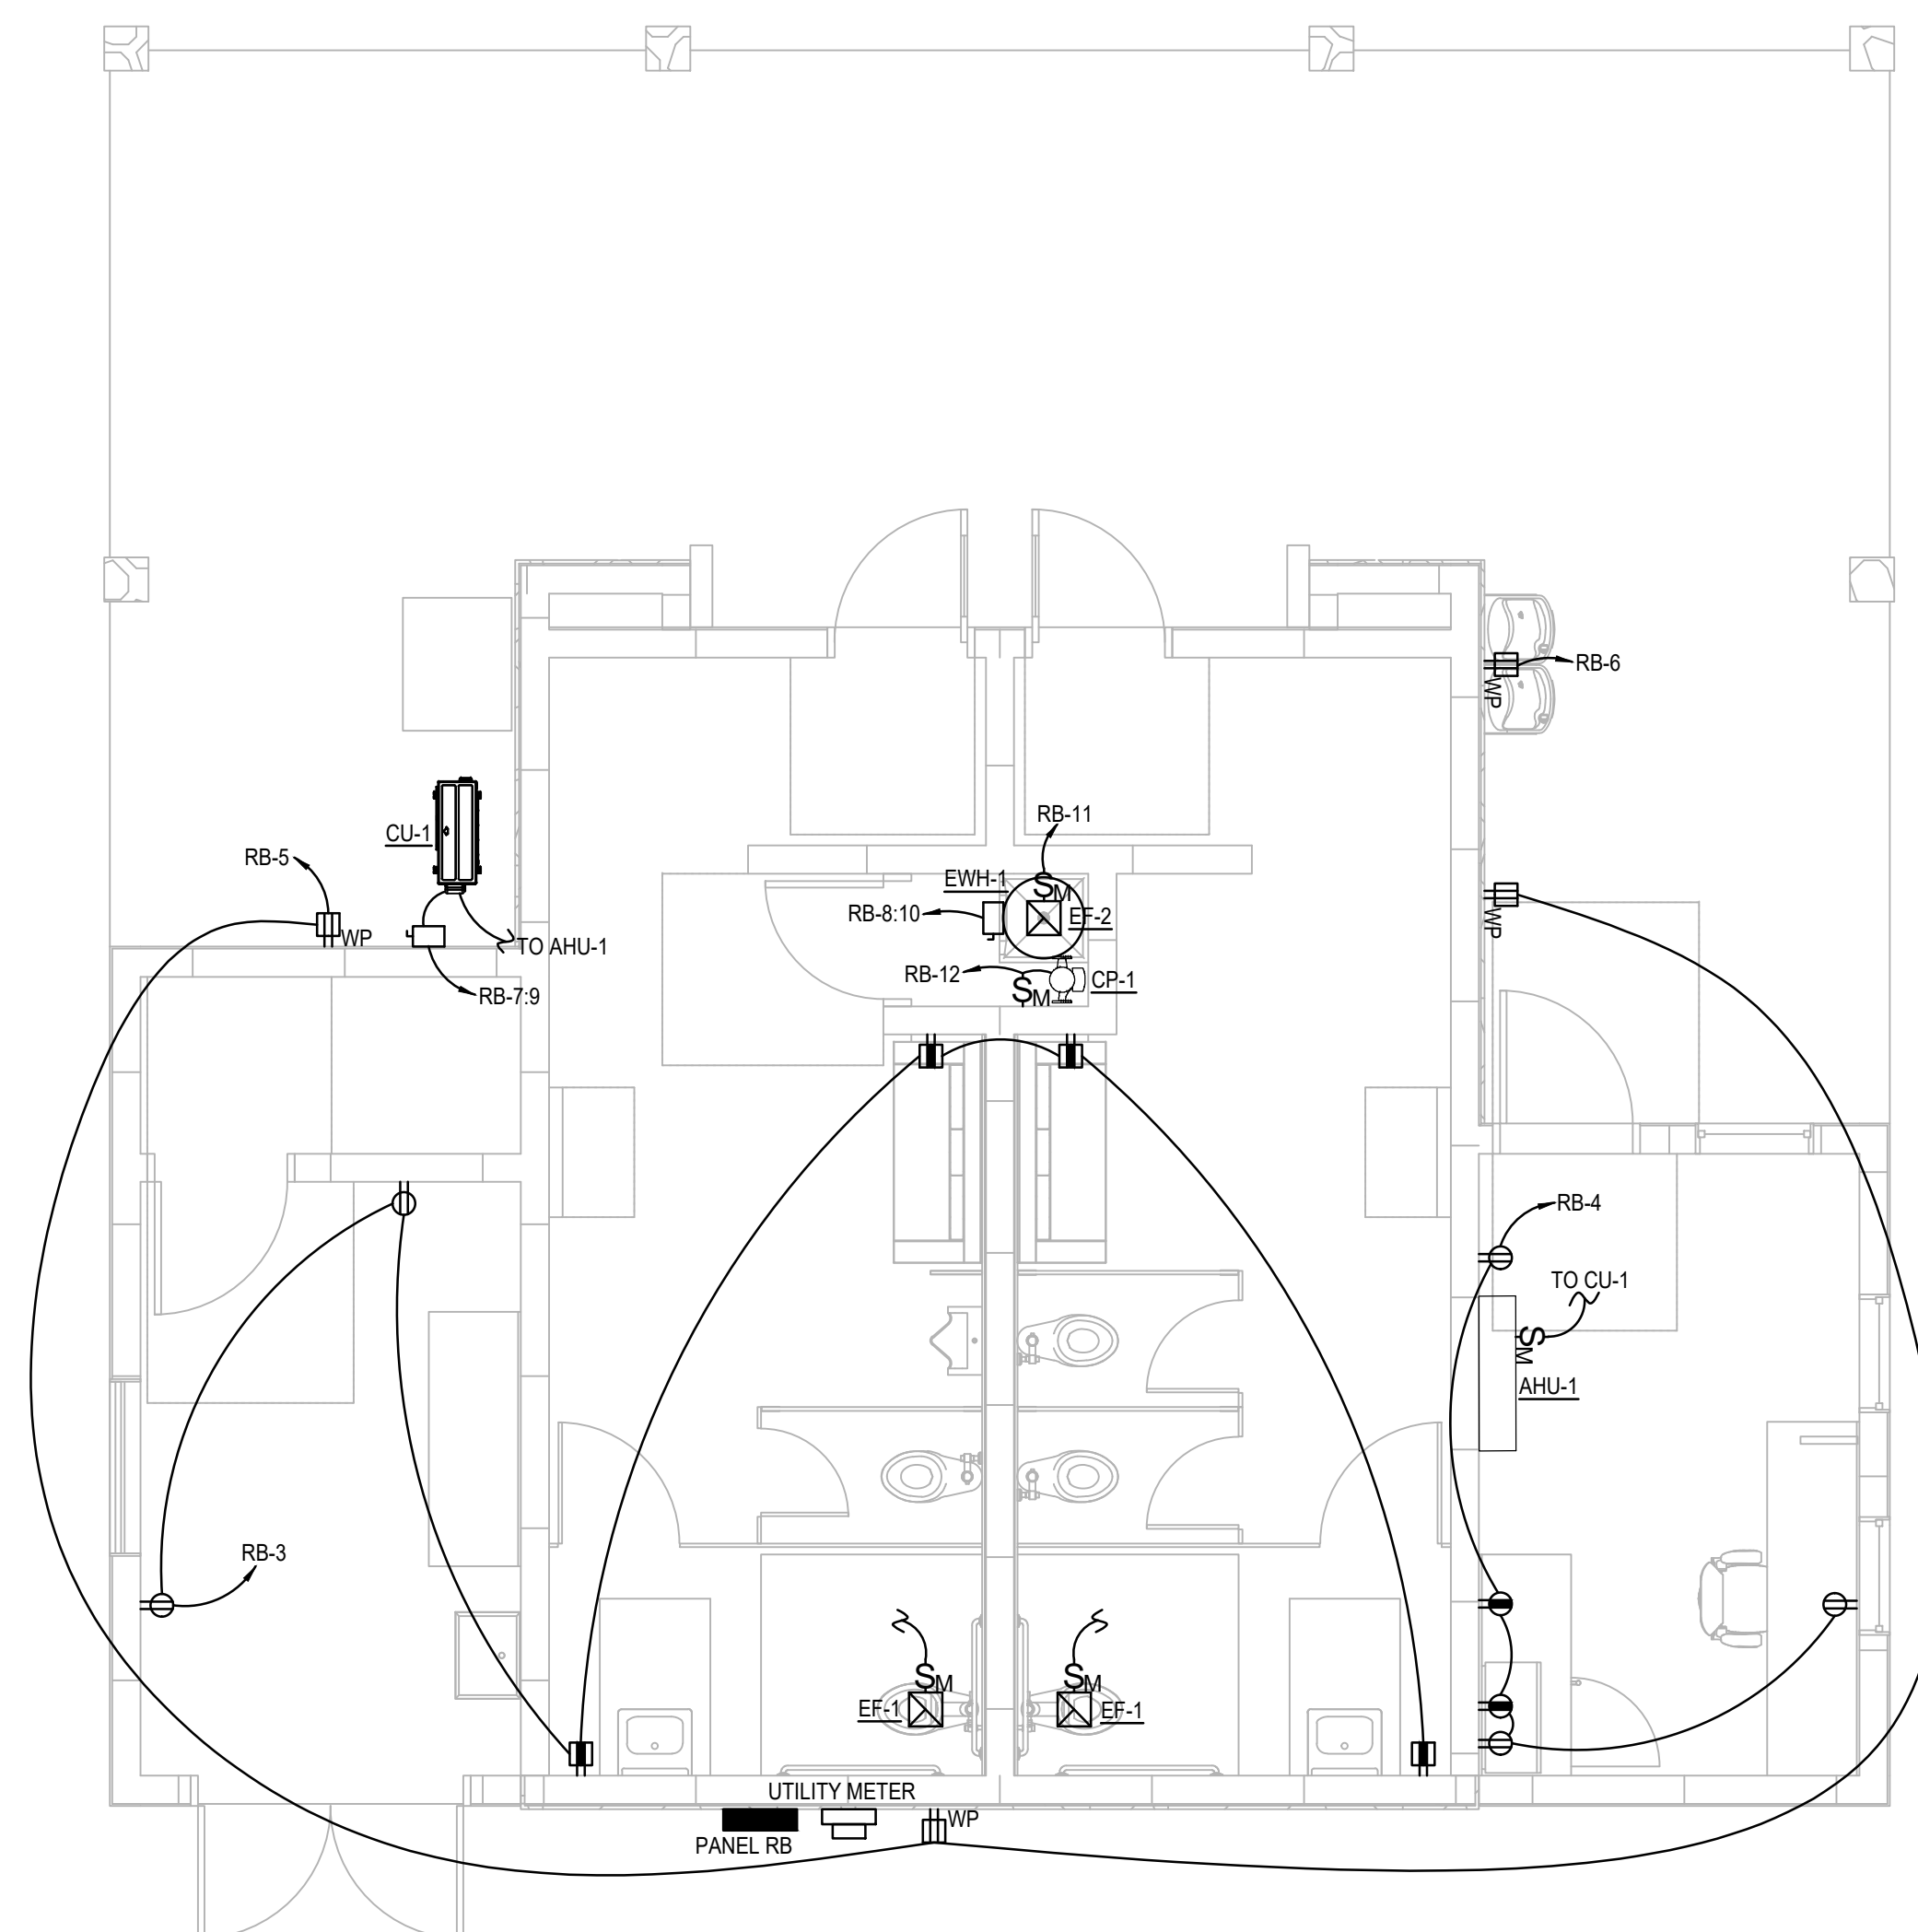

SCALE: 1/4"=1'-0"

PROJECT LEAD & CIVIL ENGINEERING:  KEITH 301 EAST ATLANTIC BLVD. POMPANOE BEACH, FL 33060 PH: (954) 768-5400 Florida Engineering Business License: CA7928 Florida Surveyor and Mapper Business License: LB18660 Florida Landscape Architecture Business License: LC20600457	LANDSCAPE ARCHITECT:  MKS K 801 INTERNATIONAL PARKWAY LAKE HAWRY, FL 32746 407 871 9607 MKSSTUDIOS.COM
ARCHITECT:  WANNEMACHER JENSEN ARCHITECTS 815 NORTHWEST 57 AVENUE SUITE 219 MIAMI, FLORIDA 33126 727-822-5566 WJARC.COM AA0002277	
Mechanical, Plumbing, & ELECTRICAL ENGINEERING:  SGM ENGINEERING 5301 WATERFORD DISTRICT DR. SUITE 750 954-421-1944 SGMENGEERING.COM CA-00006208	

[illegible]

**PRELIMINARY PLAN
NOT FOR CONSTRUCTION**
THESE PLANS ARE NOT FULLY PERMITTED
AND ARE SUBJECT TO REVISIONS MADE
DURING THE PERMITTING PROCESS.

ISSUE DATE:	XX/XX/20
DESIGNED BY:	XXX
DRAWN BY:	XXX
CHECKED BY:	XXX

THOMAS F. DONAHUE, P.E.
FLORIDA REG. NO. 60529
(FOR THE FIRM)

CLIENT
**VILLAGE OF
PINECREST**
PINECREST PARKS & RECREATION



PROJECT

SHEET TITLE

ELECTRICAL POWER AND LIGHTING PLANS

SHEET
NUMBER E301

KEITH PROJECT NUMBER	13861.00
-------------------------	----------

STATUS: PRELIMINARY