

 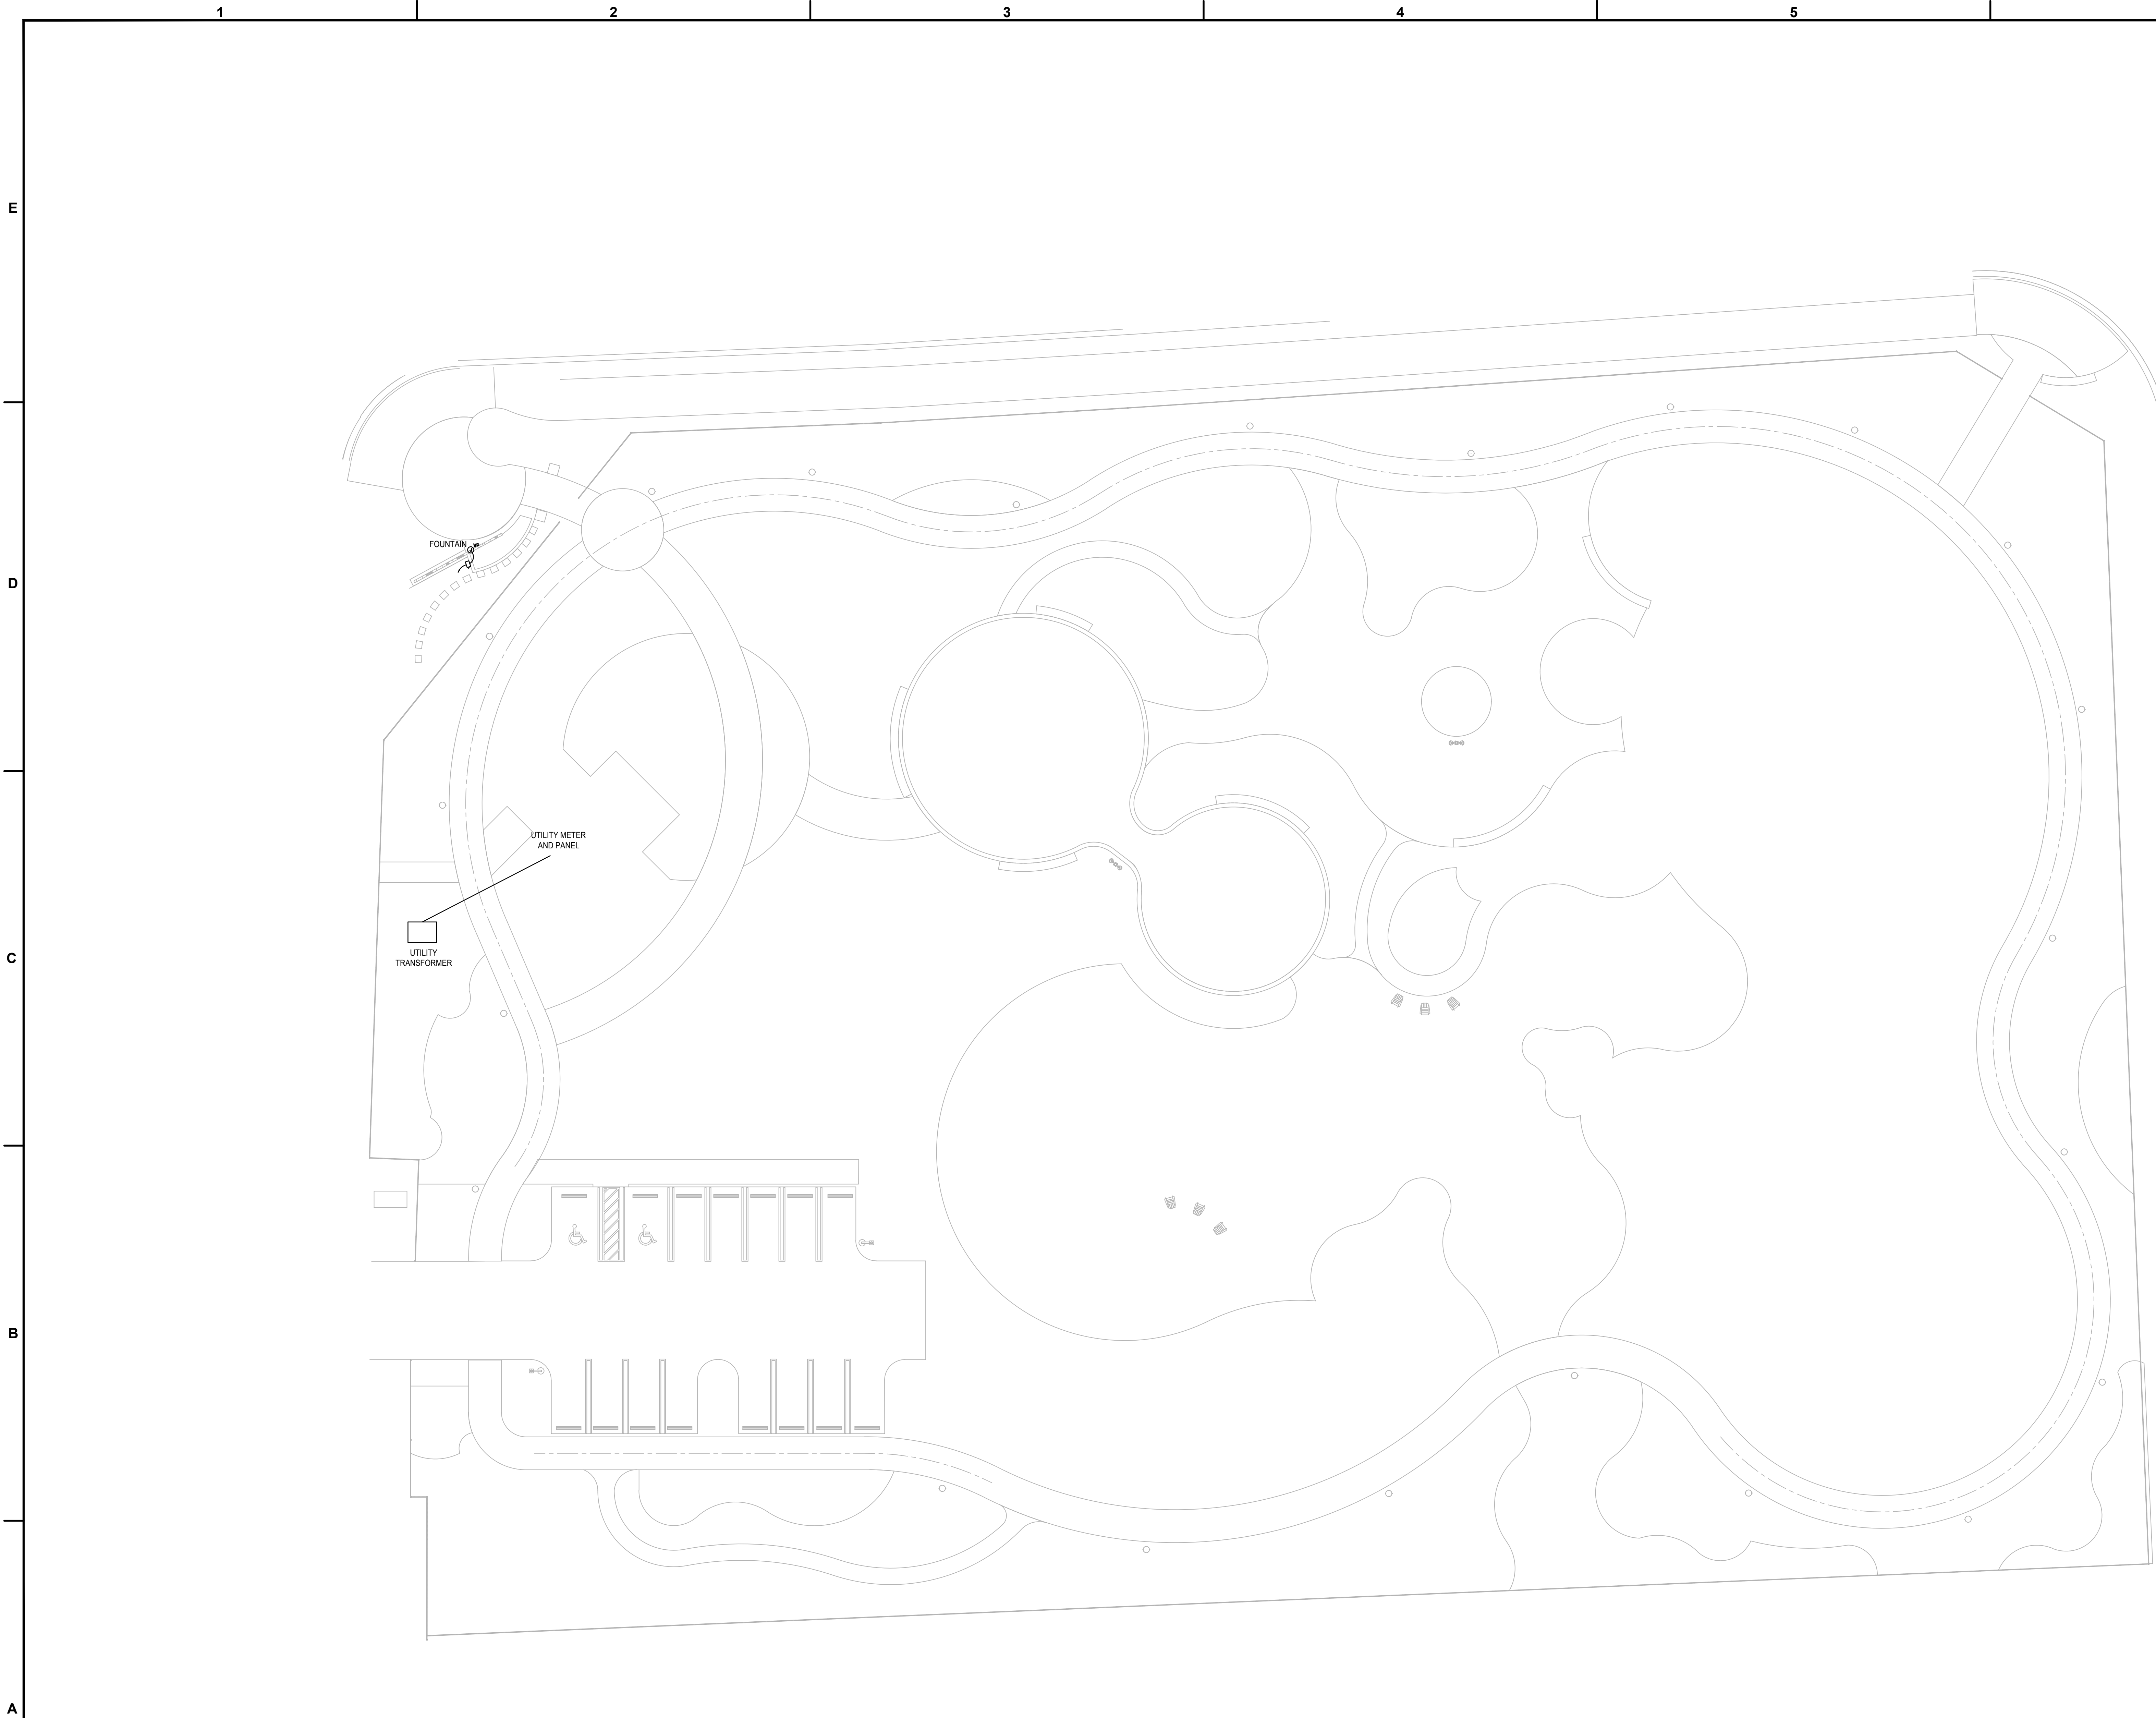


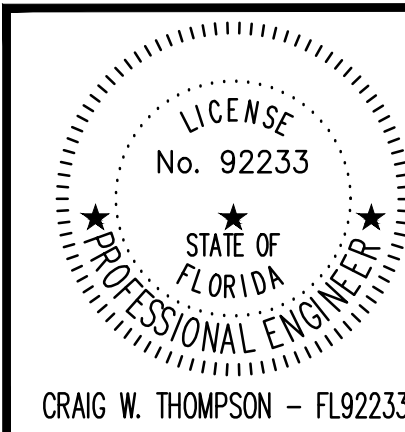

ELECTRICAL SITE PLAN

SCALE: 1/16"=1'-0"



SGM
ENGINEERING

935 LAKE BALDWIN LANE
ORLANDO, FL 32814
TEL: 407-767-5188
FAX: 407-767-5772
CA-00006208

SGM #:
2024-256

WWW.SGMENGINEERING.COM
COPYRIGHT © 2024 SGM ENGINEERING, INC.

PROJECT LEAD
& CIVIL ENGINEERING:

KEITH
301 EAST ATLANTIC BLVD.
POMPANNO BEACH, FL 33060
PH: (954) 788-3400
Florida Engineering Business License: CA7928
Florida Surveyor and Mapper Business License: LB6860
Florida Landscape Architecture Business License: LC26000457

LANDSCAPE ARCHITECT:

MKSK
801 INTERNATIONAL PARKWAY
LAKE MARY, FL 32746
407.871.9607
MKSKSTUDIOS.COM

ARCHITECT:

WA
WANNEMACHER, JENSEN ARCHITECTS
815 NORTHWEST 57 AVE. SUITE 219
MIAMI, FLORIDA 33126
727-822-5568
WJARC.COM AA0002277

MECHANICAL, PLUMBING,
& ELECTRICAL ENGINEERING:

SGM
ENGINEERING
5301 WATERFORD DISTRICT DR.
SUITE 750
954-421-1944
SGMENGINEERING.COM CA-00006208

REVISIONS		
NO.	DESCRIPTION	DATE

**PRELIMINARY PLAN
NOT FOR CONSTRUCTION**
THESE PLANS ARE NOT FULLY PERMITTED
AND ARE SUBJECT TO REVISIONS MADE
DURING THE PERMITTING PROCESS.

ISSUE DATE:

XX/XX/20

DESIGNED BY:

XXX

DRAWN BY:

XXX

CHECKED BY:

XXX

THOMAS F. DONAHUE, P.E.
FLORIDA REG. NO. 60529
(FOR THE FIRM)

CLIENT

**VILLAGE OF
PINECREST**
PINECREST PARKS & RECREATION

PROJECT

SHEET TITLE

ELECTRICAL
SITE PLAN

SHEET
NUMBER

E101

KEITH PROJECT
NUMBER

13861.00

STATUS: PRELIMINARY

Drawing name: G:\PROJECT FILES\2024\256 Village of Pinecrest Park\Drawings\1600-E101-2024256.dwg

Plotted by: robertb On: 8/9/2024 10:35 AM