

E

D


C

B

A


PLAN KEY NOTES:

1. PROVIDE 1" DIA. CONDENSATE DRAIN LINE. ROUTE FROM AHU, BELOW GRADE, BEYOND EXTERIOR WALL AND INTO THE LANDSCAPE AREA. USE TURNED DOWN ELBOW. TERMINATE ELBOW MIN. 6" ABOVE EXTERIOR GRADE. TERMINATE AT LEAST 1FT FROM EXTERIOR WALL. SEE DETAIL ON SHEET M701. PROVIDE MIN. 1/2" INSULATION WHERE INSIDE BUILDING AND WALLS.
2. PROVIDE REFRIGERANT LINES. ROUTE FROM AHU BELOW GRADE IN A SLEEVE PIPE TO EXTERIOR CONDENSER; REFER TO SHEET M801 FOR DETAIL. WHERE REFRIGERANT LINE RUN EXCEEDS 80 EQUIV FEET HORIZONTALLY OR 20 EQUIV FEET VERTICALLY, SIZE REFRIGERANT LINES PER CU MANUFACTURER'S RECOMMENDATIONS FOR THE SPECIFIC LENGTH INVOLVED. ALSO PROVIDE ACCESSORIES AS RECOMMENDED BY MANUFACTURER. FOLLOW THE MANUFACTURER'S RECOMMENDATIONS IN LONG LINE APPLICATION GUIDELINE.
3. PROVIDE AND MOUNT AHU AS INDICATED IN DETAIL ON DRAWING M701.
4. PROVIDE AND MOUNT EXHAUST FAN WITH BACKDRAFT DAMPER IN CEILING. ROUTE GALVANIZED STEEL EXHAUST DUCT UP TO ROOF (8" DUCT FOR EF-1 AND EF-3, AND 4" DUCT FOR EF-2) AND TERMINATE WITH ROOF VENT CAP. PROVIDE WITH BIRD SCREEN AND BACKDRAFT DAMPER.
5. PROVIDE AND MOUNT CU'S ON 4" THICK CONCRETE PADS. PAD DIMENSIONS SHALL EXCEED CU DIMENSIONS BY 6" ON ALL SIDES AND SHALL ALLOW FOR REFRIGERANT PIPING STUB-UP. PLACE CU'S AWAY FROM ROOF DRIP LINE. PROVIDE MANUFACTURER'S RECOMMENDED CLEARANCES. COORDINATE CLOSELY WITH LANDSCAPING PLANS AND ARCHITECTURAL DETAILS. REFER TO SHEET M701 FOR ANCHORING DETAIL.

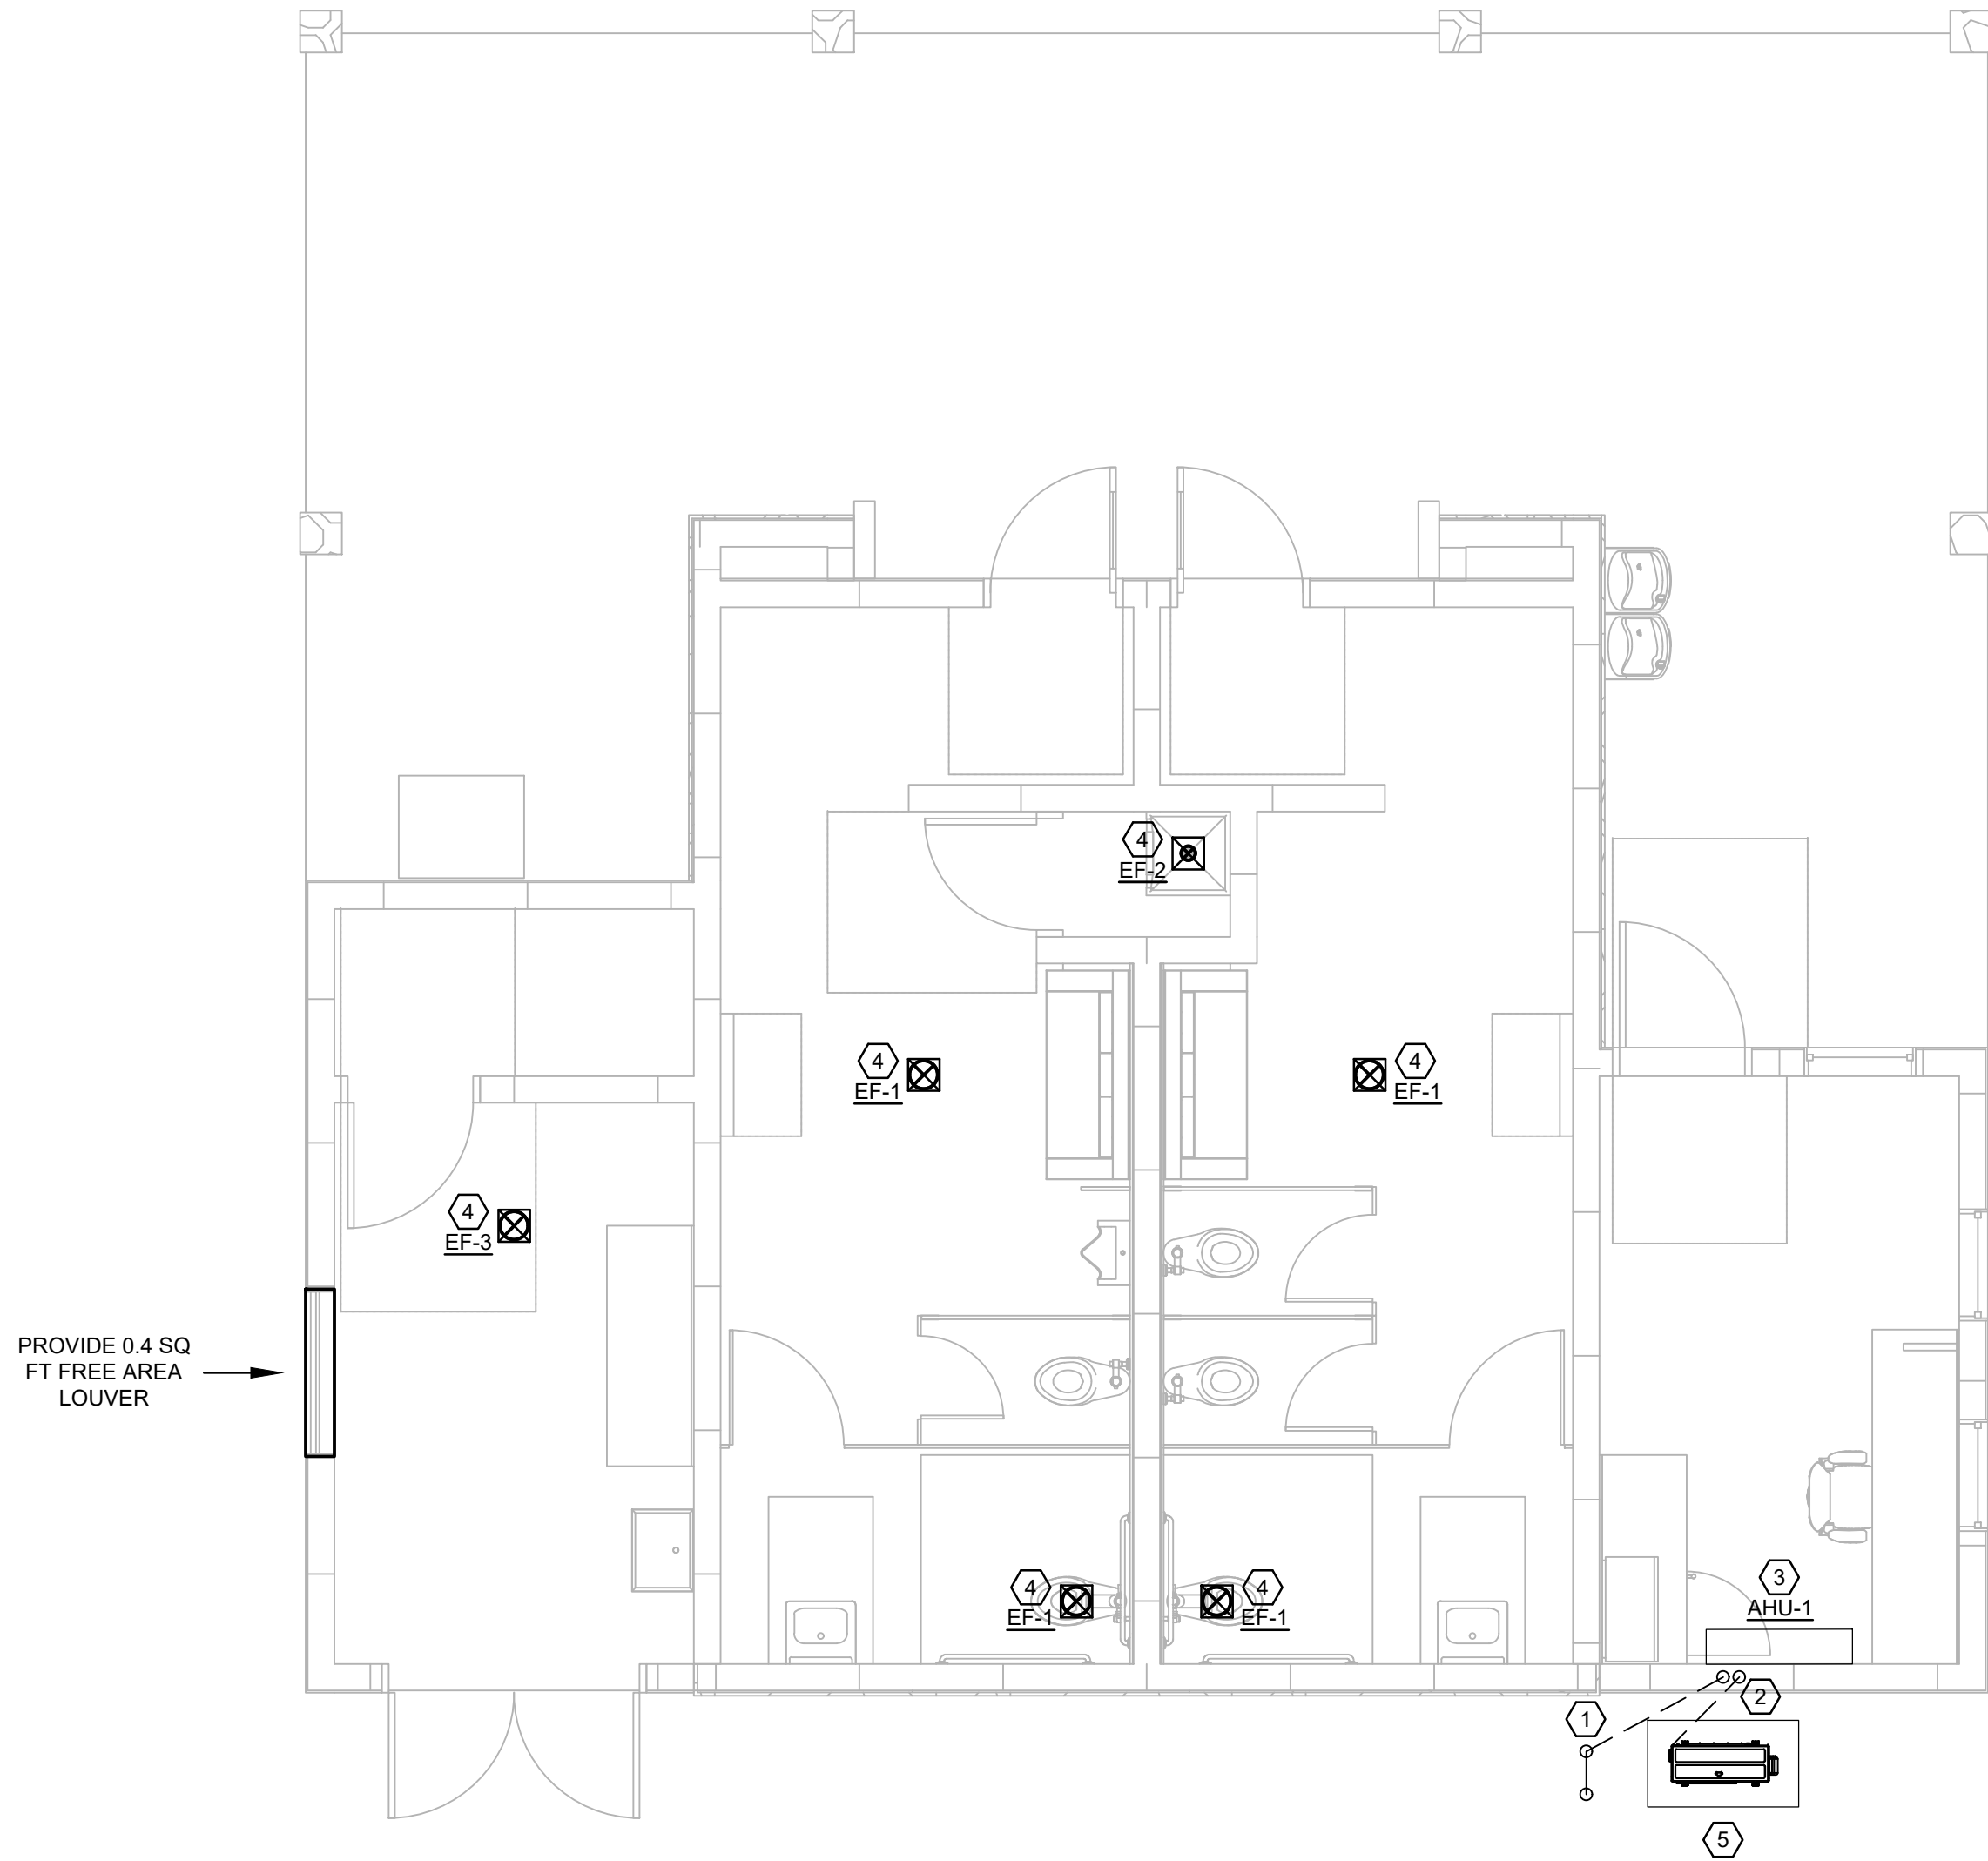

MECHANICAL FLOOR PLANS

SCALE: 1/4"=1'-0"

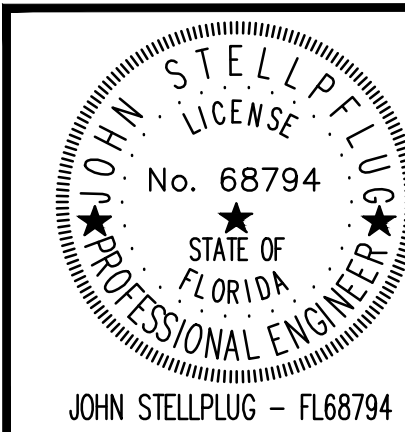

SGM
ENGINEERING

935 LAKE BALDWIN LANE
ORLANDO, FL 32814
TEL: 407-767-5188
FAX: 407-767-5772
CA-00006208

SGM #:
2024-256
WWW.SGMENGINEERING.COM
COPYRIGHT © 2024 SGM ENGINEERING, INC.

PROJECT LEAD
& CIVIL ENGINEERING:



301 EAST ATLANTIC BLVD.
POMIPANO BEACH, FL 33060
PH: (954) 788-3400
Florida Engineering Business License: CA7928
Florida Surveyor and Mapper Business License: LB6860
Florida Landscape Architecture Business License: LC26000457

LANDSCAPE ARCHITECT:



801 INTERNATIONAL PARKWAY
LAKE MARY, FL 32746
407.871.9607
MKSKSTUDIOS.COM

ARCHITECT:



WANNEMACHER, JENSEN ARCHITECTS
815 NORTHWEST 57 AVE. SUITE 219
MIAMI, FLORIDA 33126
727-822-5568
WJARC.COM AA0002277

MECHANICAL, PLUMBING,
& ELECTRICAL ENGINEERING:



5301 WATERFORD DISTRICT DR.
SUITE 750
954-421-1944
SGMENGINEERING.COM CA-00006208

REVISIONS

NO.	DESCRIPTION	DATE

**PRELIMINARY PLAN
NOT FOR CONSTRUCTION**
THESE PLANS ARE NOT FULLY PERMITTED
AND ARE SUBJECT TO REVISIONS MADE
DURING THE PERMITTING PROCESS.

ISSUE DATE: XX/XX/20
DESIGNED BY: XXX
DRAWN BY: XXX
CHECKED BY: XXX

THOMAS F. DONAHUE, P.E.
FLORIDA REG. NO. 60529
(FOR THE FIRM)

CLIENT
**VILLAGE OF
PINECREST**
PINECREST PARKS & RECREATION



PROJECT

SHEET TITLE

MECHANICAL
FLOOR PLANS

SHEET
NUMBER
M201

KEITH PROJECT
NUMBER
13861.00

STATUS: PRELIMINARY

Drawing name: G:\PROJECT FILES\2024\2024-256 Village of Pinecrest- Gary Matamor-Park\Drawings\1500-M201-2024256.dwg

Plotted by: mitch On: 11/1/2024 1:47 PM