



A circular professional engineer seal for Ricardo Perez de Aleo. The outer ring contains the text "RICARDO PEREZ DE ALEO" at the top and "PROFESSIONAL ENGINEER" at the bottom, separated by three stars. The inner circle contains the text "LICENSE" at the top, "No. 58728" in the center, and "STATE OF FLORIDA" at the bottom, also separated by three stars.


FELIX DAYAN GUERRA	
16267 SW 97th ST. MIAMI, FL. 33196 (561) 229-2618	
PE 93172	
M + E + P ENGINEER	
RICARDO PEREZ	
19570 W 84TH AVE. MIAMI, FL. 33015 (786) 308-9857	
PE 58728	

[illegible]


M-1.1

ORIGINAL ISSUE DATE: 12-26-2024
PLOT DATE: 2025-09-10


2nd floor mechanical plan
SCALE: 3/16" = 1'-0"

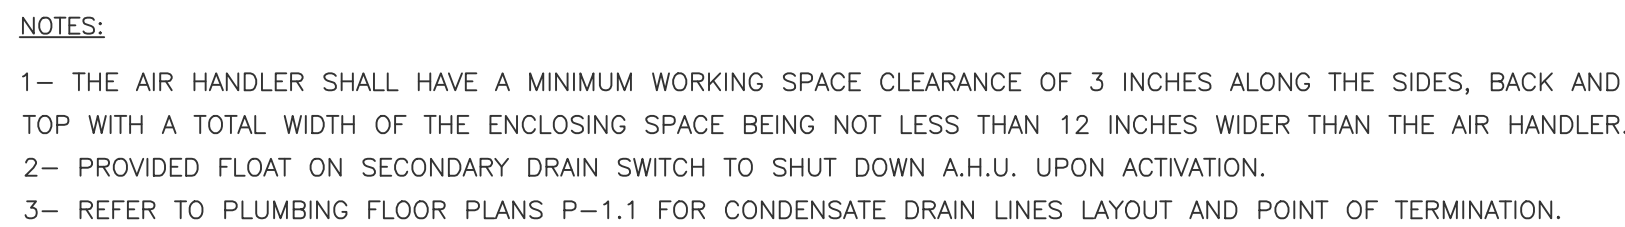


A.H.U. 1,2 MOUNTING DETAIL
N.T.S.

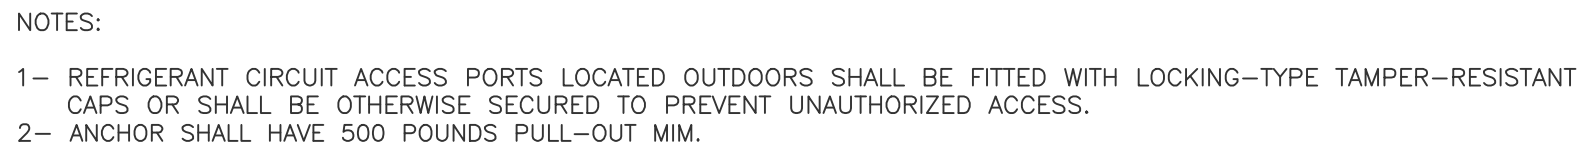


CONDENSING UNIT MOUNTING DETAIL

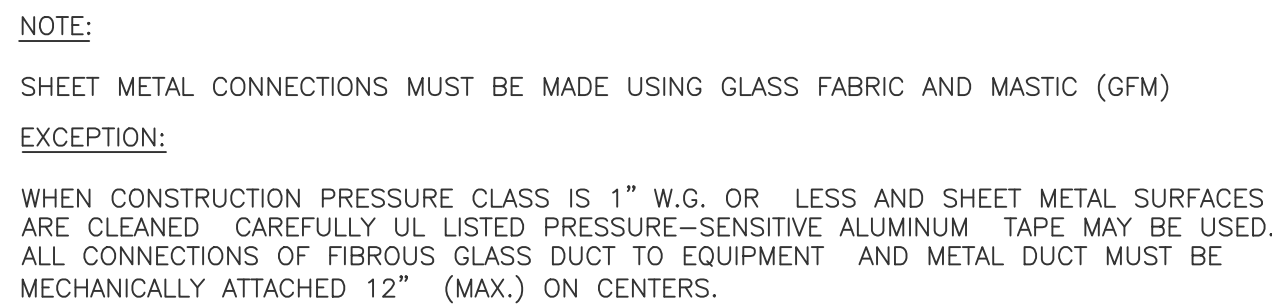

SHEET METAL AND EQUIPMENT CONNECTIONS DETAILS

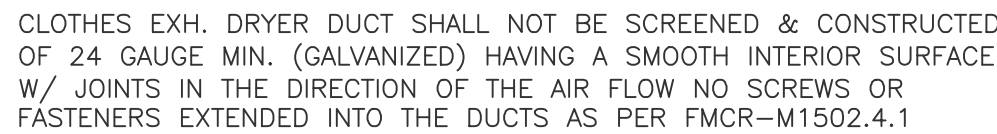


DRYER EXHAUST AT ROOF CAP
N.T.S.

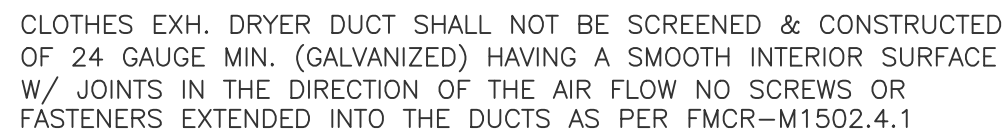


DRYER EXHAUST AT WALL CAP
N.T.S.



AIR HANDLING UNIT DRAIN TRAP
N.T.S.

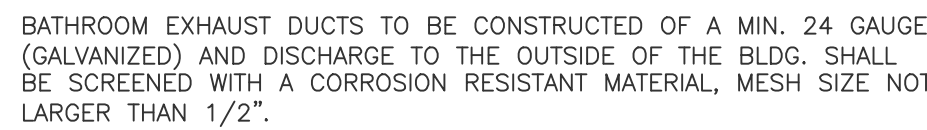

TOILET EXHAUST AT ROOF CAP
N.T.S.

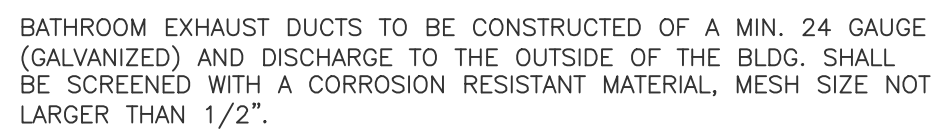

TOILET EXHAUST AT WALL CAP
N.T.S.