

ALL SYMBOLS SHOWN MAY NOT APPEAR IN ALL DRAWINGS. SYMBOLS ARE SHOWN SCHEMATIC AND MAY NOT BE TO SCALE.

[illegible]

SWITCHES

[illegible]

SYMBOL	DESCRIPTION	DEVICE MTG HT
--------	-------------	---------------

--	--	--

SYMBOL	DESCRIPTION	DEVICE MTG. HT. U.N.O
--------	-------------	-----------------------

	JUNCTION BOX - SIZE AND MOUNTING AS REQUIRED	-
---	--	---

		DEVICE MTG.
--	--	-------------

SYMBOL	DESCRIPTION	UNIT
--------	-------------	------

--	--	--

SYMBOL	DESCRIPTION	DEVICE MTG. HT.
--------	-------------	-----------------

A

- A. ALL WORK SHALL CONFORM WITH ALL LOCAL, STATE, FEDERAL, AND NATIONAL CODES AND BUILDING REGULATIONS GOVERNING THE INSTALLATION OF THE ELECTRICAL. IF WORK IS LAID OUT, INDICATED OR SPECIFIED IS CONTRARY TO OR CONFLICTS WITH LOCAL ORDINANCES, BUILDING CODES AND REGULATIONS, THE CONTRACTOR SHALL REPORT IN WRITING TO THE ARCHITECT/ENGINEER BEFORE SUBMITTING A BID. THE ARCHITECT/ENGINEER WILL THEN ISSUE INSTRUCTIONS AS HOW TO PROCEED.
- B. THE DRAWING ARE TO BE CONSIDERED DIAGRAMMATIC, NOT NECESSARILY SHOWING IN DETAIL OR TO SCALE ALL OF THE MINOR ITEMS, UNLESS SPECIFIC DIMENSIONS ARE SHOWN. THE STRUCTURAL, ARCHITECTURAL AND SITE CONDITIONS SHALL GOVERN THE EXACT LOCATIONS. CONTRACTOR SHALL FOLLOW DRAWINGS IN LAYING OUT WORK, CHECK DRAWINGS OF ALL TRADES TO VERIFY SPACES IN WHICH WORK WILL BE INSTALLED. THE CONTRACTOR SHALL VERIFY THE ROOM OR SPACE CONDITIONS AT ALL POINTS, WHERE HEAD ROOM, OR SPACE CONDITIONS APPEAR INADEQUATE, ARCHITECT/ENGINEER SHALL BE NOTIFIED BEFORE PROCEEDING WITH INSTALLATION. THIS CONTRACTOR SHALL, WITHOUT EXTRA CHARGE, MAKE FIELD MODIFICATION IN LAYOUT AS NEEDED TO PREVENT CONFLICT WITH WORK OF VARIOUS TRADES OR FOR PROPER EXECUTION OF THE WORK.
- C. UPON EXAMINE ALL DRAWINGS, THE CONTRACTOR PRIOR TO SUBMITTING A BID, CONTRACTOR WILL BE REQUIRED TO FURNISH, INSTALL AND/OR CONNECT WITH APPROPRIATE SERVICES ALL ELECTRICAL ITEMS SHOWN ON ANY OF THE ARCHITECTURAL, PLUMBING, MECHANICAL, ETC. DRAWINGS WITHOUT ADDITIONAL EXPENSE TO THE OWNER. IF DISCREPANCIES, CONFLICTS, INTERFERENCES OR OMISSIONS OCCUR BETWEEN DRAWINGS, NOTIFY IN WRITING THE ARCHITECT/ENGINEER IN AMPLE TIME TO PERMIT REVISIONS BEFORE THE BIDS ARE SUBMITTED.
- D. VERIFY SERVICE CHARACTERISTICS, LOCATION AND CONNECTION WITH TELEPHONE AND ELECTRIC UTILITY COMPANIES PERFORM ALL WORK RELATED TO SERVICE IN STRICT ACCORDANCE WITH UTILITY Co. STANDARDS AND REQUIREMENTS.
- E. INSTALL MATERIALS AND EQUIPMENT IN A NEAT AND FIRST CLASS WORKMANLIKE MANNER. THE OWNER RESERVES THE RIGHT TO DIRECT REMOVAL AND REPLACEMENT OF ITEM WHICH, IN HIS OPINION, DOES NOT PRESENT A NEAT AND WORKMAN-LIKE APPEARANCE. REMOVAL AND REPLACEMENT IS TO BE DONE IMMEDIATELY WHEN DIRECTED BY THE OWNER IN WRITING, AT THE SOLE EXPENSE OF CONTRACTOR.
- F. START OF WORK BY CONTRACTOR SHALL BE CONSIDERED AS ACCEPTANCE BY HIM OF ALL CLAUSE AND SPECIFICATIONS AS TO SUITABILITY OF THE WORK OF OTHER TRADES OR OTHER CONTRACTORS TO RECEIVE HIS WORK, THIS CONTRACTOR SHALL REMOVE AND REPLACE, AT HIS EXPENSE, ALL ELECTRICAL WORK WHICH MAY HAVE TO BE REMOVED BECAUSE OF INTERFERENCE WITH OTHER TRADES.
- G. THIS CONTRACTOR SHALL OBTAIN AND PAY ALL INSURANCE, FEES, PERMITS ASSOCIATION DUES, ROYALTIES, AND TAXES OF WHATEVER NATURE SHALL APPLY TO HIS BUSINESS AND ALSO PAY ALL INSPECTION FEES AS MAY BE REQUIRED BY LAW OR ORDINANCE AND SHALL KEEP THE OWNER HARMLESS FROM ANY DAMAGE AND EXPENSE ARISING FROM ANY VIOLATION OF THE LAWS, RULES OR ORDINANCES.
- H. VIOLATE UP COMPLETE ALL THE A/C EQUIPMENT AND CONTROLS AS DIRECTED BY A/C CONTRACTOR. CONTROL WIRING SHALL BE SEPARATE FROM ALL WIRING FROM POWER SOURCES.
- I. PROVIDE MEANS "FURNISH AND INSTALL".
- J. COORDINATE WORK WITH WORK OF OTHER TRADES TO AVOID ALL CONFLICTS.
- K. DO A COMPLETE JOB, EVERYTHING CONNECTED, READY FOR USE.
- L. PROVIDE LIGHT FIXTURES AS PER OWNER SELECTION OR SCHEDULE.
- M. PROVIDE ALL WIRING DEVICES (NO 1/2 SIZE BREAKERS)
- N. ALL WIRING SHALL BE COPPER, IN RACEWAY, UNLESS OTHERWISE SPECIFIED ON DRAWINGS.
- O. RACEWAYS: ALL UNDERGROUND RACEWAYS TO BE PVC, INSIDE CONCRETE SLAB ENT WITH APPROVED FITTING, INSIDE PARTITION EMT, ENT, AND ROMEX WIRE WHERE ALLOWED PER NEC. FOR FLOOR PENETRATION USE ONLY EMT.
- P. SHOP DRAWINGS: THE CONTRACTOR SHALL FURNISH THE ENGINEER WITH SHOP DRAWINGS OF EQUIPMENT PRIOR TO PURCHASE FOR APPROVAL.
- Q. TESTING: THE CONTRACTOR SHALL TEST ALL WORK AND EQUIPMENT AS DIRECTED BY THE ARCHITECT AND BY AUTHORITIES HAVING JURISDICTION, FURNISHING ALL EQUIPMENT AND NECESSARY PERSONNEL AND ELECTRIC THE ENTIRE INSTALLATION SHALL BE TESTED FOR SHORTS, GROUNDS THE CONTRACTOR SHALL TEST ALL WORK AND EQUIPMENT AS DIRECTED BY THE ARCHITECT AND BY AUTHORITIES HAVING JURISDICTION. AND THE WORK SHALL BE DEMONSTRATED TO BE IN PROPER WORKING AND OPERATING CONDITION TO THE COMPLETE SATISFACTION OF THE ENGINEER.
- R. GUARANTEES: ALL EQUIPMENT AND MATERIAL SHALL BE GUARANTEED FOR ONE YEAR AFTER THE DATE OF ACCEPTANCE BY THE OWNER.
- S. BEFORE BIDDING THE JOB THE ELECTRICAL CONTRACTOR SHALL VISIT THE SITE AND BECOME FAMILIAR WITH ALL EXISTING CONDITION AND THE SCOPE OF WORK AS DIRECTED BY THE ARCHITECT AND THESE DRAWINGS.
- T. AT COMPLETION OF THE JOB THE ELECTRICAL CONTRACTOR SHALL GIVE THE OWNER AN AS-BUILT SET OF DRAWINGS SHOWING THE EXACT ELECTRICAL INSTALLATION.
- U. ALL EXISTING ELECTRICAL DEVICES AND EQUIPMENT INSTALLED TO BE DEMOLISHED AND THEIR ASSOCIATED WIRING INSIDE THE REMOVED DEVICES SHALL BE DISCARDED.
- V. IDENTIFY CLEARLY ON A TYPED WRITTEN FORM ALL CIRCUITS AND EQUIPMENT CORRESPONDING WITH THE PLANS AND PANEL SCHEDULE AND ATTACH INSIDE THE PERTAINING PANEL.

THE DRAWINGS DO NOT INDICATE EXISTING INSTALLATIONS OTHER THAN TO

IDENTIFY MODIFICATIONS OR EXTENSIONS THERETO. VISIT THE SITE AND ASCERTAIN THE EXISTING CONDITIONS. REVIEW CONSTRUCTION DETAILS OF THE EXISTING PORTION OF THE BUILDING DURING THE SITE INSPECTION. INCLUDE ALL WORK REQUIRED TO REMOVE OR MODIFY PORTIONS OF THE EXISTING INSTALLATION IN ORDER TO ACCOMMODATE THE NEW WORK. FAILURE TO COMPLY WITH THIS WILL NOT BE CONSIDERED GROUNDS FOR ADDITIONAL PAYMENT IN CONNECTION WITH REMOVING OR MODIFYING ANY PART OF THE EXISTING INSTALLATION OR INSTALLING ANY NEW OR TEMPORARY WORK.

AFB	ABOVE FINISHED COUNTER	MCB	MAIN CIRCUIT BREAKER
AFF	ABOVE FINISHED FLOOR	MCC	MOTOR CONTROL CENTER
AFG	ABOVE FINISHED GRADE	MDP	MAIN DISTRIBUTION PANEL
AHJ	AUTHORITIES HAVING JURISDICTION	MH	MANHOLE
ATS	AUTOMATIC TRANSFER SWITCH	MLO	MAIN LUGS ONLY
BFC	BELOW FINISHED CEILING	MTD	MOUNT OR MOUNTED
BOD	BASIS OF DESIGN	N	NEW DEVICE
BOF	BOTTOM OF FIXTURE	NC (N.C.)	NORMALLY CLOSED
C	CONDUIT	NEC	NATIONAL ELECTRIC CODE
C8, C/B OR CKT BKR	CIRCUIT BREAKER	NF	NONFUSED
CKT	CIRCUIT	NIC	NOT IN CONTRACT
CCTV	CLOSED CIRCUIT T.V.	NL	NIGHT LIGHT
CLG	CEILING	NO (N.O.)	NORMALLY OPEN
DFA	DOWN FROM ABOVE	(ON)	HOME RUN FOR CKT IS "ON" THE SAME CKT. ELSEWHERE ON THE PLAN
ECB	ENCLOSED CIRCUIT BREAKER	PB	PULL BOX
ELEC	ELECTRIC	PNL	PANEL
E	EMERGENCY - RED	PWR	POWER
EMS	ENERGY MANAGEMENT SYSTEM	R	RELOCATED DEVICE
EP	EXPLOSION PROOF	RCPT(S) OR RECEPT	RECEPTACLE(S)
EWG	ELECTRIC WATER COOLER	RF	RETURN AIR FAN
EX	EXISTING TO REMAIN	SEF	SMOKE EXHAUST FAN
EXR	EXISTING TO BE RELOCATED OR REMOVED	SF	SUPPLY AIR FAN
F	FUSE	SO (S.O.)	SPACE ONLY
FA	FIRE ALARM	SP	SPARE
FACP, FAP	FIRE ALARM CONTROL PANEL	ST (S.T.)	SHUNT TRIP
FCU	FAN COIL UNIT	SW	SWITCH
FIXT	FIXTURE	TC	TIME CLOCK
FLR	FLOOR	TEL	TELEPHONE
FLUOR	FLUORESCENT	TF	TRANSFER FAN
FTU	FAN TERMINAL UNIT	TP	TAMPER PROOF
G, GND	GROUND (EQUIPMENT)	TV	TELEVISION
GEF	GENERAL EXHAUST FAN	UF	UNDERFLOOR
GEN	GENERATOR	UG	UNDERGROUND
GFI, GFI	GROUND FAULT CIRCUIT INTERRUPTER	UH	UNIT HEATER
HP	HORSE POWER	U.N.O.	UNLESS NOTED OTHERWISE
HV	HIGH VOLTAGE	V	VOLTAGE
HWAT	HEAT TRACE	VV	VARIABLE VOLUME UNIT
IC	INTERRUPTING CAPACITY	W	WIRE
IG	ISOLATED GROUND	W/	WITH
JB	JUNCTION BOX	WP	WEATHER PROOF (NEMA 3R ENCLOSURE)
LTG	LIGHTING	WR	WEATHER RESISTANT
LTS	LIGHTS	XFMR	TRANSFORMER
LSI	ELECTRONIC TRIP	+xx	MOUNTING HEIGHT IN INCHES. AFF U.N.O.
LSIA	ELECTRONIC TRIP WITH ALARM		
LSIG	ELECTRONIC TRIP WITH GROUND FAULT		
LV	LOW VOLTAGE		
AFCI	ARC - FAULT CIRCUIT INTERRUPTER		

THE SCOPE OF WORK CARRIED OUT ON THIS PROJECT SHALL CONFORM TO ALL

THE SCOPE OF WORK CARRIED OUT ON THIS PROJECT SHALL CONFORM TO ALL APPLICABLE CODES AND STANDARDS INCLUDING BUT NOT LIMITED TO:

1. FLORIDA BUILDING CODE (FBC) 8TH EDITION (2023).
2. FLORIDA FIRE PREVENTION CODE, 8TH EDITION (2023).
3. NFPA 70 - NATIONAL ELECTRICAL CODE (NEC-2020).
4. NFPA 101 - LIFE SAFETY CODE (2021).
5. NFPA 72 - FIRE ALARM CODE (2019).

DWG NO.	DRAWING TITLE	SCALE
---------	---------------	-------

- E-1 GENERAL INFORMATION - ELECTRICAL
- E-2 PROPOSED ELECTRICAL SITE PLAN
- E-3 PROPOSED FIRST FLOOR ELECTRICAL PLAN - AREA A
- E-4 PROPOSED FIRST FLOOR ELECTRICAL PLAN - AREA B
- E-5 PROPOSED SECOND FLOOR ELECTRICAL PLAN - AREA A
- E-6 ELECTRICAL RISER DIAGRAMS
- E-7 ELECTRICAL SCHEDULES & NOTES
- E-8 ELECTRICAL SCHEDULES
- E-9 ELECTRICAL SCHEDULES




ISSUES
JUN 2024
06.10.25
1ST ISSUED
BLDG DEPT COMMENTS

R&D Project No.	2025.512
DRAWN BY	RV
CHECKED BY	RD
SCALE	AS NOTED
R&D ENGINEERS REGISTRY NO.	37312
SEAL	



THIS IS A DIGITALLY SIGNED SHEET. PRINTED COPIES OF THIS DOCUMENT ARE VALID.

SHEET NO. _____

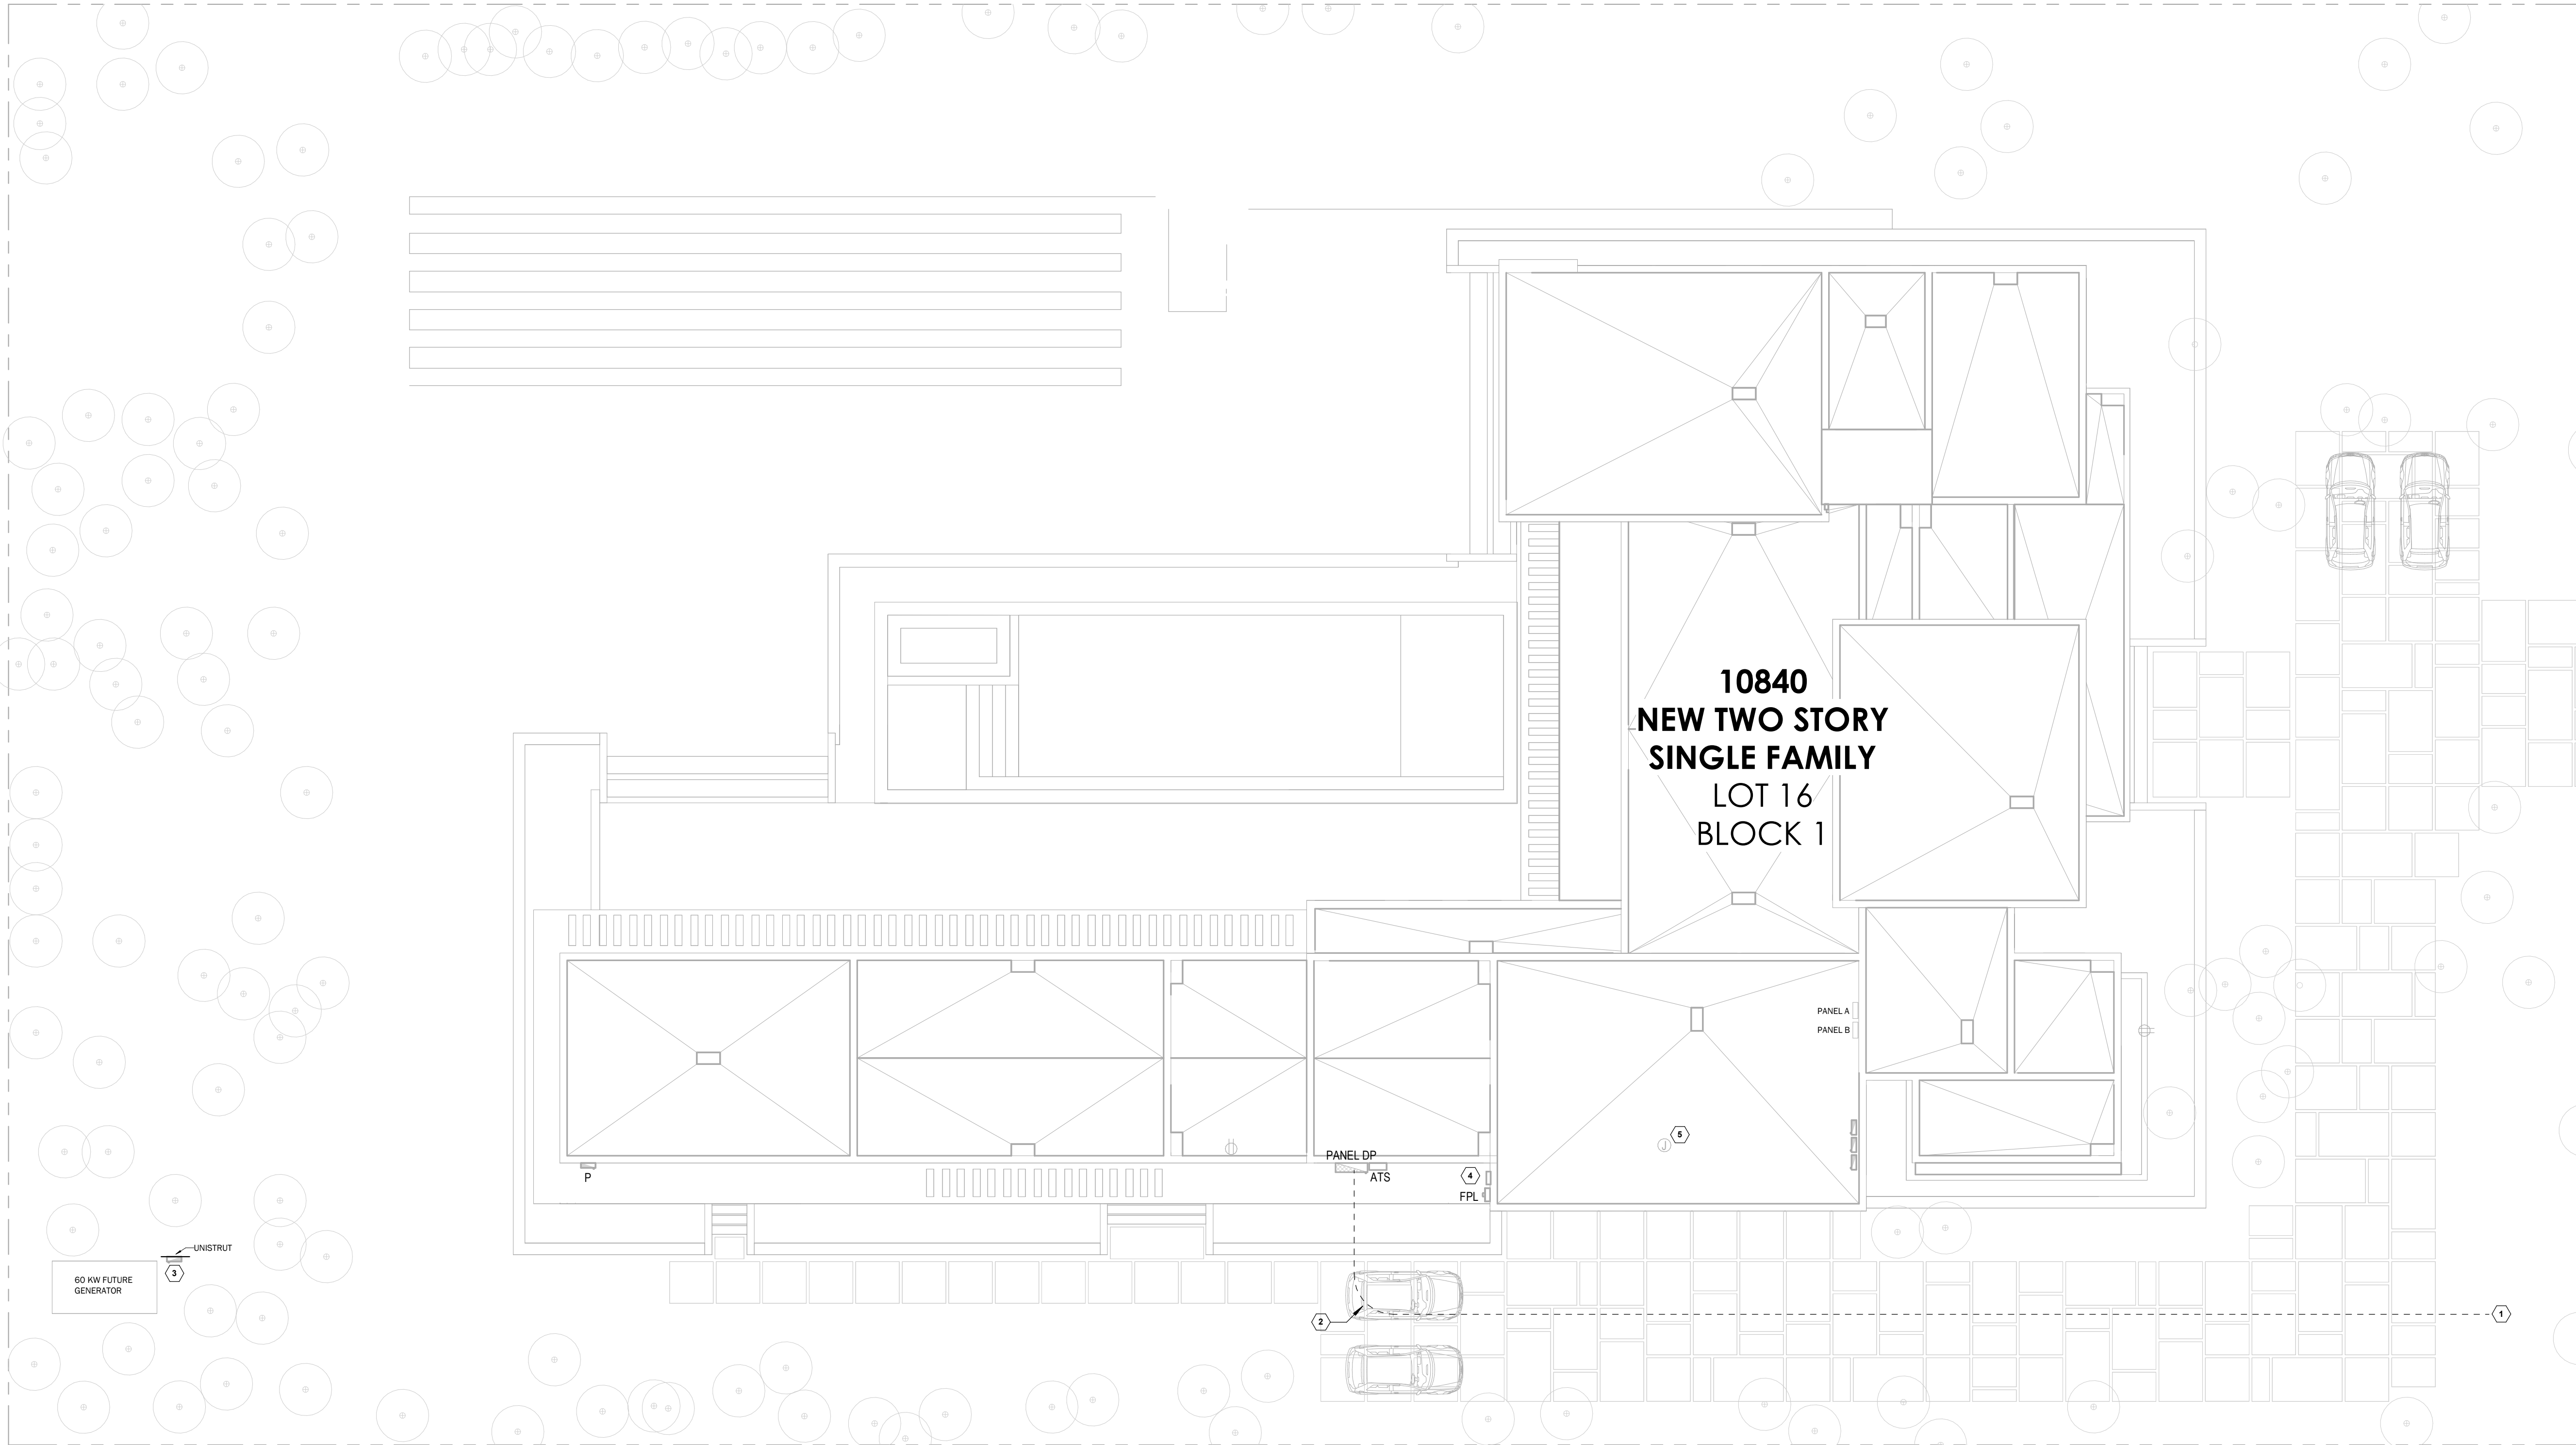

1 SITE PLAN - ELECTRICAL
SCALE: 3/32" = 1'-0"

LEGEND NOTES

- TO APPROXIMATE LOCATION OF UTILITY COMPANY POLE. COORDINATE EXACT LOCATION AND REQUIREMENTS WITH UTILITY COMPANY PRIOR TO INSTALLATION OF SERVICE CONDUITS. CONTRACTOR/OWNER SHALL COORDINATE CONNECTION WITH UTILITY COMPANY REPRESENTATIVE & VERIFY IF EXISTING TRANSFORMER IS CAPABLE OF ACCEPTING THE PROPOSED ADDITIONAL LOAD. IF EXISTING TRANSFORMER REQUIRES REPLACEMENT, IT IS THE RESPONSIBILITY OF THE CONTRACTOR, UNDER DIRECTION FROM THE OWNER, TO COORDINATE REPLACEMENT WITH UTILITY COMPANY REPRESENTATIVE AND PROVIDE ALL EQUIPMENT & MATERIAL NECESSARY FOR A COMPLETE AND OPERATIONAL INSTALLATION.
- PROPOSED UNDERGROUND ROUTING OF POWER SERVICE CONDUCTORS. COORDINATE EXACT ROUTING WITH CIVIL AND STRUCTURAL DRAWINGS. FOR QUANTITY AND SIZES, REFER TO ELECTRICAL RISER DIAGRAM. ROUTING SHOWN IS SCHEMATIC ONLY. CONTRACTOR SHALL FIND FEASIBLE ROUTING IN THE FIELD.
- FUTURE 250A PORTABLE GENERATOR CONNECTION TAP BOX.
- EMPTY J-BOX FOR FUTURE SOLAR PV ADJACENT TO METER. PROVIDE 2" EMPTY CONDUIT STUB UP AT ROOF. PROVIDE CAP.
- EMPTY J-BOX FOR FUTURE SOLAR PANEL. TERMINATE ADJACENT TO METER. PROVIDE 2" EMPTY CONDUIT.

GENERAL NEW WORK NOTES

- FURNISH AND INSTALL ALL WIRING AND RACEWAYS TO COMPLETE CIRCUITING AS INDICATED ON THESE DRAWINGS.
- COORDINATE EXACT LOCATION AND HEIGHT OF ALL RECEPTACLES AND DEVICES WITH ARCHITECTURAL ELEVATIONS AND DRAWINGS.
- FINAL LOCATION OF ALL RECEPTACLES SHALL BE COORDINATED WITH MILLWORK. REFER TO ARCHITECTURAL DRAWINGS.
- ALL ELECTRICAL BOXES TO BE INSTALLED STAGGERED. REFER TO ARCHITECTURAL DRAWINGS FOR DETAILS.
- PROVIDE ACCESSIBILITY IN FRONT OF THE SERVICE AS REQUIRED BY NEC 110.26A.
- ALL EQUIPMENT INSTALLED OUTSIDE SHALL BE SUITABLE FOR THE LOCATION AS REQUIRED PER NEC.
- CONDUIT ROUTING SHOWN IS SCHEMATIC ONLY. CONTRACTOR SHALL CONFIRM EXACT ROUTINGS IN THE FIELD. COORDINATE EXACT REQUIREMENTS WITH STRUCTURAL DRAWINGS.



MIK ARCHITECTURE LLC
MATIAS DAROCH
AR-10480
1385 CORAL WAY, SUITE 200
MIAMI, FLORIDA 33145
+1 786 738-0860
mika@mikarch.com



AGD DEVELOPERS LLC
1385 CORAL WAY, SUITE 200
MIAMI, FLORIDA 33145
agdevelopers.com
developers@agdevelopers.com



R&D ENGINEERS LLC
7701 NW 12TH ST, SUITE 207
CORAL GABLES, FLORIDA 33134
rdengineers.com
coral@rd-engineers.com

NEW SINGLE FAMILY RESIDENCE
AGD CALUSTONE LLC
10840 SW 67 Ave MIAMI, FL 33156

ISSUES
JUN 2024 1ST ISSUED



READ PROJECT NO. 2025.512


DRAWN BY RV

CHECKED BY RD

SCALE AS NOTED

READ ARCHITECTS REGISTER NO. 37312

SEAL

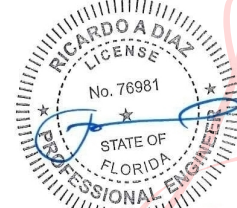

Digitally signed
by RICARDO A.
DIAZ
Date: 2025.06.11
17:55:13 -04'00'


RICARDO A. DIAZ
PROFESSIONAL ENGINEER
PE 76981

THIS IS A DIGITALLY SIGNED SHEET. PRINTED COPIES OF THIS DOCUMENT ARE NOT
CONSIDERED SIGNED AND SEALED AND BE SIGNATURE MUST BE VIEWED ON
THE ELECTRONIC COPIES.

THE CONTENT OF THIS SHEET AND ALL OTHER DRAWINGS ISSUED IN THE SET ARE
PROTECTED BY U.S. AND INTERNATIONAL COPYRIGHT LAWS. REPRODUCTION OR
USE WITHOUT PROPER WRITTEN CONSENT IS PROHIBITED BY LAW. SEE ALSO FOR
DETAILS.

SHEET NO.

E-2

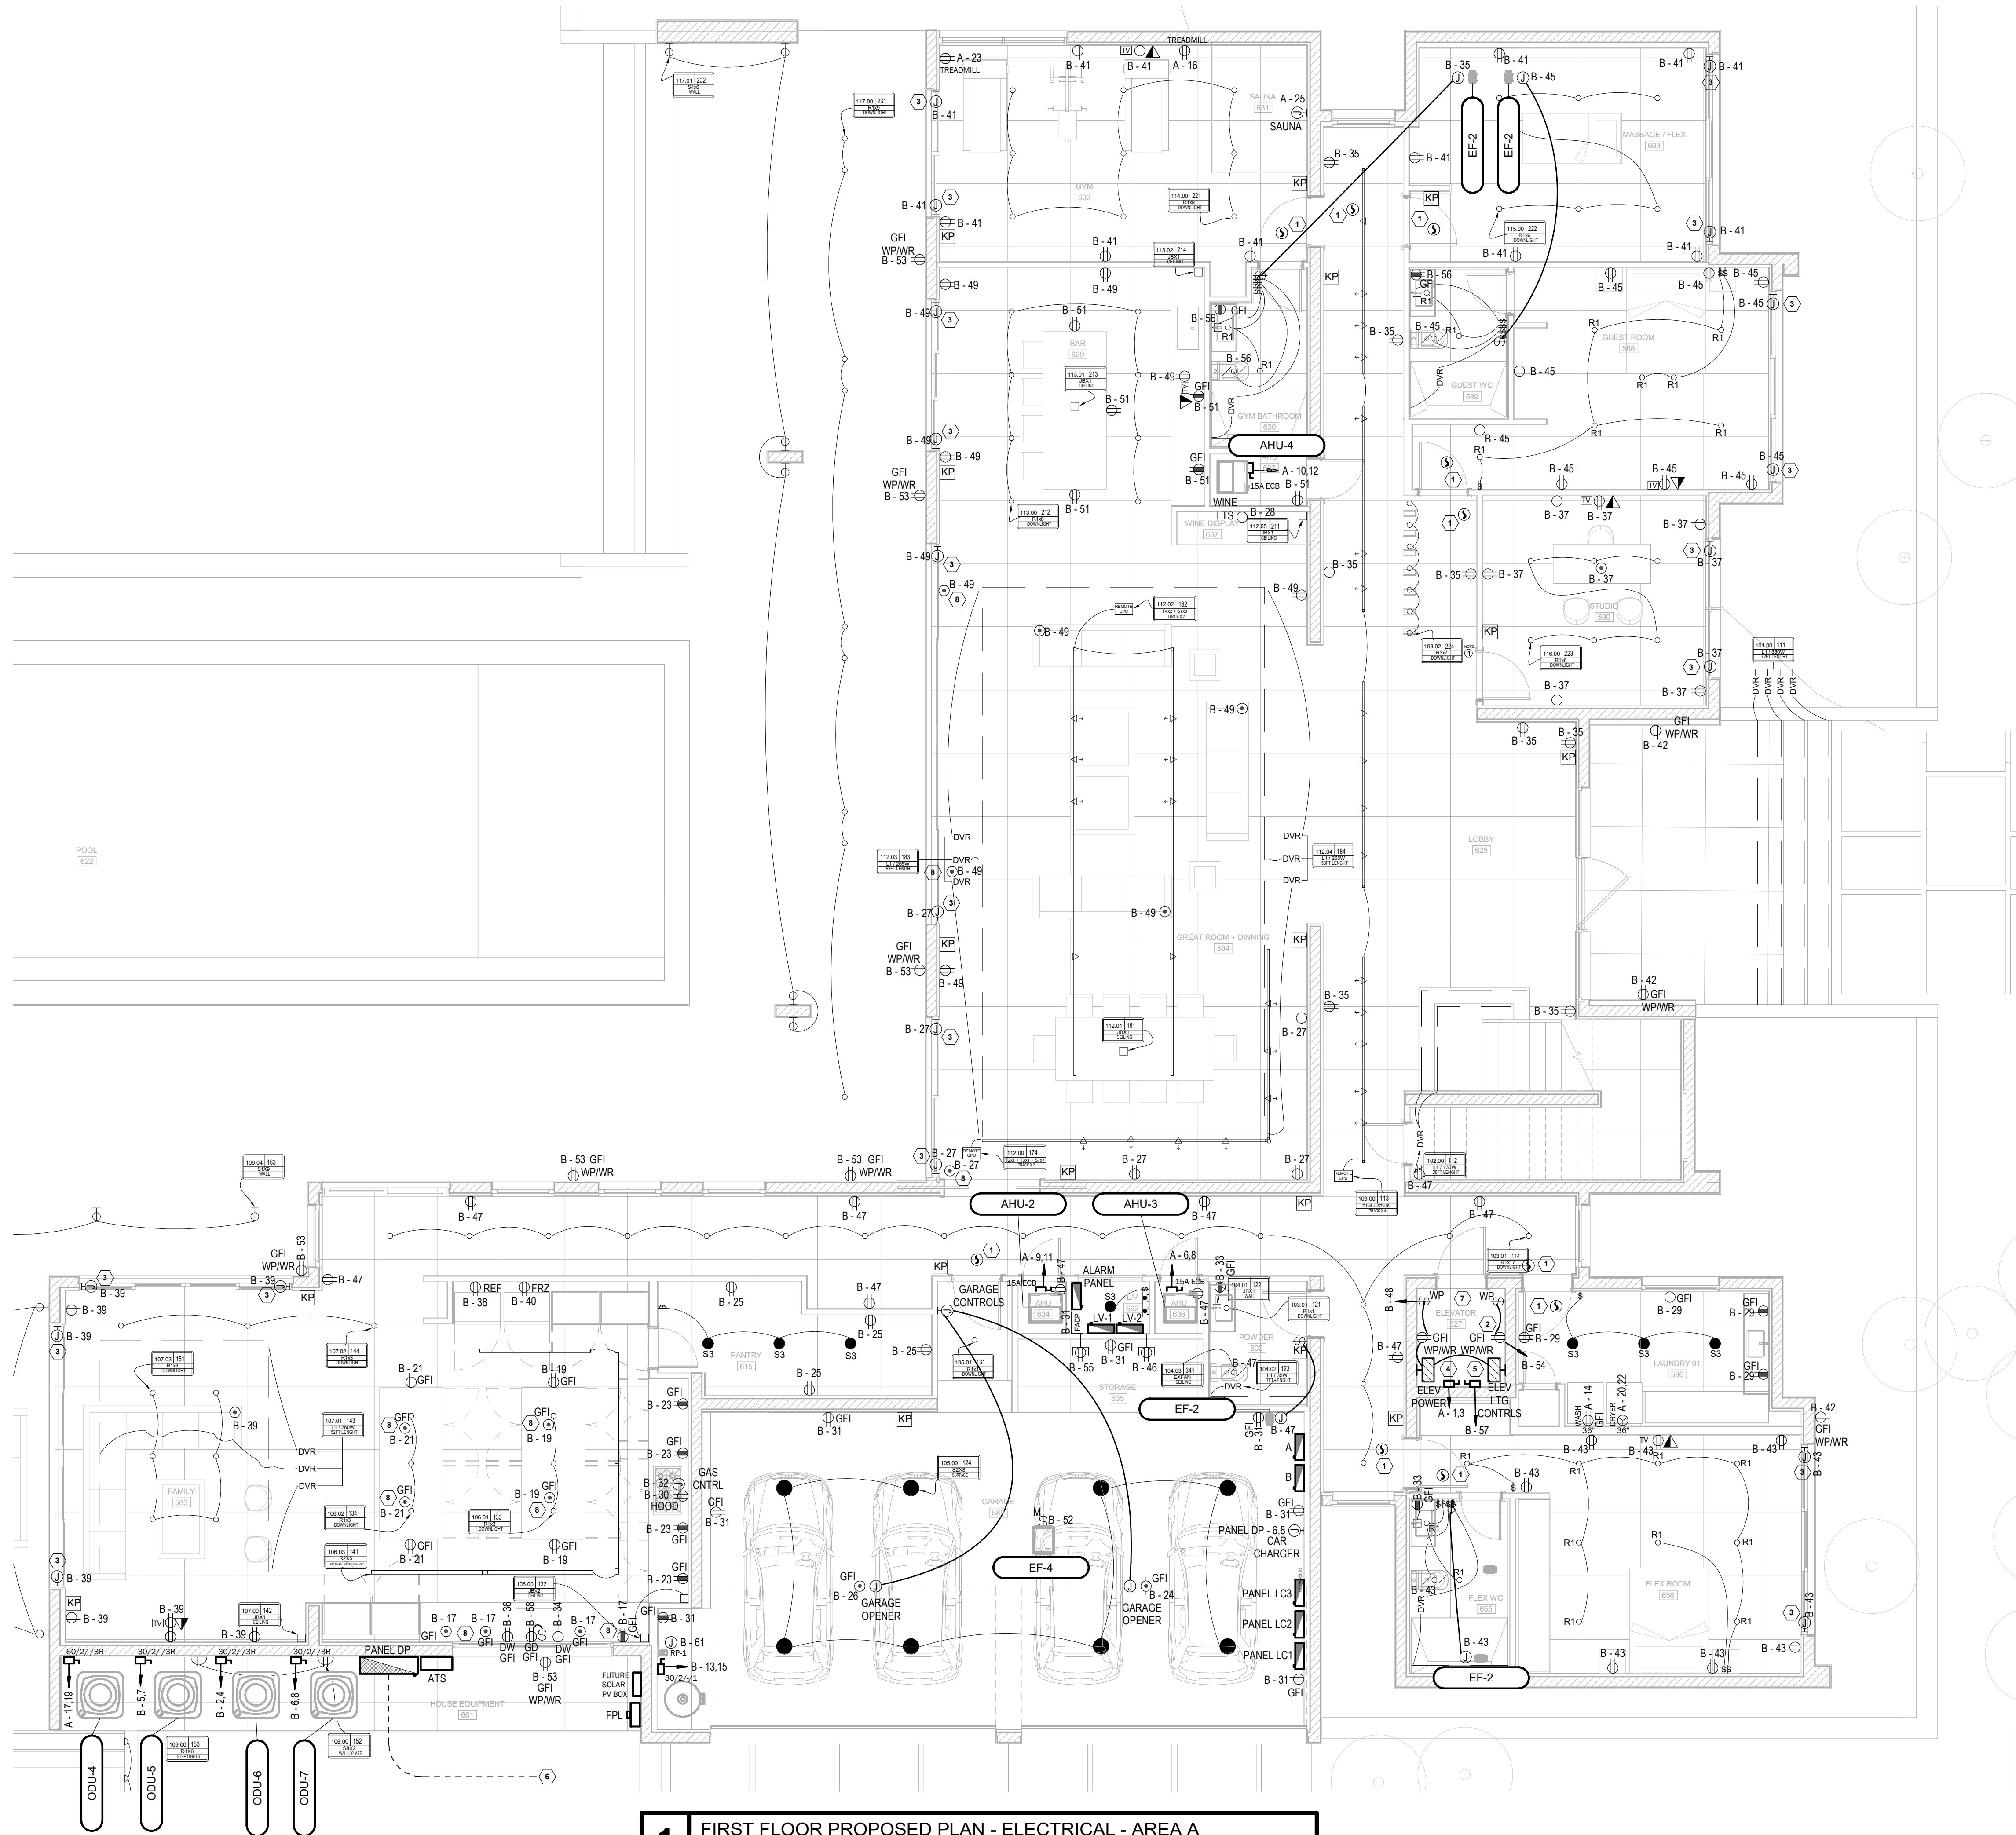


GENERAL NEW WORK NOTES

- FURNISH AND INSTALL ALL WIRING AND RACEWAYS TO COMPLETE CIRCUITING AS INDICATED ON THESE DRAWINGS.
- COORDINATE EXACT LOCATION AND HEIGHT OF ALL RECEPTACLES AND DEVICES WITH ARCHITECTURAL ELEVATIONS AND DRAWINGS.
- FINAL LOCATION OF ALL RECEPTACLES SHALL BE COORDINATED WITH MILLWORK. REFER TO ARCHITECTURAL DRAWINGS.
- ALL ELECTRICAL BOXES TO BE INSTALLED STAGGERED. REFER TO ARCHITECTURAL DRAWINGS FOR DETAILS.
- PROVIDE ACCESSIBILITY IN FRONT OF THE SERVICE AS REQUIRED BY NEC 110.26A.
- ALL EQUIPMENT INSTALLED OUTSIDE SHALL BE SUITABLE FOR THE LOCATION AS REQUIRED PER NEC.
- WHEN GFI RECEPTACLE ACCESSIBILITY IS NOT ACHIEVED, GFI PROTECTION SHALL BE PROVIDED VIA GFI BREAKER.
- CONDUIT ROUTING SHOWN IS SCHEMATIC ONLY, CONTRACTOR SHALL CONFIRM EXACT ROUTING IN THE FIELD. COORDINATE EXACT REQUIREMENTS WITH STRUCTURAL DRAWINGS.

LEGEND NOTES

- PROVIDE COMBINATION SMOKE DETECTOR / CARBON MONOXIDE DETECTOR ALARM. ALL DEVICES SHALL BE INTERCONNECTED, SO THAT OPERATION OF ANY SMOKE OR CARBON MONOXIDE ALARM SHALL CAUSE THE ALARM OF ALL ALARMS WITHIN THE DWELLING UNIT TO SOUND (NFPA 101 SECTION 9.6.2.10.3)
- SWITCHED RECEPTACLE FOR ELEVATOR PIT SUMP PUMP.
- JUNCTION BOX FOR POWER EXTENSION TO MOTORIZED SHADES. COORDINATE EXACT REQUIREMENTS WITH VENDOR.
- 250V, 2-POLE, 30A LOCKABLE DISCONNECT FOR POWER TO ELEVATOR. PROVIDE 20A FUSES PER MANUFACTURER RECOMMENDATIONS. COORDINATE EXACT REQUIREMENTS WITH VENDOR.
- 120V, 30A LOCKABLE DISCONNECT FOR POWER TO ELEVATOR LTG & CONTROLS. PROVIDE FUSES PER MANUFACTURER RECOMMENDATIONS. COORDINATE EXACT REQUIREMENTS WITH VENDOR.
- APPROXIMATE ROUTING OF PROPOSED UNDERGROUND SERVICE FEEDERS. REFER TO RISER DIAGRAM FOR ADDITIONAL INFORMATION. CONDUIT ROUTING IS SCHEMATIC ONLY. CONTRACTOR SHALL CONFIRM SUITABLE ROUTING IN THE FIELD.
- ELEVATOR PROVIDED WITH UPS FOR EMERGENCY LOWERING.
- FLOOR RECEPTACLE SHALL BE WITHIN 12" FROM THE GLASS WALL.
- CONTRACTOR TO PROVIDE POP-UP RECEPTACLES.

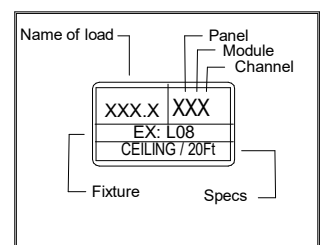

LIGHTING LEGEND

- Downlight Recessed Fijo R1
- Downlight Surface S2,S3
- Wall Washer Recessed R4
- Uplight Recessed R3
- ◁ Spotight (Aimed) S7
- Downlight Linear Led R6
- LED Strip L1, L2
- ⊕ Appliqué S4, S5, S9, S11
- Rail 1000mm, T1, T2, T3
- J BOX
- ◇ Wall washer R5
- LED Strip L3
- Downlight Surface Aimable S1
- ⊕ Wall wash S10
- ◇ Wall wash R5




MIK ARCHITECTURE LLC

MATIAS DAROCH
AR-10480
1385 CORAL WAY, SUITE 200
MIAMI, FLORIDA 33145
+1 786 738 0860
mik@mikarch.com



AGD DEVELOPERS LLC

1385 CORAL WAY, SUITE 200
MIAMI, FLORIDA 33145
agdevelopers.com
developers@agdevelopers.com

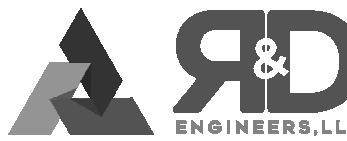

R&D ENGINEERS, L.L.C.

7700 NW 125th Street 207
CORAL GABLES, FLORIDA 33156
r&d-engineers.com
coral@r&d-engineers.com

NEW SINGLE FAMILY RESIDENCE
AGD CALUSTONE LLC
10840 SW 67 Ave MIAMI, FL 33156

ISSUES
JUN 2024 1ST ISSUED



REVISIONS
2025.512

DRAWN BY
RV

CHECKED BY
RD

SCALE
AS NOTED

REVISIONS
37312

SEAL

Digitally signed
by RICARDO A
DIAZ
Date:
2025.06.11
17:55:22 -04'00'
RICARDO A DIAZ
PROFESSIONAL ENGINEER
PE 76981

THIS IS A DIGITALLY SIGNED SHEET. PRINTED COPIES OF THIS DOCUMENT ARE NOT
CONTROLLED. SIGNATURE AND SEAL ARE REQUIRED AND MUST BE VERIFIED ON
THE ORIGINAL DOCUMENT.
THE CONTENT OF THIS SHEET AND ALL OTHER DRAWINGS ISSUED BY THE SET ARE
PROTECTED BY U.S. AND INTERNATIONAL COPYRIGHT LAWS. REPRODUCTION OR
USE WITHOUT PROPER WRITTEN CONSENT IS PROHIBITED BY LAW. SEE ALSO FOR
DETAILS.
SHEET NO.

E-3


PROPOSED FIRST FLOOR ELECTRICAL
PLAN , AREA A

GENERAL NEW WORK NOTES

- A. FURNISH AND INSTALL ALL WIRING AND RACEWAYS TO COMPLETE CIRCUITING AS INDICATED ON THESE DRAWINGS.
- B. COORDINATE EXACT LOCATION AND HEIGHT OF ALL RECEPTACLES AND DEVICES WITH ARCHITECTURAL ELEVATIONS AND DRAWINGS.
- C. FINAL LOCATION OF ALL RECEPTACLES SHALL BE COORDINATED WITH MILLWORK. REFER TO ARCHITECTURAL DRAWINGS.
- D. ALL ELECTRICAL BOXES TO BE INSTALLED STAGGERED. REFER TO ARCHITECTURAL DRAWINGS FOR DETAILS.
- E. PROVIDE ACCESSIBILITY IN FRONT OF THE SERVICE AS REQUIRED BY NEC 110.26A.
- F. ALL EQUIPMENT INSTALLED OUTSIDE SHALL BE SUITABLE FOR THE LOCATION AS REQUIRED PER NEC.
- G. WHEN GFI RECEPTACLE ACCESSIBILITY IS NOT ACHIEVED, GFI PROTECTION SHALL BE PROVIDED VIA GFI BREAKER.
- H. CONDUIT ROUTING SHOWN IS SCHEMATIC ONLY. CONTRACTOR SHALL CONFIRM EXACT ROUTING IN THE FIELD. COORDINATE EXACT REQUIREMENTS WITH STRUCTURAL DRAWINGS.


LEGEND NOTES

- 1 PROVIDE COMBINATION SMOKE DETECTOR / CARBON MONOXIDE DETECTOR ALARM. ALL DEVICES SHALL BE INTERCONNECTED, SO THAT OPERATION OF ANY SMOKE OR CARBON MONOXIDE ALARM SHALL CAUSE THE ALARM OF ALL ALARMS WITHIN THE DWELLING UNIT TO SOUND (NFPA 101 SECTION 9.6.2.10.3)
- 2 JUNCTION BOX FOR POWER EXTENSION TO MOTORIZED SHADES. COORDINATE EXACT REQUIREMENTS WITH VENDOR.
- 3 WHEN GFI RECEPTACLE ACCESSIBILITY IS NOT ACHIEVED, GFI PROTECTION SHALL BE PROVIDED VIA GFI BREAKER.
- 4 FLOOR RECEPTACLE SHALL BE WITHIN 12" FROM THE GLASS WALL.

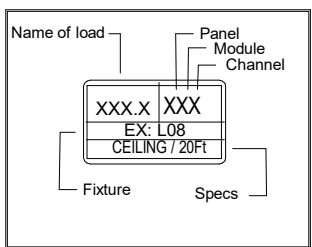

LIGHTING
LEGEND

- Downlight Recessed Fijo R1
● Downlight Surface S2,S3
○ Wall Washer Recessed R4
○ Uplight Recessed R3
◁+ Spotlight (Aimed) S7
Downlight Linear Led R6
LED Strip L1, L2
Appliqué S4, S5, S9, S11
Rail 1000mm, T1, T2, T3
J BOX
Wall washer R5
LED Strip L3
Downlight Surface Aimable S1
Wall wash S10
Wall wash R5

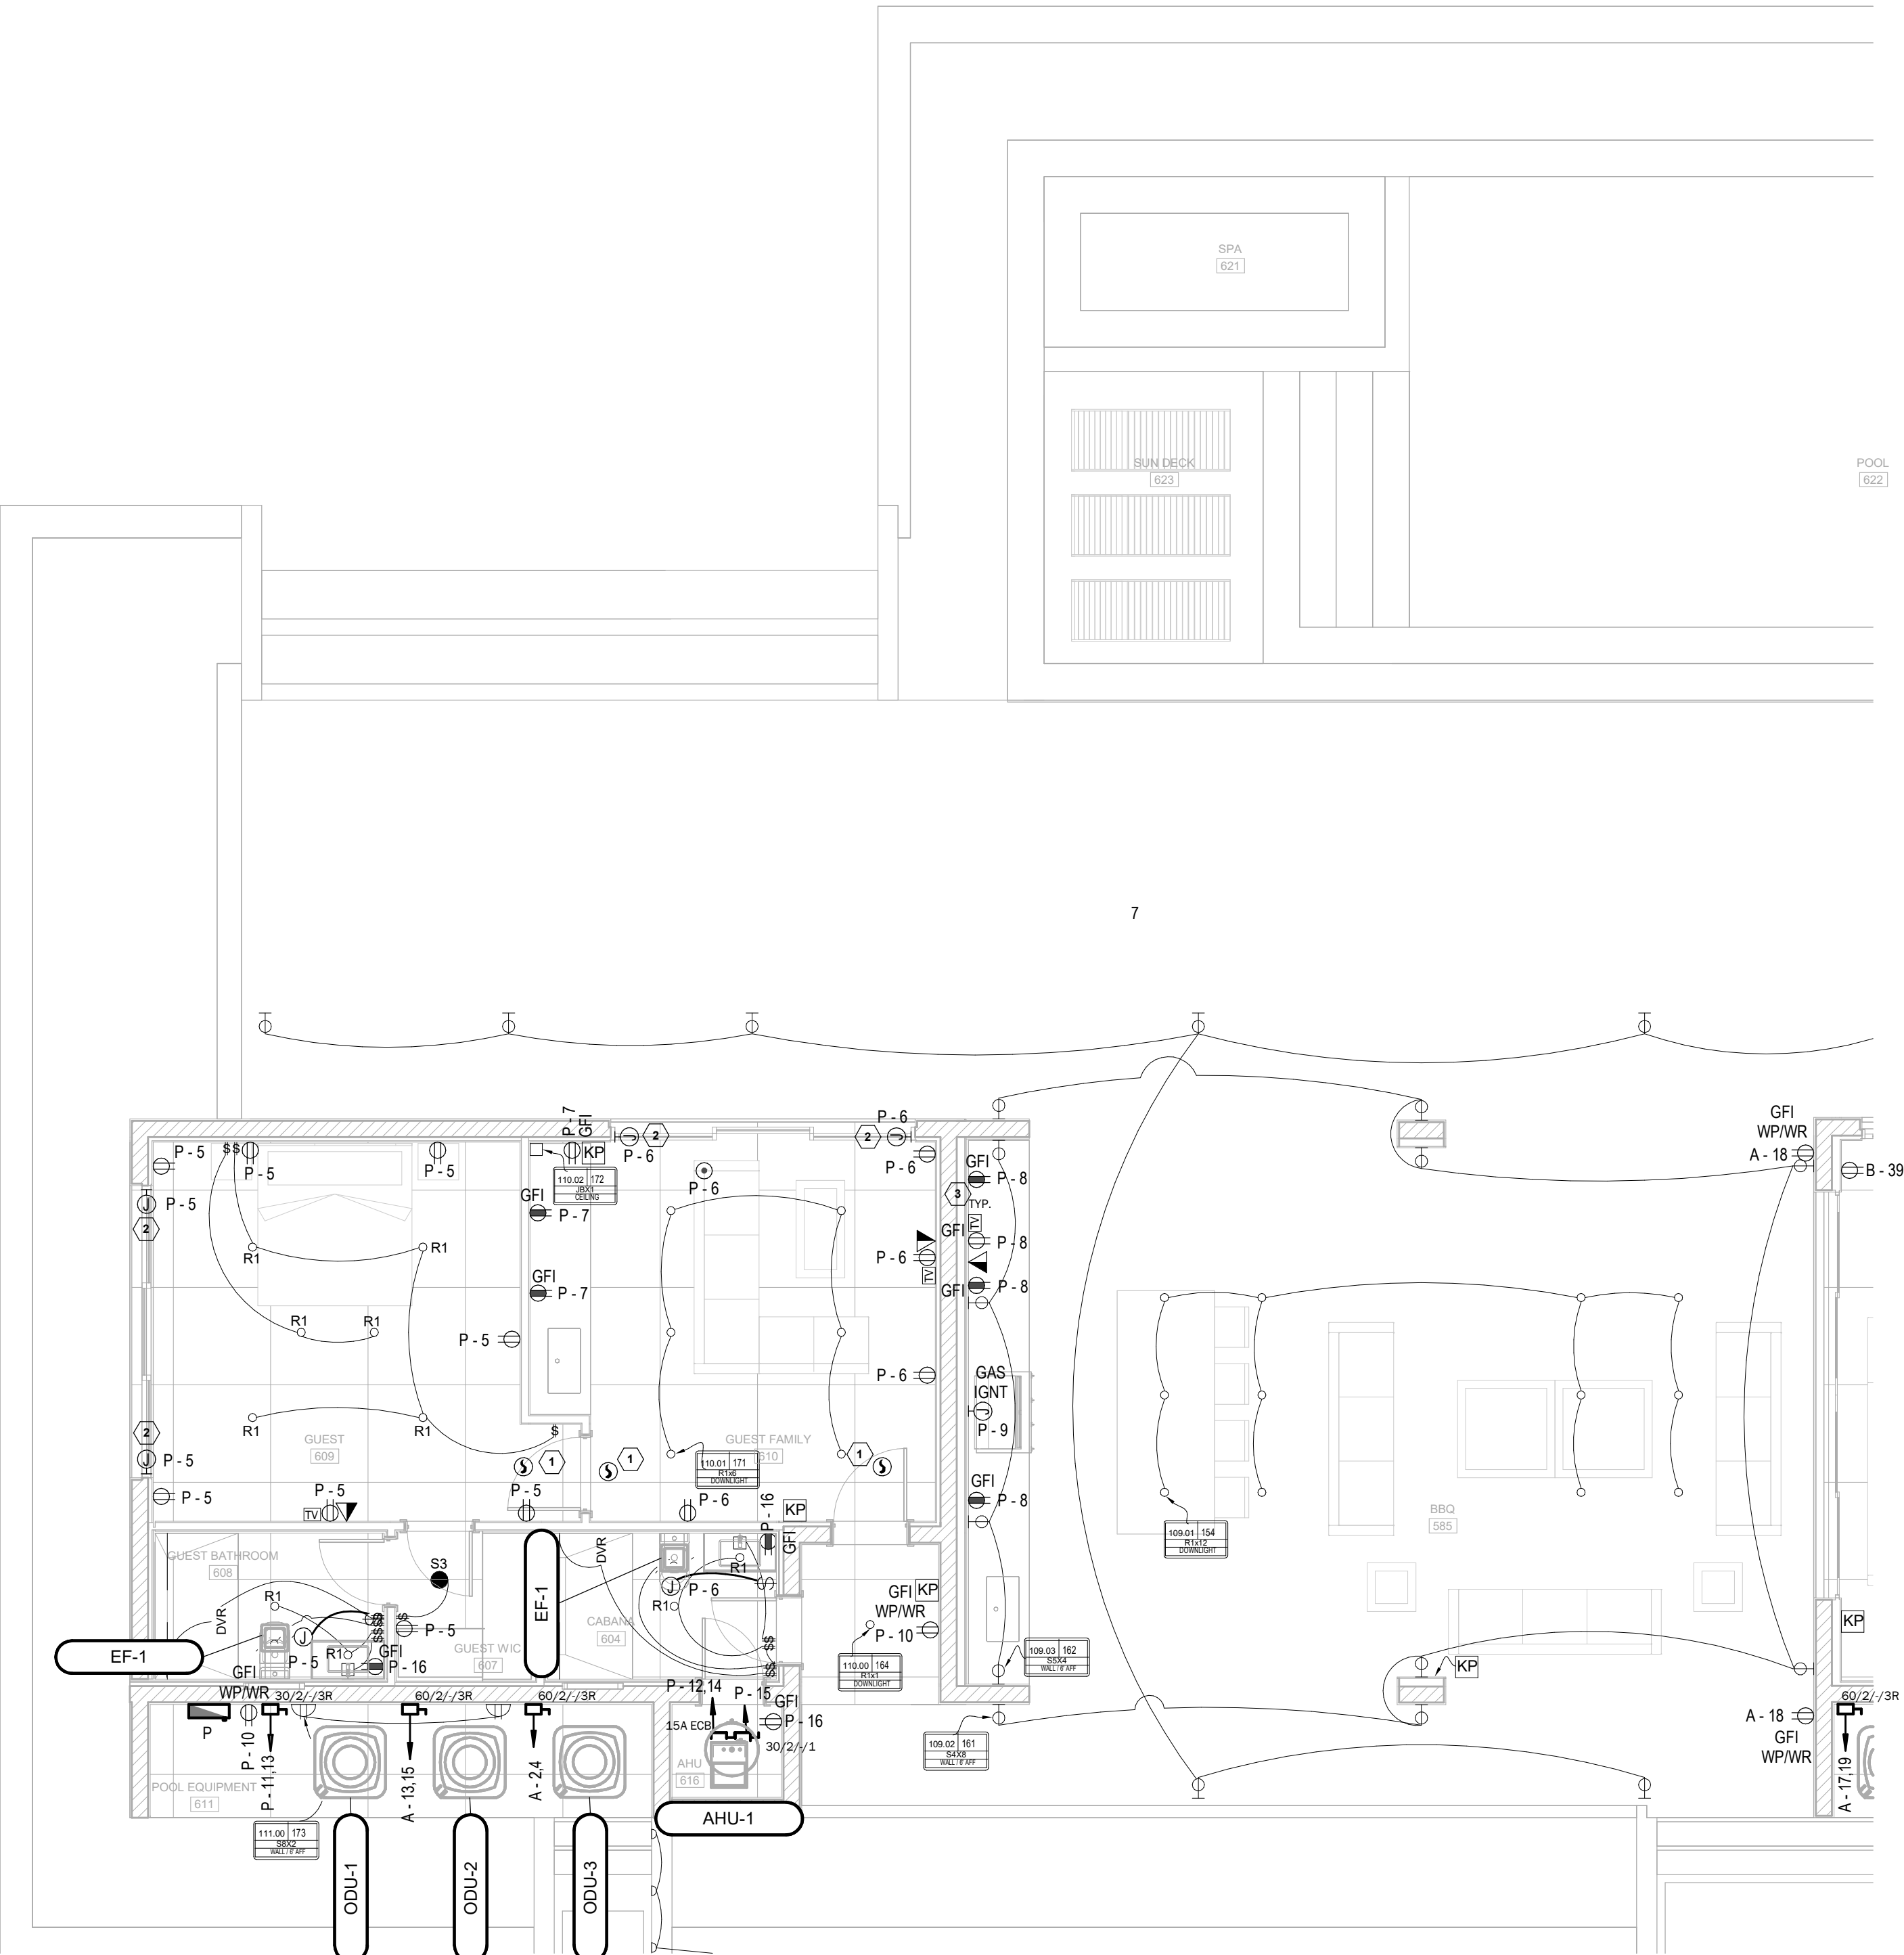

1 FIRST FLOOR PROPOSED PLAN - ELECTRICAL - AREA B
SCALE: 3/16" = 1'-0"



MIK ARCHITECTURE LLC
MATIAS DAROCH
AS-100480
1385 CORAL WAY, SUITE 202
MIAMI, FLORIDA 33145
+1 786 708 0860
mike@mikarch.com



AGD DEVELOPERS LLC
1385 CORAL WAY, SUITE 202
MIAMI, FLORIDA 33145
agdevelopers.com
developers@agdevelopers.com




R&D ENGINEERS, LLC
7701 NW 125th, Suite 207
CORAL GABLES, FLORIDA 33156
rdengineers.com
carla@rd-engineers.com

NEW SINGLE FAMILY RESIDENCE
AGD CALUSTONE LLC
10840 SW 67 Ave MIAMI, FL 33156

ISSUES JUN 2024 1ST ISSUED



READ PROJECT NO. 2025.512
DRAWN BY RV
CHECKED BY RD
SCALE AS NOTED
READ INCHES REGISTER NO. 37312

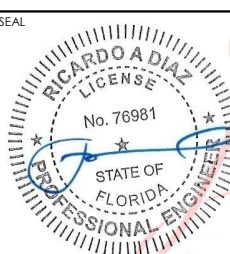

RICARDO A. DIAZ
PROFESSIONAL ENGINEER
PE 76981

THIS IS A DIGITALLY SIGNED SHEET. PRINTED COPIES OF THIS DOCUMENT ARE NOT CONSIDERED SIGNED AND SEALED AND THE SIGNATURE MUST BE VERIFIED ON THE ELECTRONIC COPIES.


THE CONTENT OF THIS SHEET AND ALL OTHER DRAWINGS ISSUED IN THE SET ARE PROTECTED BY U.S. AND INTERNATIONAL COPYRIGHT LAWS. REPRODUCTION OR USE WITHOUT PROPER WRITTEN CONSENT IS PROHIBITED BY LAW. SEE ALSO FOR DETAILS.

SHEET NO.

Digitally signed
by RICARDO A
DIAZ
Date: 2025.06.11
17:55:31 -04'00'

E-4


PROPOSED FIRST FLOOR ELECTRICAL
PLAN , AREA B

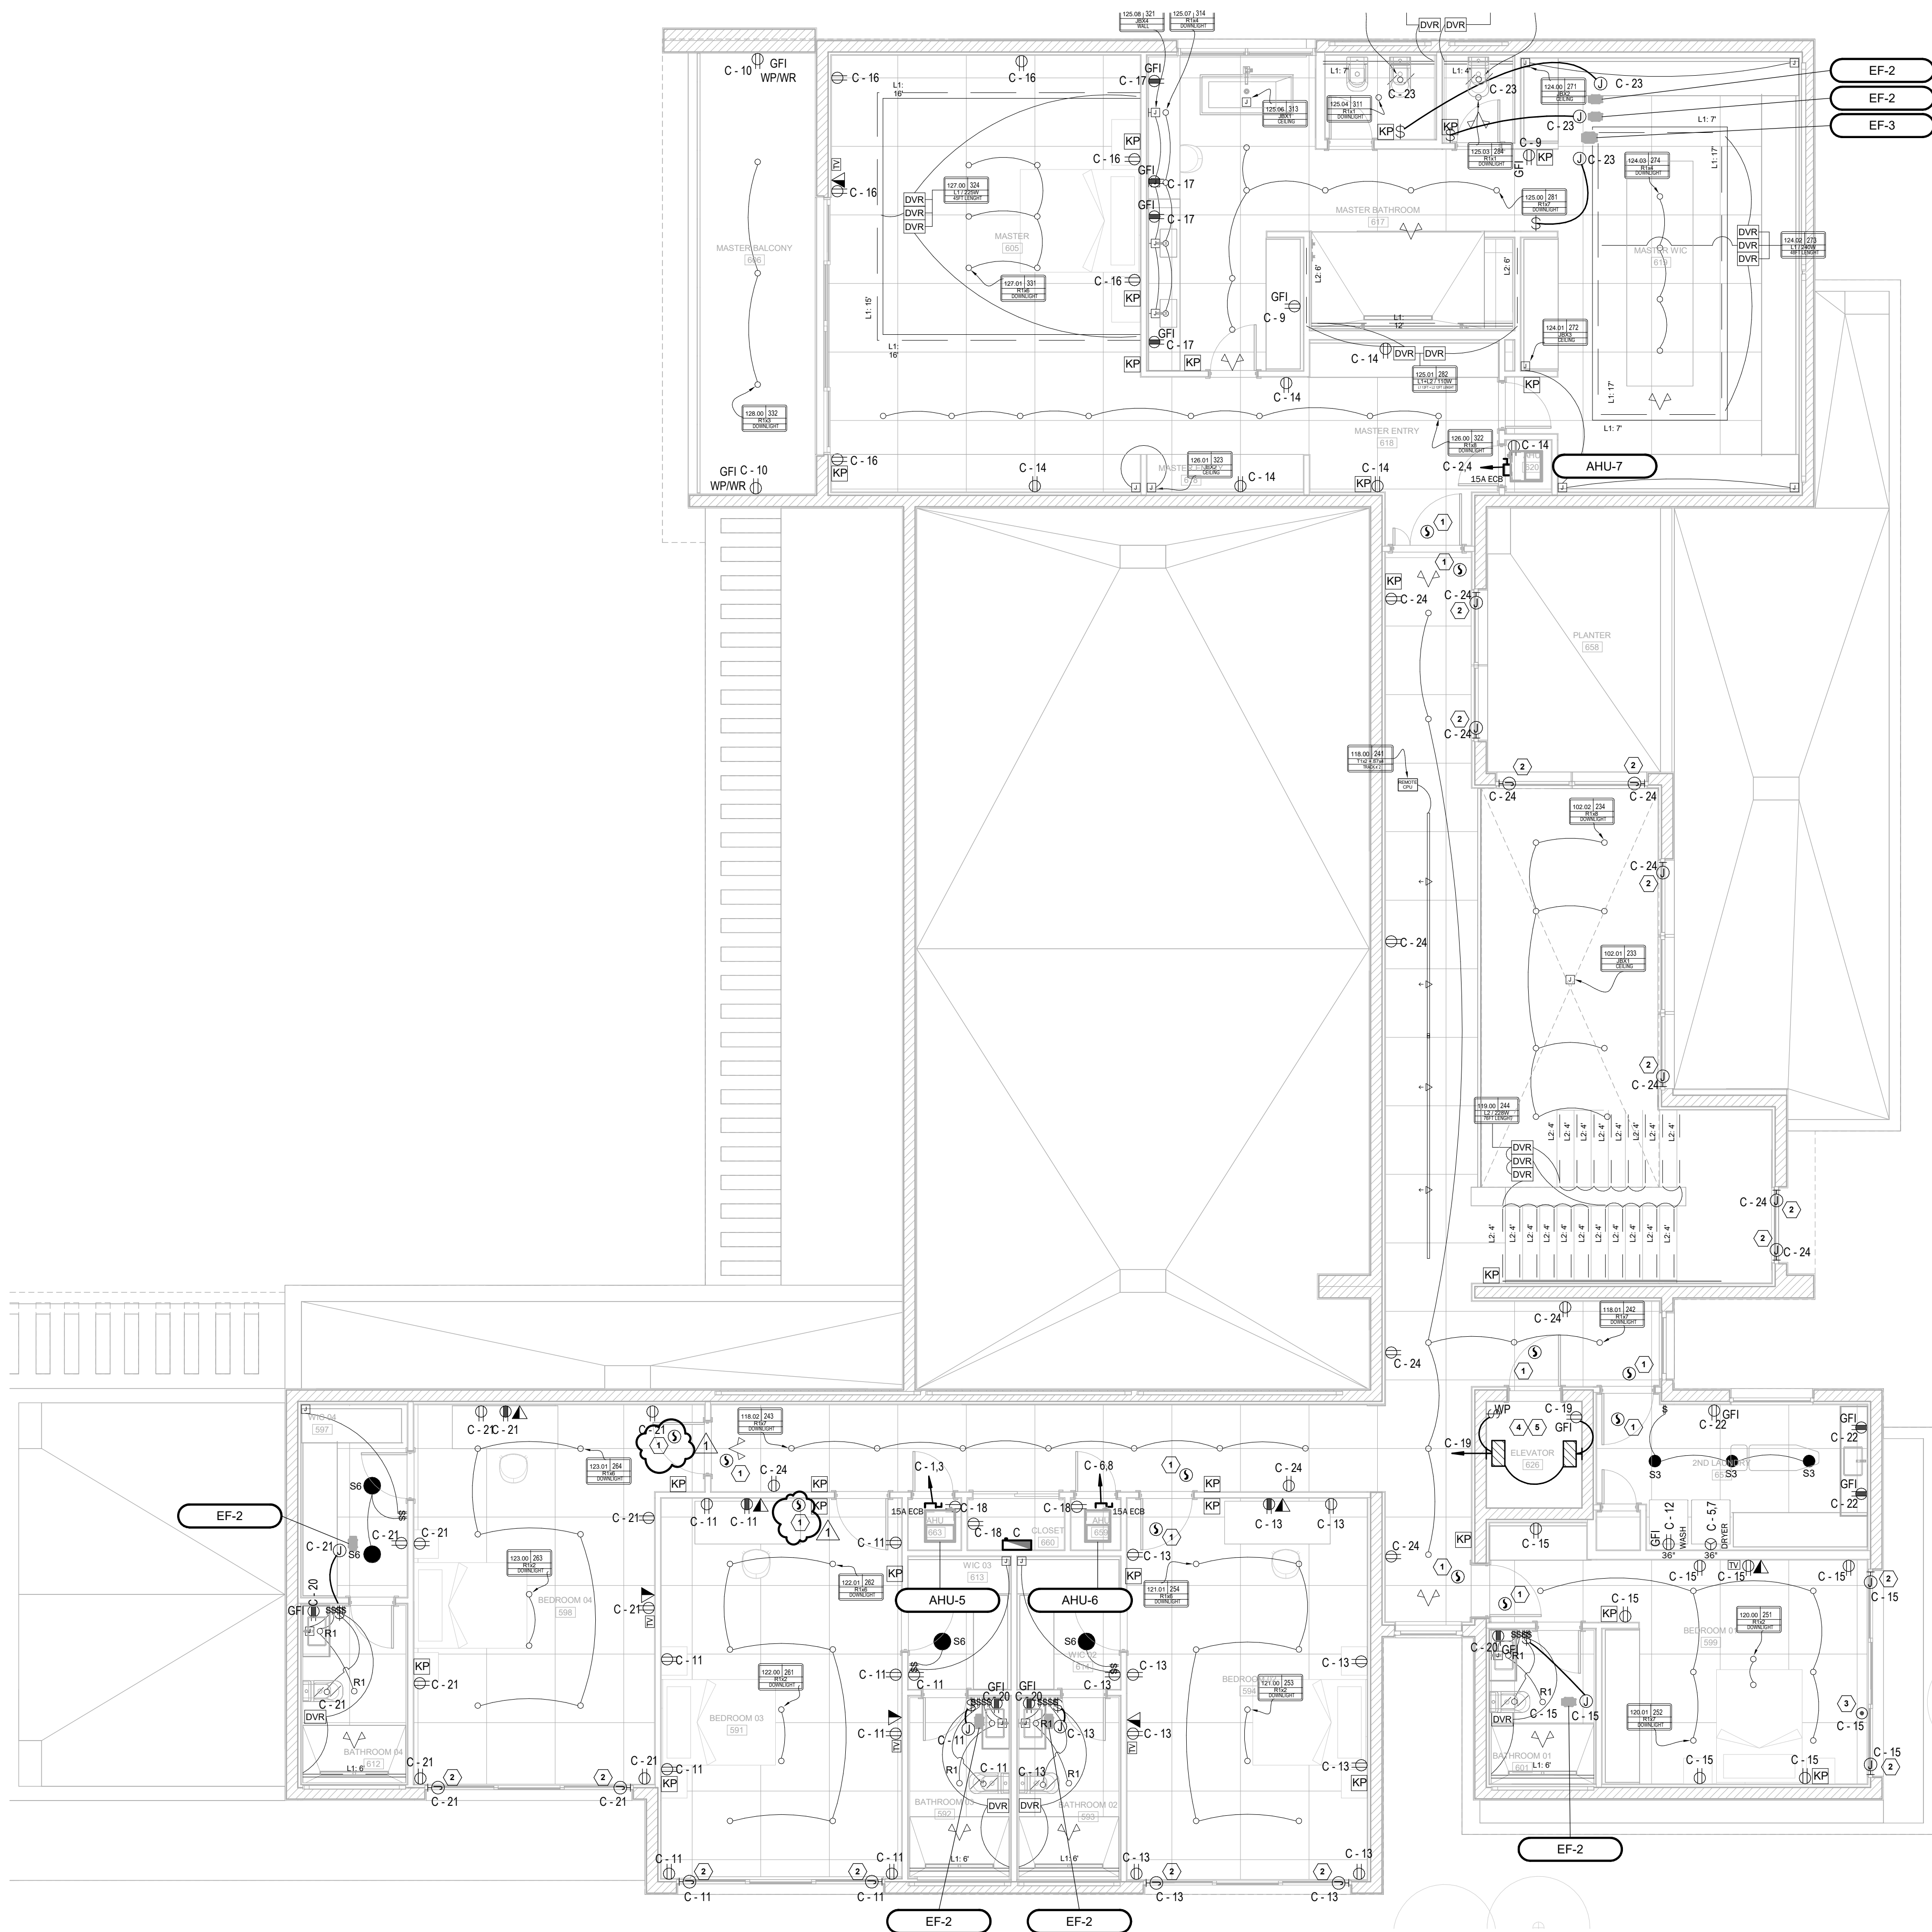

1 SECOND FLOOR PROPOSED PLAN - ELECTRICAL - AREA A
SCALE: 3/16" = 1'-0"

- ### GENERAL NEW WORK NOTES
- A. FURNISH AND INSTALL ALL WIRING AND RACEWAYS TO COMPLETE CIRCUITING AS INDICATED ON THESE DRAWINGS.
- B. COORDINATE EXACT LOCATION AND HEIGHT OF ALL RECEPTACLES AND DEVICES WITH ARCHITECTURAL ELEVATIONS AND DRAWINGS.
- C. FINAL LOCATION OF ALL RECEPTACLES SHALL BE COORDINATED WITH MILLWORK. REFER TO ARCHITECTURAL DRAWINGS.
- D. ALL ELECTRICAL BOXES TO BE INSTALLED STAGGERED. REFER TO ARCHITECTURAL DRAWINGS FOR DETAILS.
- E. PROVIDE ACCESSIBILITY IN FRONT OF THE SERVICE AS REQUIRED BY NEC 110.26A.
- F. ALL EQUIPMENT INSTALLED OUTSIDE SHALL BE SUITABLE FOR THE LOCATION AS REQUIRED PER NEC.
- G. WHEN GFI RECEPTACLE ACCESSIBILITY IS NOT ACHIEVED, GFI PROTECTION SHALL BE PROVIDED VIA GFI BREAKER.
- H. CONDUIT ROUTING SHOWN IS SCHEMATIC ONLY. CONTRACTOR SHALL CONFIRM EXACT ROUTING IN THE FIELD. COORDINATE EXACT REQUIREMENTS WITH STRUCTURAL DRAWINGS.

- ### LEGEND NOTES
- 1 PROVIDE COMBINATION SMOKE DETECTOR / CARBON MONOXIDE DETECTOR ALARM. ALL DEVICES SHALL BE INTERCONNECTED, SO THAT OPERATION OF ANY SMOKE OR CARBON MONOXIDE ALARM SHALL CAUSE THE ALARM OF ALL ALARMS WITHIN THE DWELLING UNIT TO SOUND (NFPA 101 SECTION 9.6.2.10.3)
- 2 JUNCTION BOX FOR POWER EXTENSION TO MOTORIZED SHADES. COORDINATE EXACT REQUIREMENTS WITH VENDOR.
- 3 FLOOR RECEPTACLE SHALL BE WITHIN 12" FROM THE GLASS WALL.
- 4 PROVIDE A MIN. ILLUMINATION OF 19 FC AT TOP OF SHAFT.
- 5 ELEVATOR PROVIDED WITH UPS FOR EMERGENCY LOWERING.

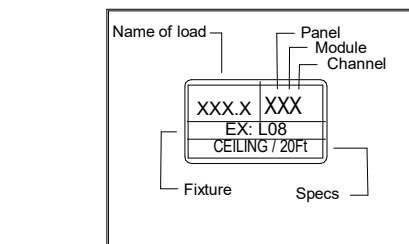

- ### LIGHTING LEGEND
- Downlight Recessed Fijo R1
 - Downlight Surface S2,S3
 - Wall Washer Recessed R4
 - Uplight Recessed R3
 - ◀ Spotlight (Aimed) S7
 - Downlight Linear Led R6
 - LED Strip L1, L2
 - ⊥ Appliqué S4, S5, S9, S11
 - Rail 1000mm, T1, T2, T3
 - J BOX
 - ▷ Wall washer R5
 - LED Strip L3
 - Downlight Surface Aimable S1
 - ◁ Wall wash S10
 - ▷ Wall wash R5

MIK ARCHITECTURE

MIK ARCHITECTURE LLC
MATIAS DAROCH
AS-100483
1385 CORAL WAY, SUITE 202
MIAMI, FLORIDA 33145
+1 786 538 0880
mik@mikarch.com

AGD DEVELOPERS LLC

1385 CORAL WAY, SUITE 202
MIAMI, FLORIDA 33145
agdev.com
developers@agdev.com

R&D ENGINEERS, LLC

7763 NW 12TH ST., SUITE 202
CORAL, FLORIDA 33024
rd@rlandengineers.com
coral@rlandengineers.com

NEW SINGLE FAMILY RESIDENCE
AGD CALISTONE LLC
10840 SW 67 Ave MIAMI, FL 33156

ISSUES

NO.	DATE	DESCRIPTION
06.10.25	BLDG DEPT COMMENTS	

RED PROJECT NO: 2025.512
DRAWN BY: RV
CHECKED BY: RD
SCALE: AS NOTED
RED ENGINEERS REGISTRY NO: 37312
SEA:

Digitally signed by RICARDO A DIAZ
Date: 2025.06.11 17:55:39 -04'00'

RICARDO A. DIAZ
PROFESSIONAL ENGINEER
PE 76981



THIS IS A DIGITALLY SIGNED SHEET. PRINTED COPIES OF THIS DOCUMENT ARE NOT CONSIDERED VALID AND SHOULD BE VERIFIED ON THE ORIGINAL COPY.

THE CONTENT OF THIS SHEET AND ALL OTHER DRAWINGS ISSUED IN THE SET ARE PROTECTED BY U.S. AND INTERNATIONAL COPYRIGHT LAWS. REPRODUCTION OR USE WITHOUT PROPER WRITTEN CONSENT IS PROHIBITED BY LAW. SEE ADD FOR DETAILS.

SHEET NO.

E-5

PROPOSED SECOND FLOOR ELECTRICAL PLAN , AREA A

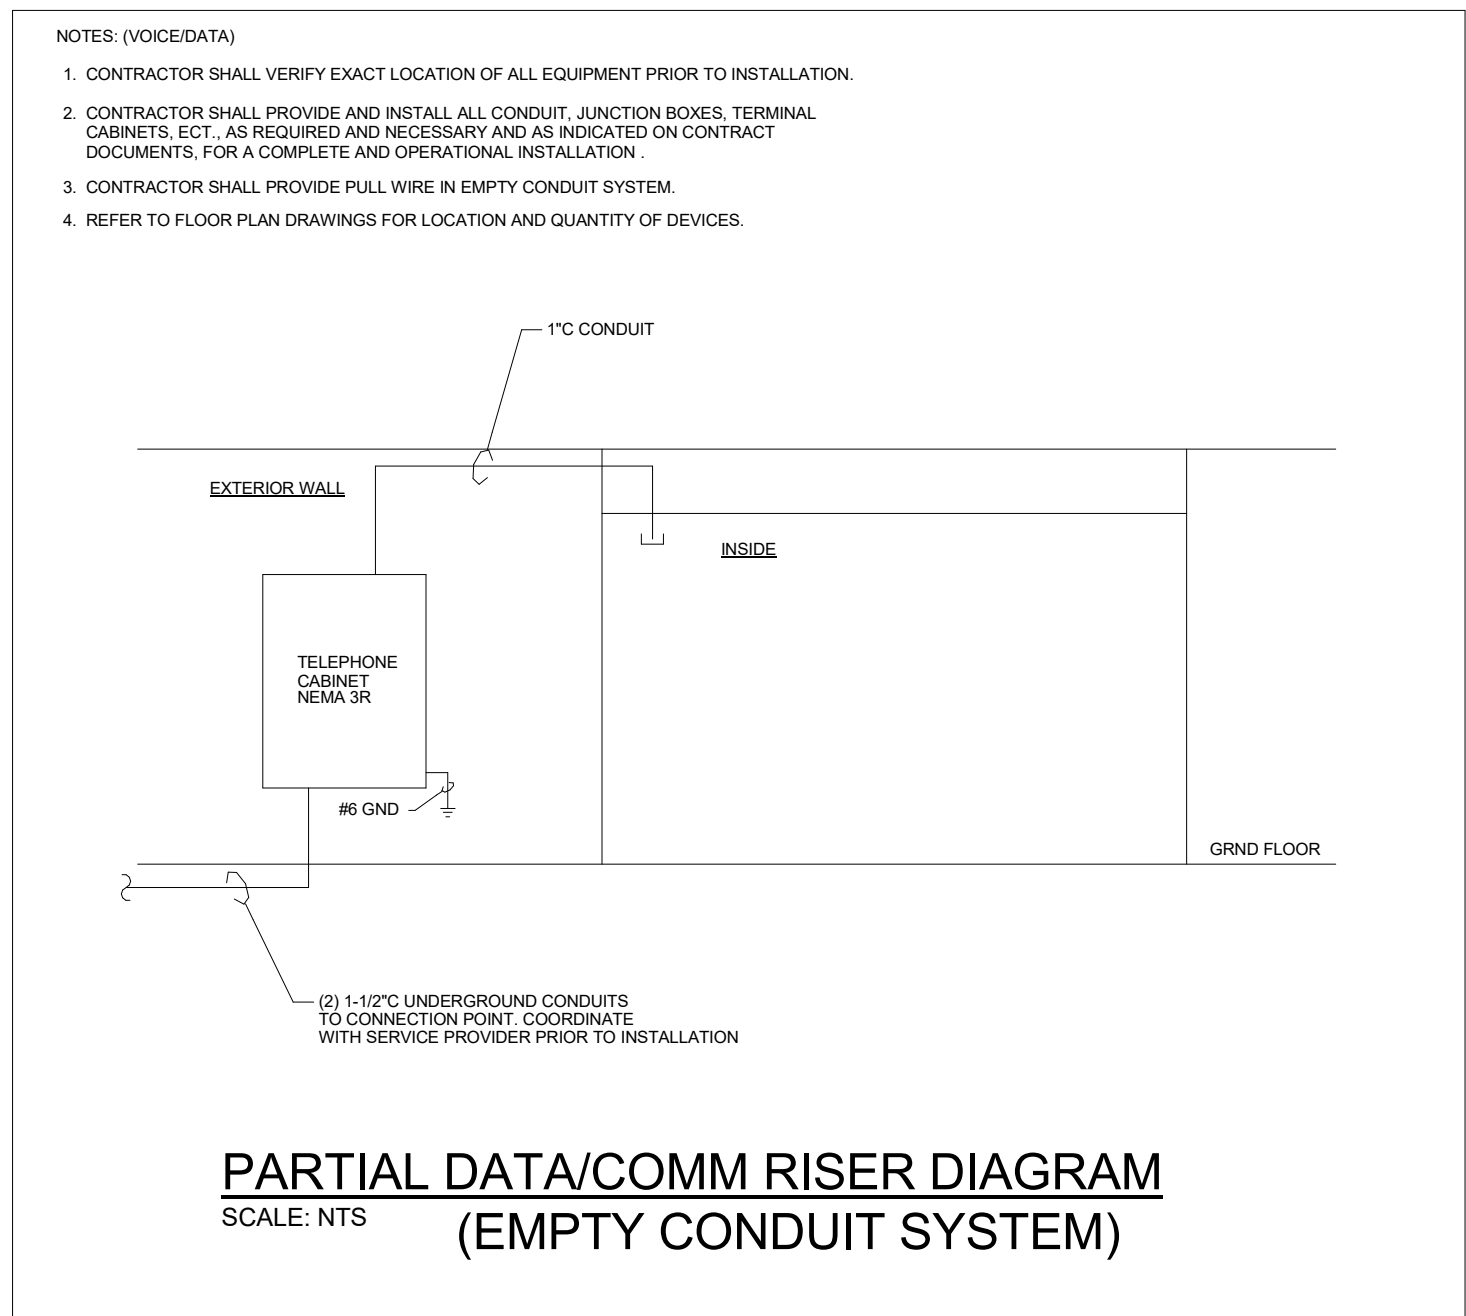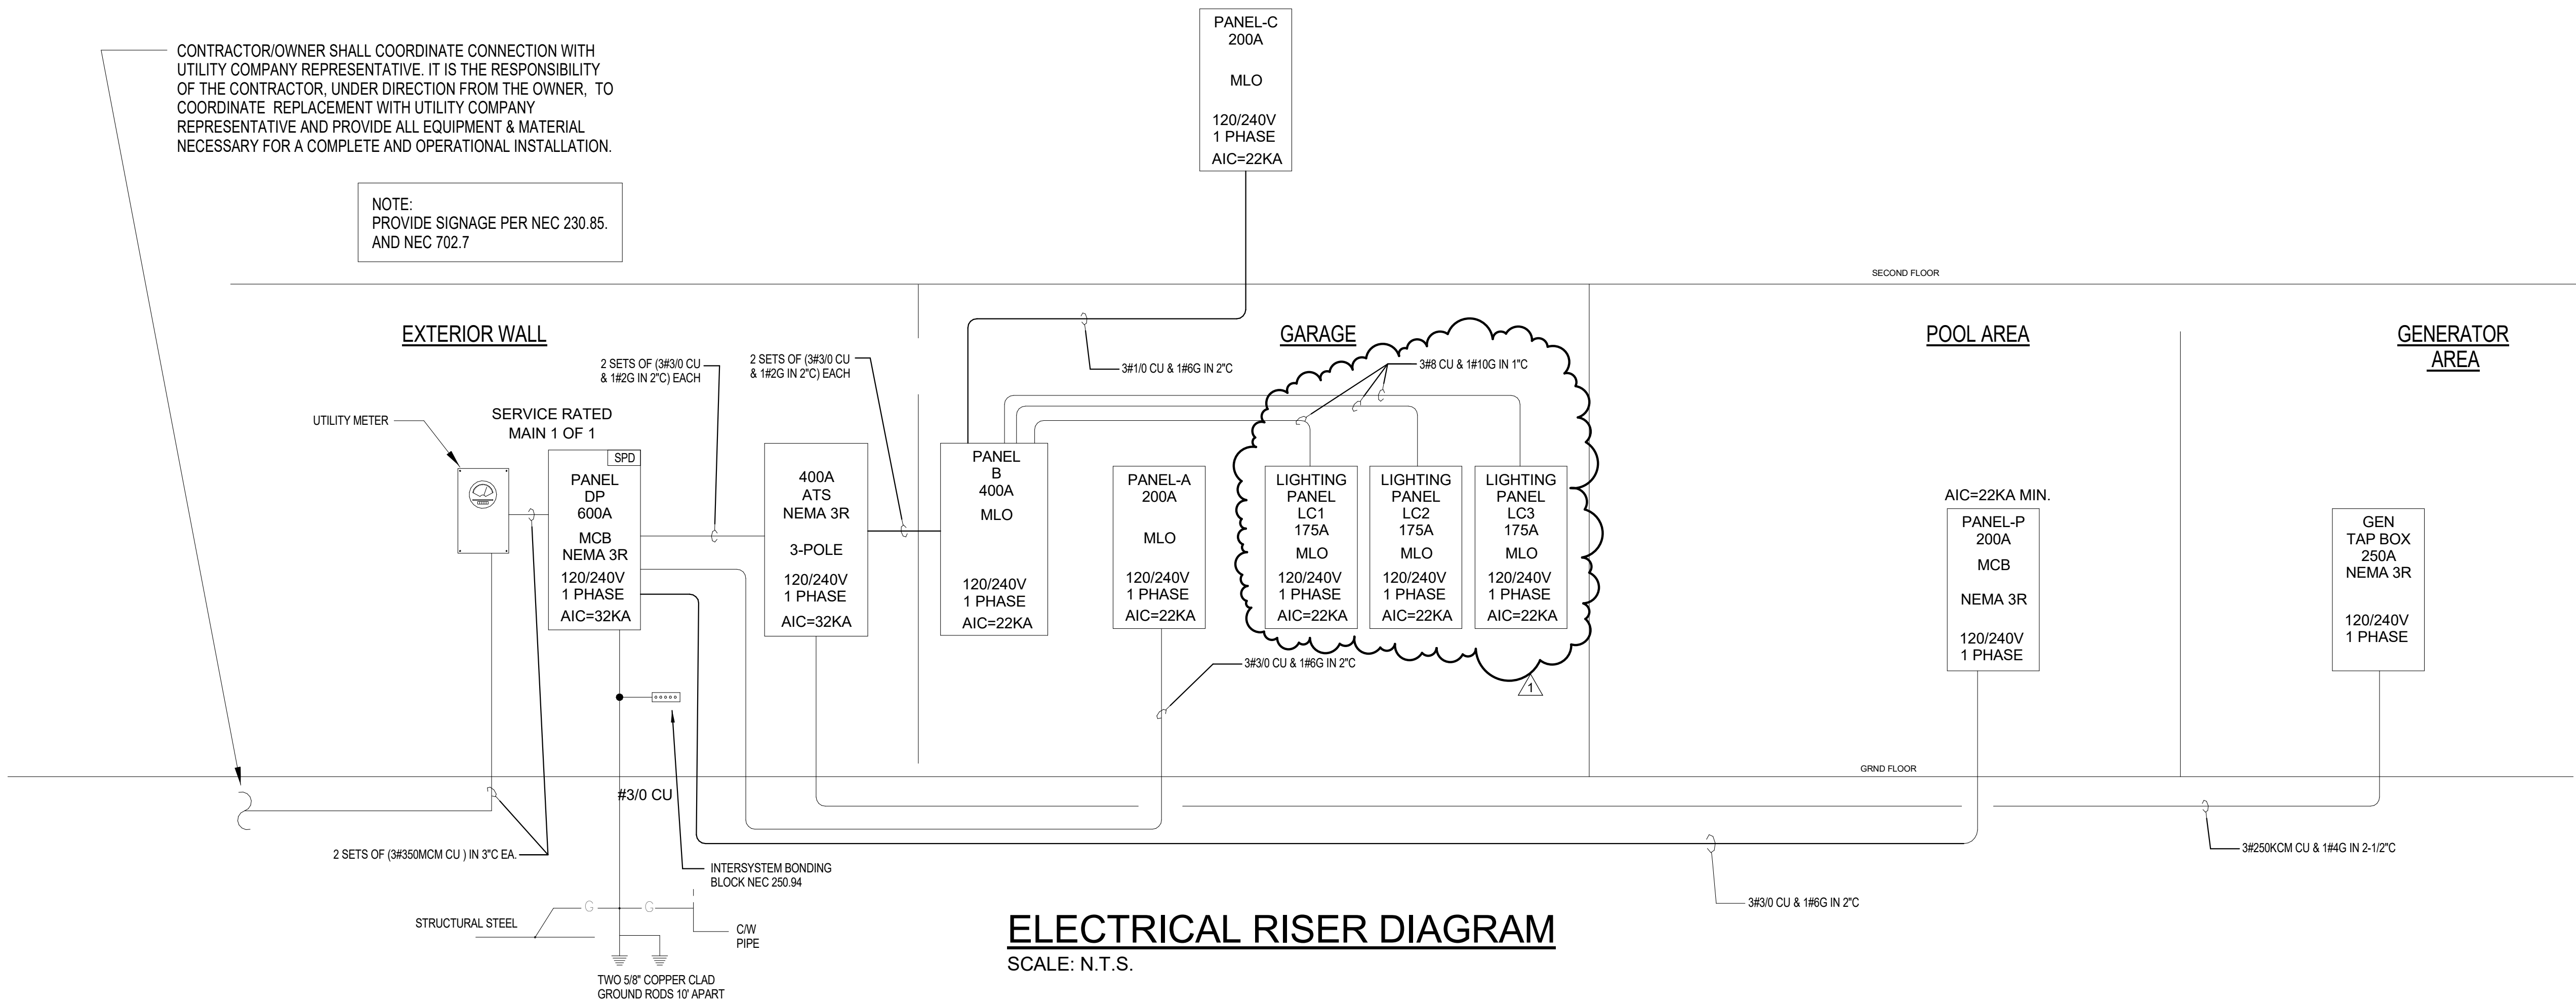

MIK ARCHITECTURE LLC
MATIAS DAROCH
AS-100485
1385 CORAL WAY, SUITE 202
MIAMI, FLORIDA 33145
+1 786 708 0880
mik@mikarch.com



AGD DEVELOPERS LLC
1385 CORAL WAY, SUITE 202
MIAMI, FLORIDA 33145
agdevops.com
devops@agdevops.com



R&D ENGINEERS LLC
7925 NW 12TH ST, SUITE 202
CORAL, FLORIDA 33026
rd@rdengineers.com
rd@rdengineers.com

NEW SINGLE FAMILY RESIDENCE
AGD CALISTONE LLC
10840 SW 67 Ave MIAMI, FL 33156

ISSUES
JUN 2024 1ST ISSUED
06.10.25 BLDG DEPT COMMENTS

R&D PROJECT NO: 2025.512
DRAWN BY: RV
CHECKED BY: RD
SCALE: AS NOTED
R&D ENGINEERS REGISTRY NO: 37312

SEAL
RICARDO A. DIAZ
No. 76981
STATE OF FLORIDA
PROFESSIONAL ENGINEER
Date: 2025.06.11 17:55:47 -04'00'

THIS IS A DIGITALLY SIGNED SHEET. PRINTED COPIES OF THIS DOCUMENT ARE NOT CONSIDERED SIGNED AND SHOULD BE SIGNED AND BE VERIFIED ON ANY ELECTRONIC COPIES.

THE CONTENT OF THIS SHEET AND ALL OTHER DRAWINGS ISSUED BY THE SET ARE PROTECTED BY U.S. AND INTERNATIONAL COPYRIGHT LAWS. REPRODUCTION OR USE WITHOUT PROPER WRITTEN CONSENT IS PROHIBITED BY LAW. SEE ADD FOR DETAILS.

SHEET NO:

E-6

ELECTRICAL RISER DIAGRAMS

GENERAL ELECTRICAL NOTES

1. ALL WORK SHALL BE DONE IN ACCORDANCE WITH THE NATIONAL ELECTRICAL CODE (N.E.C. 2020), 2023 FBC, 2021 NFPA-101, 2021 NFPA-1. ALL MATERIAL SHALL BE NEW AND SHALL BEAR THE U.L. LABEL WHERE APPLICABLE.
2. CONTRACTOR SHALL MAKE ALL NECESSARY CUTTING AND DO ALL THE REPATCHING AS NECESSARY FOR THE PROPER EXECUTION OF THIS WORK.
3. AFTER COMPLETION OF THE INSTALLATION, THE SYSTEM SHALL TEST FREE FROM SHORT CIRCUITS AND GROUNDS.
4. WHERE ELECTRICAL CONDUCTORS ARE INSTALLED IN CONDUIT, THE CONDUIT SHALL COMPLY WITH THE N.E.C. REQUIREMENTS.
5. ALL CONDUCTORS SHALL BE COPPER, NO CONDUCTOR SHALL BE SMALLER THAN #12 AWG AND SHALL BE RATED FOR 600 VOLTS THWN OR THHN INSULATION. INSTALL A GROUNDING CONDUCTOR WITH ALL CIRCUITS, UNLESS NOTED OTHERWISE, SIZED PER N.E.C. 250-122.
6. VERIFY BREAKER AND CORRESPONDING WIRE SIZES FOR ALL ELECTRICAL EQUIPMENT. DO NOT ORDER MATERIAL BEFORE VERIFYING BREAKER AND WIRE SIZE. REPORT ANY DISCREPANCY IMMEDIATELY TO THE ENGINEER OF RECORD.
7. VERIFY AVAILABLE INTERRUPTING CURRENT (AIC) WITH POWER COMPANY. EQUIPMENT AIC RATING MUST BE LARGER THAN THE POWER COMPANY AIC.
8. SAFETY SWITCHES SHALL BE SQUARE 'D', GENERAL ELECTRIC, OR WESTINGHOUSE, FUSED OR NON-FUSED AND SIZED AS INDICATED, NEMA 3R WHEN EXPOSED TO WEATHER.
9. PANELS SHALL BE SQUARE 'D', GENERAL ELECTRIC OR EQUAL, TYPE AND NUMBER OF BREAKERS AS INDICATED ON PANEL SCHEDULE. STENCIL PANEL DESIGNATION ON INSIDE OF PANEL. ALL TWO-POLE BREAKERS SHALL BE COMMON TRIP. PROVIDE TYPE WRITTEN SCHEDULE IN EACH LOAD CENTER. CONNECTION TO MAIN BUS SHALL BE WITH BURNDY ANNULAR COMPRESSION LUGS.
10. ALL EXTERIOR ELECTRICAL EQUIPMENT SHALL BE ANCHORED TO COMPLY WITH LOCAL CODE FOR WIND RESISTANCE.
11. IT IS NOT THE INTENT OF THESE PLANS TO SHOW EVERY MINOR DETAIL OF CONSTRUCTION. THE CONTRACTOR IS EXPECTED TO FURNISH AND INSTALL ALL ITEMS FOR A COMPLETE ELECTRICAL SYSTEM AND PROVIDE ALL REQUIREMENTS NECESSARY FOR EQUIPMENT TO BE PLACED IN PROPER WORKING ORDER.
12. ALL WORK SHALL BE PERFORMED BY A LICENSED ELECTRICAL CONTRACTOR IN A FIRST CLASS WORKMANLIKE MANNER. THE COMPLETED SYSTEM SHALL BE FULLY OPERATIVE AND ACCEPTED BY THE OWNER.
13. LOAD DATA IS BASED ON INFORMATION GIVEN ENGINEER AT TIME OF DESIGN. VERIFY ALL EQUIPMENT AND PANEL SIZES BEFORE ORDERING AND BEFORE INSTALLATION.
14. ALL ELECTRICAL AND COMMUNICATIONS OUTLETS TO BE AT 15" A.F.F. TO BOTTOM OF OUTLET UNLESS OTHERWISE NOTED, ALL LIGHT SWITCHES SHALL BE @ 42" A.F.F. TO BOTTOM OF SWITCH.
15. SERVICE MUST BE 3' ABOVE MSL, VERIFY AT SITE.
16. CONTRACTOR MUST VISIT THE SITE PRIOR TO BID OR CONSTRUCTION TO VERIFY ALL EXISTING CONDITIONS.
17. WHEN NEW ELECTRIC SERVICE IS BEING INSTALLED, IT IS THE GENERAL CONTRACTOR'S RESPONSIBILITY TO COORDINATE WITH FPL/FPL ENGINEERS ON THE SIZE OF THE FPL TRANSFORMER THAT IS REQUIRED TO PROVIDE THE NEW ELECTRIC SERVICE SHOWN ON ELECTRIC PLANS. GC HAS TO INFORM THE OWNER ABOUT ANY EXTRA FPL CHARGES THAT MIGHT OCCUR IN ORDER TO PULL NEW SERVICE. THIS HAS TO BE DONE AS EARLY AS POSSIBLE DURING THE BIDDING PROCESS.
18. INSTALL 4 CONDUCTORS FOR ALL COOKING UNITS AND DRYERS TO COMPLY WITH NEC 250.140.
19. MEANS SHALL BE PROVIDED TO SIMULTANEOUSLY DISCONNECT EACH APPLIANCE FROM ALL UNGROUNDED CONDUCTORS PER NEC 422.30. (INCLUDING INSTANT WATER HEATER)
20. LIGHT FIXTURES IN RETURN AIR PLENUMS SHALL BE PLENUM RATED.
21. WIRING, BOXES AND EQUIPMENT IN RETURN AIR PLENUMS SHALL BE PLENUM RATED.
22. ALL AV EQUIPMENT IN PLENUM MECHANICAL ROOMS SHALL BE PLENUM RATED.

NOTES:
ALL NEW EXTERIOR RECEPTACLES TO BE RECESSED.

PER N.E.C. 2020 406.9
ALL NEW RECEPTACLES IN DAMP LOCATIONS INDICATED AS WEATHERPROOF ON PLAN (WP) SHALL HAVE AN ENCLOSURE THAT IS WEATHERPROOF WHETHER OR NOT THE ATTACHMENT PLUG CAP IS INSERTED.
ALL NEW RECEPTACLES IN WET LOCATIONS INDICATED AS WEATHER-RESISTANT ON PLAN (WR) SHALL HAVE AN ENCLOSURE THAT IS WEATHER-PROOF WHETHER OR NOT THE ATTACHMENT PLUG CAP IS INSERTED. NONLOCKING RECEPTACLES SHALL BE LISTED WEATHER-RESISTANT TYPE.

PER N.E.C. 2020 406.12 ALL NEW 120V, 15A AND 20A RECEPTACLES INSTALLED IN ALL AREAS (KITCHEN, FAMILY ROOM, DINING ROOM, LIVING ROOM, PARLOR, LIBRARY, DEN AND RECREATION ROOM) SHALL BE LISTED TAMPER RESISTANT RECEPTACLES.

PER FLORIDA BUILDING CODE 2023 ENERGY CONSERVATION:

SECTION 404

ELECTRICAL POWER AND LIGHTING SYSTEMS

404.1 NOT LESS THAN 90 PERCENT OF THE LAMPS IN PERMANENTLY INSTALLED LUMINAIRES SHALL HAVE AN EFFICACY OF AT LEAST 45 LUMENS-PER-WATT OR SHALL UTILIZE LAMPS WITH AN EFFICACY OF NOT LESS THAN 65 LUMENS-PER-WATT.

ELECTRICAL CODE NOTES:

THESE NOTES TAKE PRECEDENCE IF THERE IS ANY DISCREPANCY WITH THE PLANS.

ALL BATHROOMS, GARAGES, EXTERIOR RECEPTACLES, KITCHEN APPLIANCE CIRCUITS, DINING ROOM RECEPTACLES, AND BREAKFAST ROOM TO BE ON 20 AMP BREAKERS.

ALL 120V THROUGH 250V RECEPTACLES IN BATHROOMS, GARAGES, EXTERIOR RECEPTACLES, KITCHEN RECEPTACLES, SHALL HAVE GROUND FAULT CURRENT INTERRUPTER (GFCI) PROTECTION .

ALL EXTERIOR RECEPTACLES TO BE WEATHER RESISTAN WITH WEATHER PROOF ENCLOSURE WHILE IN USE.

ALL 15 AMP AND 20 AMP 120V ELECTRICAL CIRCUITS SHALL HAVE ARC FAULT CURRENT INTERRUPTER BREAKERS. (RECEPTACLES, LIGHTS, SWITCHES, FANS, SMOKE DETECTORS).

SMOKE DETECTORS TO BE HARD WIRED 110V WITH BATTERY BACKUP AND ON KITCHEN OR BATHROOM LIGHTING CIRCUITS. INTERCONNECTED AHEAD OF SWITCHES. ALL SMOKE DETECTORS SHALL BE MOUNTED AT THE HIGHEST POINT OF THE CEILING PER ROOM.

DO NOT MOUNT SMOKE DETECTORS WITHIN 3 FEET OF BATHROOM DOOR OR HVAC DIFFUSERS OR TIP OF FAN BLADE.

ALL RECEPTACLES TO BE TAMPER RESISTANT PER NEC 2017 406.12.

SMOKE DETECTORS WITHIN 20FT HORIZONTAL PATH OF COOKING APPLIANCES SHALL BE EQUIPPED WITH ALARM SILENCING MEANS OR BE PHOTOELECTRIC TYPE.

MORE THAN 12 INTERCONNECTED SMOKE DETECTORS ARE REQUIRED TO BE SUPERVISED (ALARM COMPANY MUST BE CONTRACTED FOR MONITORING).

ESSENTIAL SWITCHES AND CONTROLS TO BE LOCATED BETWEEN 42" AND 52" FROM THE FLOOR AS PER THE STATE ACCESSIBILITY CODE.

ALL RECEPTACLES TO BE @ 15" A.F.F. TO BOTTOM OF RECEPTACLE UNLESS NOTED OTHERWISE OR ABOVE COUNTER.

ALLOWED LUMINAIRES IN CLOTH CLOSETS:

SURFACE MOUNTED OR RECESSED (FIXTURE) WITH A COMPLETELY ENCLOSED LAMP.

PER FLORIDA BUILDING CODE 2023 ENERGY CONSERVATION:

405.7.3 VOLTAGE DROP.

405.7.3.1 FEEDERS AND CUSTOMER OWNED SERVICE CONDUCTORS. FEEDER AND CUSTOMER OWNED SERVICE CONDUCTORS SHALL BE SIZED FOR A MAXIMUM VOLTAGE DROP OF 2 PERCENT AT DESIGN LOAD.
405.7.3.2 BRANCH CIRCUITS. BRANCH CIRCUIT CONDUCTORS SHALL BE SIZED FOR A MAXIMUM VOLTAGE DROP OF 3 PERCENT AT DESIGN LOAD.

405.7.4 COMPLETION REQUIREMENTS.

405.7.4.1 DRAWINGS. CONSTRUCTION DOCUMENTS SHALL REQUIRE THAT WITHIN 30 DAYS AFTER THE DATE OF SYSTEM ACCEPTANCE, RECORD DRAWINGS OF THE ACTUAL INSTALLATION SHALL BE PROVIDED TO THE BUILDING OWNER. INCLUDING:

1. A SINGLE-LINE DIAGRAM OF THE BUILDING ELECTRICAL DISTRIBUTION SYSTEM AND
2. FLOOR PLANS INDICATING LOCATION AND AREA SERVED FOR ALL DISTRIBUTION.

405.7.4.2 MANUALS. CONSTRUCTION DOCUMENTS SHALL REQUIRE THAT AN OPERATING MANUAL AND MAINTENANCE MANUAL BE PROVIDED TO THE BUILDING OWNER. THE MANUALS SHALL INCLUDE, AT A MINIMUM, THE FOLLOWING:
1. SUBMITTAL DATA STATING EQUIPMENT RATING AND SELECTED OPTIONS FOR EACH PIECE OF EQUIPMENT REQUIRING MAINTENANCE
2. OPERATION MANUALS AND MAINTENANCE MANUALS FOR EACH PIECE OF EQUIPMENT REQUIRING MAINTENANCE. REQUIRED ROUTINE MAINTENANCE ACTIONS SHALL BE CLEARLY IDENTIFIED.
3. NAMES AND ADDRESSES OF AT LEAST ONE QUALIFIED SERVICE AGENCY.
NOTE: ENFORCEMENT AGENCIES SHOULD ONLY CHECK TO BE SURE THAT THE CONSTRUCTION DOCUMENTS REQUIRE THIS INFORMATION TO BE TRANSMITTED TO THE OWNER AND SHOULD NOT EXPECT COPIES OF ANY OF THE MATERIALS.

405.3 TANDEM WIRING :

LUMINAIRES DESIGNED FOR USE WITH ONE OR THREE LINEAR FLUORESCENT LAMPS GREATER THAN 30 W EACH SHALL BE TANDEM WIRED WHEN TWO OR MORE LUMINAIRES ARE IN THE SAME SPACE AND ON THE SAME CONTROL DEVICE.

EXCEPTIONS:

1. RECESSED LUMINAIRES MORE THAN 10 FEET APART MEASURED CENTER TO CENTER.
2. SURFACE-MOUNTED OR PENDANT LUMINAIRES THAT ARE NOT CONTINUOUS.
3. LUMINAIRES USING THREE-LAMP HIGH-FREQUENCY ELECTRONIC OR THREE-LAMP ELECTROMAGNETIC BALLASTS.
4. RECESSED LUMINAIRES MORE THAN 10 FEET APART MEASURED CENTER TO CENTER.
5. SURFACE-MOUNTED OR PENDANT LUMINAIRES THAT ARE NOT CONTINUOUS.
6. LUMINAIRES USING THREE-LAMP HIGH-FREQUENCY ELECTRONIC OR THREE-LAMP ELECTROMAGNETIC BALLASTS.

BRANCH CIRCUIT VOLTAGE DROP MAXIMUM 3% PER 2023 FBC

CIRCUIT LOAD IN AMPS	WIRE SIZE COPPER	MAXIMUM LENGTH IN FEET
5 AMPS OR LESS	#12 AWG	180
6 AMPS	#12 AWG	150
7 AMPS	#12 AWG	130
8 AMPS	#12 AWG	115
9 AMPS	#12 AWG	100
10 AMPS	#12 AWG	90
11 AMPS	#12 AWG	85
12 AMPS	#12 AWG	75
13 AMPS	#12 AWG	70
14 AMPS	#12 AWG	65
15 AMPS	#12 AWG	60
16 AMPS	#12 AWG	57
17 AMPS	#12 AWG	54
18 AMPS	#12 AWG	51
19 AMPS	#12 AWG	48
20 AMPS	#12 AWG	45

Branch Panel: PANEL DP

Location: HOUSE EQUIPMENT AREA
Supply From: FPL
Mounting: Surface
Enclosure: Type 1

Volts: 120/240 Single
Phases: 1
Wires: 3

A.I.C. Rating: 32,000 A
Mains Type: MCB
Mains Rating: 600 A
MCB Rating: 600 A

Notes:

CKT	Circuit Description	Trip	Poles	A	B	Poles	Trip	Circuit Description	CKT
1	PANEL A	200 A	2	19090... 54875...		2	400 A	PANEL B (VIA ATS)	2
3	--	--	--		17890... 45602...	--	--	--	4
5	PANEL P	200 A	2	13439... 5750 VA		2	60 A	CAR CHARGER	6
7	--	--	--		15000... 5750 VA	--	--	--	8
9	Space	--	1	--	--	1	--	Space	10
11	Space	--	1	--	--	1	--	Space	12
13	Space	--	1	--	--	1	--	Space	14
15	Space	--	1	--	--	1	--	Space	16
17	Space	--	1	--	--	1	--	Space	18
19	Space	--	1	--	--	1	--	Space	20
21	Space	--	1	--	--	1	--	Space	22
23	Space	--	1	--	--	1	--	Space	24
25	Space	--	1	--	--	1	--	Space	26
27	Space	--	1	--	--	1	--	Space	28
29	Space	--	1	--	--	1	--	Space	30
31	Space	--	1	--	--	1	--	Space	32
33	Space	--	1	--	--	1	--	Space	34
35	Space	--	1	--	--	1	--	Space	36
37	Space	--	1	--	--	1	--	Space	38
39	Space	--	1	--	0 VA	--	30 A	TVSS	40
41	Space	--	1	--	0 VA	2	--	--	42
Total Load:				93154 VA	84242 VA				
Total Amps:				776 A	702 A				

Legend:

Load Classification	Connected Load	Demand Factor	Estimated Demand	Panel Totals
Appliance - Dwelling Unit	24024 VA	75.00%	18018 VA	
HVAC	42480 VA	100.00%	42480 VA	Total Conn. Load: 177396 VA
Power	0 VA	0.00%	0 VA	Total Est. Demand: 116860 VA
Lighting	0 VA	0.00%	0 VA	Total Conn.: 739 A
Lighting - Dwelling Unit	86892 VA	37.24%	32362 VA	Total Est. Demand: 487 A
Large Appliance - Dwelling Unit	24000 VA	100.00%	24000 VA	

Notes:

Branch Panel: P

Location: POOL EQUIPMET ROOM
Supply From: PANEL DP
Mounting: Surface
Enclosure: NEMA-3R

Volts: 120/240 Single
Phases: 1
Wires: 3

A.I.C. Rating: 22,000A
Mains Type: MCB
Mains Rating: 200 A
MCB Rating: 200 A

Notes:

CKT	Circuit Description	Trip	Poles	A	B	Poles	Trip	Circuit Description	CKT
1	POOL HEATER	60 A	2	5000 VA 5000 VA		2	60 A	POOL PANEL	2
3	--	--	--		5000 VA 5000 VA	--	--	--	4
5	GUEST ROOM RCPT	15 A	1	0 VA 39 VA		1	15 A	GUEST FAMILY RCPT	6
7	GUEST FAMILY RCPT	20 A	1		0 VA 1500 VA	1	20 A	BBO RCPT(GFI) ⚠	8
9	GAS IGNT BBQ AREA GFI ⚠	20 A	1	900 VA 500 VA		1	20 A	EXTERIOR RCPT	10
11	ODU-1	20 A	2		1300 VA 700 VA	2	15 A	AHU-1	12
13	--	--	--	1300 VA 700 VA		--	--	--	14
15	WH-2	30 A	1		1500 VA 0 VA	1	20 A	GUEST BATHROOM/CABANA RCPT	16
17	Space	--	1	--	--	1	--	Space	18
19	Space	--	1	--	--	1	--	Space	20
21	Space	--	1	--	--	1	--	Space	22
23	Space	--	1	--	--	1	--	Space	24
25	Space	--	1	--	--	1	--	Space	26
27	Space	--	1	--	--	1	--	Space	28
29	Space	--	1	--	--	1	--	Space	30
31	Space	--	1	--	--	1	--	Space	32
33	Space	--	1	--	--	1	--	Space	34
35	Space	--	1	--	--	1	--	Space	36
37	Space	--	1	--	--	1	--	Space	38
39	Space	--	1	--	0 VA	2	30 A	TVSS	40
41	Space	--	1	--	0 VA	--	--	--	42
Total Load:				13439 VA	15000 VA				
Total Amps:				112 A	125 A				

Legend:

Load Classification	Connected Load	Demand Factor	Estimated Demand	Panel Totals
Appliance - Dwelling Unit	900 VA	100.00%	900 VA	
HVAC	4000 VA	100.00%	4000 VA	Total Conn. Load: 28439 VA
Lighting - Dwelling Unit	22039 VA	43.85%	9664 VA	Total Est. Demand: 16064 VA
Large Appliance - Dwelling Unit	1500 VA	100.00%	1500 VA	Total Conn.: 118 A
				Total Est. Demand: 67 A

Notes:



MIK ARCHITECTURE LLC
MATIAS DAROCH
AS-100480
1385 CORAL WAY, SUITE 202
MIAMI, FLORIDA 33146
+1 786 598 0880
mik@mikarch.com



 
AGD DEVELOPERS LLC
1385 CORAL WAY, SUITE 202
MIAMI, FLORIDA 33146
agdev@agdev.com



R&D ENGINEERS LLC
7795 NW 12TH ST, SUITE 202
CORAL, FLORIDA 33042
rd@rdengineers.com

NEW SINGLE FAMILY RESIDENCE
AGD CALISTONE LLC
10840 SW 67 Ave MIAMI, FL 33156

ISSUES
JUN 2024 1ST ISSUED
06.10.25 BLDG DEPT COMMENTS



R&D PROJECT NO: 2025.512

DRAWN BY: RV

CHECKED BY: RD

SCALE: AS NOTED

R&D ENGINEER: 37312

SEA:



Digitally signed
by RICARDO A DIAZ
Date: 2025.06.11
17:55:55 -04'00'

RICARDO A. DIAZ
PROFESSIONAL ENGINEER
PE 76981

THIS IS A DIGITALLY SIGNED WEBP. PRINTED COPIES OF THIS DOCUMENT ARE NOT CONSIDERED SIGNED AND SHOULD BE SIGNED AND NOT BE VERIFIED ON ANY ELECTRONIC COPIES.

THE CONTENT OF THIS SHEET AND ALL OTHER DRAWINGS ISSUED BY THE SET ARE PROTECTED BY U.S. AND INTERNATIONAL COPYRIGHT LAWS. REPRODUCTION OR USE WITHOUT PROPER WRITTEN CONSENT IS PROHIBITED BY LAW. SEE ADD FOR DETAILS.

SHEET NO:

E-7

Branch Panel: A											
Location: GARAGE				Volts: 120/240 Single				A.I.C. Rating: 22,000 A			
Supply From: PANEL DP				Phases: 1				Mains Type: MCB			
Mounting: Surface				Wires: 3				Mains Rating: 200 A			
Enclosure: NEMA-1								MCB Rating: N/A			
Notes:											
CKT	Circuit Description	Trip	Poles	A		B		Poles	Trip	Circuit Description	CKT
1	ELEV POWER	30 A	2	2250 VA	3550 VA			2	50 A	ODU-3	2
3	--	--	--			2250 VA	3550 VA	--	--	--	4
5	Space	--	1	--	700 VA			2	15 A	AHU-3	6
7	Space	--	1			--	700 VA	--	--	--	8
9	AHU-2	15 A	2	700 VA	700 VA			2	15 A	AHU-4	10
11	--	--	--			700 VA	700 VA	--	--	--	12
13	ODU-2	50 A	2	3550 VA	1200 VA			1	20 A	1ST FL WASHER	14
15	--	--	--			3550 VA	500 VA	1	20 A	GYM EQUIPMENT	16
17	ODU-4	40 A	2	2940 VA	0 VA			1	20 A	BBQ RCPT	18
19	--	--	--			2940 VA	2500 VA	2	30 A	1ST FL DRYER GFI	20
21					2500 VA			--	--	--	22
23	GYM EQUIPMENT	20 A	1			500 VA	--	1	--	Space	24
25	SAUNA	20 A	1	1000 VA	--			1	--	Space	26
27	Space	--	1			--	--	1	--	Space	28
29	Space	--	1	--	--			1	--	Space	30
31	Space	--	1			--	--	1	--	Space	32
33	Space	--	1	--	--			1	--	Space	34
35	Space	--	1			--	--	1	--	Space	36
37	Space	--	1	--	--			1	--	Space	38
39	Space	--	1			--	0 VA	2	30 A	TVSS	40
41	Space	--	1	--	0 VA			--	--	--	42
Total Load:				19090 VA		17890 VA					
Total Amps:				159 A		149 A					
Legend:											
Load Classification		Connected Load		Demand Factor		Estimated Demand		Panel Totals			
Appliance - Dwelling Unit		6700 VA		75.00%		5025 VA					
HVAC		24280 VA		100.00%		24280 VA		Total Conn. Load: 36980 VA			
Lighting - Dwelling Unit		0 VA		0.00%		0 VA		Total Est. Demand: 35305 VA			
Large Appliance - Dwelling Unit		6000 VA		100.00%		6000 VA		Total Conn.: 154 A			
								Total Est. Demand: 147 A			
Notes:											

Branch Panel: C											
Location: CLOSET				Volts: 120/240 Single				A.I.C. Rating: 22,000 A			
Supply From: B				Phases: 1				Mains Type: MCB			
Mounting: Surface				Wires: 3				Mains Rating: 200 A			
Enclosure: NEMA-1								MCB Rating: N/A			
Notes:											
CKT	Circuit Description	Trip	Poles	A		B		Poles	Trip	Circuit Description	CKT
1	AHU-5	15 A	2	700 VA	700 VA			2	15 A	AHU-7	2
3	--	--	--			700 VA	700 VA	--	--	--	4
5	2ND FL DRYER GFI	30 A	2	2500 VA	700 VA			2	15 A	AHU-6	6
7	--	--	--			2500 VA	700 VA	--	--	--	8
9	MASTER BATHROOM RCPT	20 A	1	0 VA	500 VA			1	20 A	BALCONY RCPT	10
11	BEDROOM 03 RCPT	15 A	1			7207 VA	1200 VA	1	20 A	2ND FL WASHER	12
13	BEDROOM 02 RCPT	15 A	1	0 VA	0 VA			1	15 A	MASTER ENTRY RCPT	14
15	BEDROOM 01 RCPT	15 A	1			0 VA	0 VA	1	15 A	MASTER BEDROOM & BALCONY RCPT	16
17	MASTER BATHROOM RCPT	20 A	1	0 VA	0 VA			1	20 A	CLOSET/AHU RCPT	18
19	ELEVATOR LTS & RCPT	20 A	1			292 VA	0 VA	1	20 A	BATHROOM 02 & 03 RCPT	20
21	BEDROOM 04 RCPT	15 A	1	7207 VA	1500 VA			1	20 A	2ND LAUNDRY REC	22
23	BATHROOM AND WIC FANS	20 A	1			0 VA	0 VA	1	15 A	CORRIDOR RCPT	24
25	Space	--	1	--	--			1	--	Space	26
27	Space	--	1			--	--	1	--	Space	28
29	Space	--	1	--	--			1	--	Space	30
31	Space	--	1			--	--	1	--	Space	32
33	Space	--	1	--	--			1	--	Space	34
35	Space	--	1			--	--	1	--	Space	36
37	Space	--	1	--	--			1	--	Space	38
39	Space	--	1			--	0 VA	2	30 A	TVSS	40
41	Space	--	1	--	0 VA			--	--	--	42
Total Load:				13807 VA		13299 VA					
Total Amps:				115 A		111 A					
Legend:											
Load Classification		Connected Load		Demand Factor		Estimated Demand		Panel Totals			
Appliance - Dwelling Unit		1200 VA		100.00%		1200 VA					
HVAC		4200 VA		100.00%		4200 VA		Total Conn. Load: 27106 VA			
Lighting		0 VA		0.00%		0 VA		Total Est. Demand: 18197 VA			
Lighting - Dwelling Unit		16706 VA		46.67%		7797 VA		Total Conn.: 113 A			
Large Appliance - Dwelling Unit		5000 VA		100.00%		5000 VA		Total Est. Demand: 76 A			
Notes:											

Branch Panel: B											
Location: GARAGE				Volts: 120/240 Single				A.I.C. Rating: 22,000 A			
Supply From: PANEL DP				Phases: 1				Mains Type: MCB			
Mounting: Surface				Wires: 3				Mains Rating: 400 A			
Enclosure: NEMA-1								MCB Rating: N/A			
Notes:											
CKT	Circuit Description	Trip	Poles	A		B	Poles	Trip	Circuit Description	CKT	
1	PANEL C	150 A	2	13807...	1300 VA		2	20 A	ODU-6	2	
3	--	--	--			13299...	1300 VA	--	--	4	
5	ODU-5	40 A	2	1850 VA	1850 VA		2	50 A	ODU-7	6	
7	--	--	--			1850 VA	1850 VA	--	--	8	
9	PANEL LC1	40 A	2	1916 VA	1655 VA		2	40 A	PANEL LC2	10	
11	--	--	--			1916 VA	1655 VA	--	--	12	
13	WHE	30 A	2	2750 VA	785 VA		2	40 A	PANEL LC3	14	
15	--	--	--			2750 VA	785 VA	--	--	16	
17	SMALL APPLIANCE	20 A	1	1500 VA	--		1	--	Space	18	
19	SMALL APPLIANCE	20 A	1			1500 VA	--	1	Space	20	
21	SMALL APPLIANCE	20 A	1	1500 VA	--		1	--	Space	22	
23	SMALL APPLIANCE	20 A	1			1500 VA	1000 VA	1	20 A	GARAGE DOOR OPENER	24
25	PANTRY SMALL APPLIANCE	20 A	1	1500 VA	1000 VA		1	20 A	GARAGE DOOR OPENER	26	
27	DINNING RM SMALL APPLIANCE	20 A	1			1500 VA	0 VA	1	20 A	WINE DISPLAY	28
29	LAUNDRY RM RCPT	20 A	1	1500 VA	900 VA		1	20 A	RANGE HOOD	30	
31	GARAGE RCPT	20 A	1			0 VA	500 VA	1	20 A	GAS CONTROL	32
33	FLEX & POWDER ROOM GFI	20 A	1	0 VA	1400 VA		1	20 A	DISHWASHER	34	
35	LOBBY / CORRIDOR RCPT	15 A	1			0 VA	1400 VA	1	20 A	DISHWASHER	36
37	STUDIO RCPT	15 A	1	0 VA	1200 VA		1	20 A	REF	38	
39	FAMILY RM RCPT	15 A	1			0 VA	1200 VA	1	20 A	FRZ	40
41	GYM MASSAGE RCPT	15 A	1	7281 VA	500 VA		1	20 A	EXTERIOR EXTRANCE RCPT	42	
43	FLEX ROOM & WC RCPT	15 A	1			7281 VA	--	1	Space	44	
45	GUEST ROOM & WC RCPT	15 A	1	0 VA	800 VA		1	20 A	PANEL LV-2	46	
47	CORRIDOR RCPT	15 A	1			0 VA	292 VA	1	20 A	ELEV LTG/RCPT	48
49	GREAT ROOM RCPT	15 A	1	7281 VA	0 VA		1	20 A	PANEL LC-2	50	
51	GREAT ROOM COUNTER RCPT	20 A	1			3000 VA	224 VA	1	20 A	EF-4	52
53	EXTERIOR RCPT	20 A	1	600 VA	100 VA		1	20 A	ELEV SUMP PUMP	54	
55	PANEL LV-1	20 A	1			800 VA	0 VA	1	20 A	GUEST WC & GYM BATHROOM RCPT	56
57	ELEV LTG CONTRLS	20 A	1	900 VA	900 VA		1	20 A	GARBAGE DISPOSAL	58	
59	--	--	--					1	Space	60	
61	RP-1	20 A	1	100 VA	--		1	--	Space	62	
63	Space	--	1			--	--	1	Space	64	
65	Space	--	1	--	--		1	--	Space	66	
67	Space	--	1			--	--	1	Space	68	
69	Space	--	1	--	--		1	--	Space	70	
71	Space	--	1			--	--	1	Space	72	
73	Space	--	1	--	--		1	--	Space	74	
75	Space	--	1			--	--	1	Space	76	
77	Space	--	1	--	--		1	--	Space	78	
79	Space	--	1			--	--	1	Space	80	
81	Space	--	1	--	--		1	--	Space	82	
83	Space	--	1			--	--	1	Space	84	
Total Load:				54875 VA		45602 VA					
Total Amps:				457 A		380 A					
Legend:											
Load Classification		Connected Load		Demand Factor		Estimated Demand		Panel Totals			
Appliance - Dwelling Unit		16424 VA		75.00%		12318 VA					
HVAC		14200 VA		100.00%		14200 VA		Total Conn. Load: 100477 VA			
Power		0 VA		0.00%		0 VA		Total Est. Demand: 56167 VA			
Lighting		0 VA		0.00%		0 VA		Total Conn.: 419 A			
Lighting - Dwelling Unit		64853 VA		38.01%		24649 VA		Total Est. Demand: 234 A			
Large Appliance - Dwelling Unit		5000 VA		100.00%		5000 VA					
Notes:											

SDA - 10840 SW 67							LC PANEL 1		
MODULE 1 (LOSE-445-120-D) Universal								Drivers	
Circuit module	Zone	Load / Fixture Type	# Fixures	Load Name	Load #	Wattage	No. Wiring	Driver reference	Lighting Control System
1	ENTRY	L1	72	103.00	111	360	Confirm Note 2 for No. Wiring	(4) TBD (100W)	PHASE
	FOYER	L1	26	102.00	112	150	Confirm Note 2 for No. Wiring	(3) TBD (100W)	PHASE
	1st FLOOR CORRIDOR	T1	4	103.00	113	200	Confirm Note 3 for No. Wiring	REMOTE CPU (S2CPU-BC)	PHASE
	1st FLOOR CORRIDOR	R1	17	103.01	114	238	Confirm Note 1 for No. Wiring	N/A	PHASE
Total Watts Circuit 1						928			
MODULE 2 (LOSE-445-120-D) Universal								Drivers	
Circuit module	Zone	Load / Fixture Type	# Fixures	Load Name	Load #	Wattage	No. Wiring	Driver reference	Lighting Control System
2	POWDER	R1	1	104.00	121	14	Confirm Note 1 for No. Wiring	N/A	PHASE
	POWDER	J2	1	104.01	122	100	Confirm Note 1 for No. Wiring	N/A	ON/OFF
	POWDER	L1	7	104.02	123	35	Confirm Note 2 for No. Wiring	TBD (100W)	PHASE
	GARAGE	S2	8	105.00	124	160	Confirm Note 1 for No. Wiring	N/A	ELV
Total Watts Circuit 2						309			
MODULE 3 (LOSE-445-120-D) Universal								Drivers	
Circuit module	Zone	Load / Fixture Type	# Fixures	Load Name	Load #	Wattage	No. Wiring	Driver reference	Lighting Control System
3	GARAGE	R1	1	105.01	131	14	Confirm Note 1 for No. Wiring	N/A	PHASE
	KITCHEN	J1	2	106.00	132	200	Confirm Note 1 for No. Wiring	N/A	ON/OFF
	KITCHEN	R1	3	106.01	133	42	Confirm Note 1 for No. Wiring	N/A	PHASE
	KITCHEN	R1	3	106.02	134	42	Confirm Note 1 for No. Wiring	N/A	PHASE
Total Watts Circuit 3						298			
MODULE 4 (LOSE-445-120-D) Universal								Drivers	
Circuit module	Zone	Load / Fixture Type	# Fixures	Load Name	Load #	Wattage	No. Wiring	Driver reference	Lighting Control System
4	KITCHEN	R2	5	106.03	141	150	Confirm Note 1 for No. Wiring	N/A	TBAC
	FAMILY ROOM	J1	1	107.00	142	100	Confirm Note 1 for No. Wiring	N/A	ON/OFF
	FAMILY ROOM	L1	52	107.01	143	260	Confirm Note 1 for No. Wiring	(3) TBD (100W)	PHASE
	FAMILY ROOM	R1	3	107.02	144	42	Confirm Note 1 for No. Wiring	N/A	PHASE
Total Watts Circuit 4						552			
MODULE 5 (LOSE-445-120-D) Universal								Drivers	
Circuit module	Zone	Load / Fixture Type	# Fixures	Load Name	Load #	Wattage	No. Wiring	Driver reference	Lighting Control System
5	FAMILY ROOM	R1	6	107.03	151	84	Confirm Note 1 for No. Wiring	N/A	PHASE
	HOUSE EQUIPMENT	S8	2	108.00	152	18	Confirm Note 1 for No. Wiring	N/A	ON/OFF
	BBQ	R4	6	109.00	153	12	Confirm Note 1 for No. Wiring	N/A	PHOTOCELL
	BBQ	R1	12	109.01	154	168	Confirm Note 1 for No. Wiring	N/A	PHASE
Total Watts Circuit 5						282			
MODULE 6 (LOSE-445-120-D) Universal								Drivers	
Circuit module	Zone	Load / Fixture Type	# Fixures	Load Name	Load #	Wattage	No. Wiring	Driver reference	Lighting Control System
6	BBQ	S4	8	109.02	161	192	Confirm Note 1 for No. Wiring	N/A	PHASE
	BBQ	S5	4	109.03	162	80	Confirm Note 1 for No. Wiring	N/A	ELV
	BBQ	S1	9	109.04	163	144	Confirm Note 1 for No. Wiring	N/A	ELV
	GUEST HOUSE	R1	1	110.00	164	14	Confirm Note 1 for No. Wiring	N/A	PHASE
Total Watts Circuit 6						430			
MODULE 7 (LOSE-445-120-D) Universal								Drivers	
Circuit module	Zone	Load / Fixture Type	# Fixures	Load Name	Load #	Wattage	No. Wiring	Driver reference	Lighting Control System
7	GUEST HOUSE	R1	6	110.01	171	84	Confirm Note 1 for No. Wiring	N/A	PHASE
	GUEST HOUSE	J1	1	110.02	172	100	Confirm Note 1 for No. Wiring	N/A	ON/OFF
	POOL EQUIPMENT	S8	2	111.00	173	18	Confirm Note 1 for No. Wiring	N/A	ON/OFF
	GREAT ROOM	T2	2	112.00	174	100	Confirm Note 3 for No. Wiring	REMOTE CPU (S2CPU-BC)	PHASE
Total Watts Circuit 7						302			
MODULE 8 (LOSE-445-120-D) Universal								Drivers	
Circuit module	Zone	Load / Fixture Type	# Fixures	Load Name	Load #	Wattage	No. Wiring	Driver reference	Lighting Control System
8	GREAT ROOM	J1	1	112.01	181	100	Confirm Note 1 for No. Wiring	N/A	ON/OFF
	GREAT ROOM	T4	2	112.02	182	100	Confirm Note 3 for No. Wiring	REMOTE CPU (S2CPU-BC)	PHASE
	GREAT ROOM	L1	53	112.03	183	265	Confirm Note 2 for No. Wiring	(3) TBD (100W)	PHASE
	GREAT ROOM	L1	53	112.04	184	265	Confirm Note 2 for No. Wiring	(3) TBD (100W)	PHASE
Total Watts Circuit 8						730			

3831 W @ 240V = 15.97A

SDA - 10840 SW 67							LC PANEL 2		
MODULE 1-2 (LOSE-445-120-D) Universal								Drivers	
Circuit module	Zone	Load / Fixture Type	# Fixures	Load Name	Load #	Wattage	No. Wiring	Driver reference	Lighting Control System
9	GREAT ROOM	J1	1	112.05	211	100	Confirm Note 1 for No. Wiring	N/A	ON/OFF
	BAR	R1	8	113.00	212	112	Confirm Note 1 for No. Wiring	N/A	PHASE
	BAR	J1	1	113.01	213	100	Confirm Note 1 for No. Wiring	N/A	ON/OFF
	BAR	J1	1	113.02	214	100	Confirm Note 1 for No. Wiring	N/A	ON/OFF
Total Watts Circuit 9						452			
MODULE 2-3 (LOSE-445-120-D) Universal								Drivers	
Circuit module	Zone	Load / Fixture Type	# Fixures	Load Name	Load #	Wattage	No. Wiring	Driver reference	Lighting Control System
10	GYM	R1	9	114.00	221	126	Confirm Note 1 for No. Wiring	N/A	PHASE
	MESSAGE ROOM	R1	6	115.00	222	84	Confirm Note 1 for No. Wiring	N/A	PHASE
	STUDIO	R1	6	116.00	223	84	Confirm Note 1 for No. Wiring	N/A	PHASE
	1st FLOOR CORRIDOR	R3	7	105.02	224	98	Confirm Note 1 for No. Wiring	N/A	PHASE
Total Watts Circuit 10						392			
MODULE 3-2 (LOSE-445-120-D) Universal								Drivers	
Circuit module	Zone	Load / Fixture Type	# Fixures	Load Name	Load #	Wattage	No. Wiring	Driver reference	Lighting Control System
11	BACKYARD	R1	9	117.00	231	126	Confirm Note 1 for No. Wiring	N/A	PHASE
	BACKYARD	S4	6	117.01	232	144	Confirm Note 1 for No. Wiring	N/A	ON/OFF
	FOYER	J1	1	102.01	233	100	Confirm Note 1 for No. Wiring	N/A	ON/OFF
	FOYER	R1	8	102.02	234	112	Confirm Note 1 for No. Wiring	N/A	PHASE
Total Watts Circuit 11						482			
MODULE 4-2 (LOSE-445-120-D) Universal								Drivers	
Circuit module	Zone	Load / Fixture Type	# Fixures	Load Name	Load #	Wattage	No. Wiring	Driver reference	Lighting Control System
12	2nd FLOOR CORRIDOR	T1	2	118.00	241	100	Confirm Note 3 for No. Wiring	REMOTE CPU (S2CPU-BC)	PHASE
	2nd FLOOR CORRIDOR	R1	7	118.01	242	98	Confirm Note 1 for No. Wiring	N/A	PHASE
	2nd FLOOR CORRIDOR	R1	7	118.02	243	98	Confirm Note 1 for No. Wiring	N/A	PHASE
	2nd FLOOR STAIRS	L2	76	119.00	244	228	Confirm Note 2 for No. Wiring	(3) TBD (100W)	PHASE
Total Watts Circuit 12						534			
MODULE 5-2 (LOSE-445-120-D) Universal								Drivers	
Circuit module	Zone	Load / Fixture Type	# Fixures	Load Name	Load #	Wattage	No. Wiring	Driver reference	Lighting Control System
13	BEDROOM 01	R1	2	120.00	251	28	Confirm Note 1 for No. Wiring	N/A	PHASE
	BEDROOM 01	R1	7	120.01	252	98	Confirm Note 1 for No. Wiring	N/A	PHASE
	BEDROOM 02	R1	2	121.00	253	28	Confirm Note 1 for No. Wiring	N/A	PHASE
	BEDROOM 02	R1	6	121.01	254	84	Confirm Note 1 for No. Wiring	N/A	PHASE
Total Watts Circuit 13						238			
MODULE 6-2 (LOSE-445-120-D) Universal								Drivers	
Circuit module	Zone	Load / Fixture Type	# Fixures	Load Name	Load #	Wattage	No. Wiring	Driver reference	Lighting Control System
14	BEDROOM 03	R1	2	122.00	261	28	Confirm Note 1 for No. Wiring	N/A	PHASE
	BEDROOM 03	R1	6	122.01	262	84	Confirm Note 1 for No. Wiring	N/A	PHASE
	BEDROOM 04	R1	2	123.00	263	28	Confirm Note 1 for No. Wiring	N/A	PHASE
	BEDROOM 04	R1	6	123.01	264	84	Confirm Note 1 for No. Wiring	N/A	PHASE
Total Watts Circuit 14						224			
MODULE 7-2 (LOSE-445-120-D) Universal								Drivers	
Circuit module	Zone	Load / Fixture Type	# Fixures	Load Name	Load #	Wattage	No. Wiring	Driver reference	Lighting Control System
15	MASTER WIC	J1	2	124.00	271	200	Confirm Note 1 for No. Wiring	N/A	ON/OFF
	MASTER WIC	J1	3	124.01	272	300	Confirm Note 1 for No. Wiring	N/A	ON/OFF
	MASTER WIC	L1	48	124.02	273	240	Confirm Note 2 for No. Wiring	(3) TBD (100W)	PHASE
	MASTER WIC	R1	4	124.03	274	56	Confirm Note 1 for No. Wiring	N/A	PHASE
Total Watts Circuit 15						796			
MODULE 8-2 (LOSE-445-120-D) Universal								Drivers	
Circuit module	Zone	Load / Fixture Type	# Fixures	Load Name	Load #	Wattage	No. Wiring	Driver reference	Lighting Control System
16	MASTER BATHROOM	R1	7	125.00	281	98	Confirm Note 1 for No. Wiring	N/A	PHASE
	MASTER BATHROOM	L1	22	125.01	282	110	Confirm Note 2 for No. Wiring	(2) TBD (100W)	PHASE
	MASTER BATHROOM	L1	4	125.02	283	20	Confirm Note 2 for No. Wiring	TBD (100W)	PHASE
	MASTER BATHROOM	R1	1	125.03	284	14	Confirm Note 1 for No. Wiring	N/A	PHASE
Total Watts Circuit 16						242			

3310 W @ 240V = 13.79A

SDA - 10840 SW 67							LC PANEL 3		
MODULE 1-3 (LOSE-445-120-D) Universal								Drivers	
Circuit module	Zone	Load / Fixture Type	# Fixures	Load Name	Load #	Wattage	No. Wiring	Driver reference	Lighting Control System
17	MASTER BATHROOM	R1	1	125.04	311	14	Confirm Note 1 for No. Wiring	N/A	PHASE
	MASTER BATHROOM	L1	7	125.05	312	35	Confirm Note 2 for No. Wiring	TBD (100W)	PHASE
	MASTER BATHROOM	J1	1	125.06	313	100	Confirm Note 1 for No. Wiring	N/A	ON/OFF
	MASTER BATHROOM	R1	4	125.07	314	56	Confirm Note 1 for No. Wiring	N/A	PHASE
Total Watts Circuit 17						205			
MODULE 2-3 (LOSE-445-120-D) Universal								Drivers	
Circuit module	Zone	Load / Fixture Type	# Fixures	Load Name	Load #	Wattage	No. Wiring	Driver reference	Lighting Control System
18	MASTER BATHROOM	J2	4	125.08	321	400	Confirm Note 1 for No. Wiring	N/A	ON/OFF
	MASTER ENTRY	R1	8	126.00	322	112	Confirm Note 1 for No. Wiring	N/A	PHASE
	MASTER ENTRY	J1	2	126.01	323	200	Confirm Note 1 for No. Wiring	N/A	ON/OFF
	MASTER BEDROOM	L1	45	127.00	324	225	Confirm Note 2 for No. Wiring	(3) TBD (100W)	PHASE
Total Watts Circuit 18						937			