

DRAWN DATE: 10/01/2025
ORDER: N/A
JOB NO. : HUBE-25-133
SALESMAN: KVK
DRAWN BY: ML

HUBER RESIDENCE
SUBD.: SUNILAND ESTATES
LOT 2 BLK 2
ADDRESS: 12020 SW 77th AVENUE
CITY: PINECREST, FL. 33156

 
 
 
DATE	REVISIONS / CORRECTIONS
10/24/2025	ADD ELECTRIC HEAT PUMP.
12/17/2025	ZONING COMMENTS.



3144 SW 13th DRIVE
DEERFIELD BEACH, FL. 33442
(954) 755-4402


This item has been digitally signed and sealed by Zakary James Lata (P.E. # 79443) on the date indicated here. Printed copies are not considered signed and sealed, and the signature must be verified on any electronic copies.

If signed digitally above, printed copies of this document are not considered signed and sealed and the signature must be verified on any electronic copies.


LEGEND	
	MAIN DRAIN
	WALL RETURN
	LIGHT
	FLOOR RETURN
	SPA JET
	SKIMMER
	CLEANING LINE W/ VAC LOCK
	UMBRELLA SLEEVE
	MANUAL AUTO FILL (VERIFY EXACT LOCATION IN FIELD) FRESH WATER CONNECTION BY V/K

PIPING LEGEND	
1	(7) 1" PVC POOL LIGHTS
2	(1) 1" PVC SPA LIGHT
3	(2) 1" PVC LIGHT FROM JUNCTION BOXES
4	(1) 3" POOL MAIN DRAIN LINE
5	(1) 2" CLEANING LINE
6	(2) 2" SKIMMER LINES
7	(2) 2" AIR BLOWER LINES
8	(2) 3" SPA JET LINES
9	(1) 3" SPA MAIN DRAIN LINE
10	(1) 3" TRUNK POOL RETURN LINE
11	(1) 2.5" SPA FLOOR RETURN LINE


DECK BY OTHERS
UNDER SEPARATE PERMIT
(NOT SHOWN)

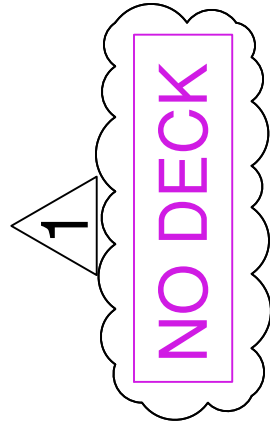

POOL PLAN
SCALE: 1/4"=1'

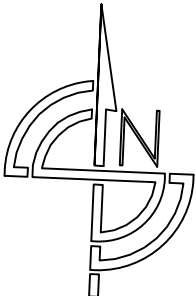

POOL SPECIFICATIONS	
SIZE	20' X 65'
DEPTH	4' TO 7'
PERIMETER	170 LF
SURFACE AREA	800 SF
GALLONS	28,985
TURNOVER RATE	6 HRS
POOL PUMP	JANDY VS FLOPRO 2.7HP VAR SPD.
CARTRIDGE FILTER	JANDY CS200 SF
LIGHT	(7) LED NICHELESS
SKIMMER	2
WALL RETURN	5
ELECTRIC HEATER	JANDY JRT3000R
GEM FINISH	YES
CLEANING LINE	YES
SALT SYSTEM	JANDY AQUAPURE PLC1400
SWIM OUT	YES-WITH CAP TILE-YES
STEPS & SUN-SHELF	YES-WITH CAP TILE-YES
UMBRELLA SLEEVE	2
MANUAL AUTO FILL	YES
ENCLOSURE	SEE SITE PLAN SHEET 1 (WINDOW/DOOR ALARM BY OTHERS)
SPA SPECIFICATIONS	
SIZE	9'-3" X 9'-3" FLUSH
DEPTH	3'
PERIMETER	37 LF
SURFACE AREA	86 SF
GALLONS	1,930
SPA PUMP	JANDY VS FLOPRO 2.7HP VAR SPD.
LIGHT	(1) LED NICHELESS
FLOOR RETURN	2
AUTOMATION	JANDY RS PS4 I AQUALINK
THERAPY JET	8
AIR BLOWER	2 HP
SPILLWAY	17LF REVERSE WET EDGE
GAS HEATER	JANDY JX4400P 399K BTU

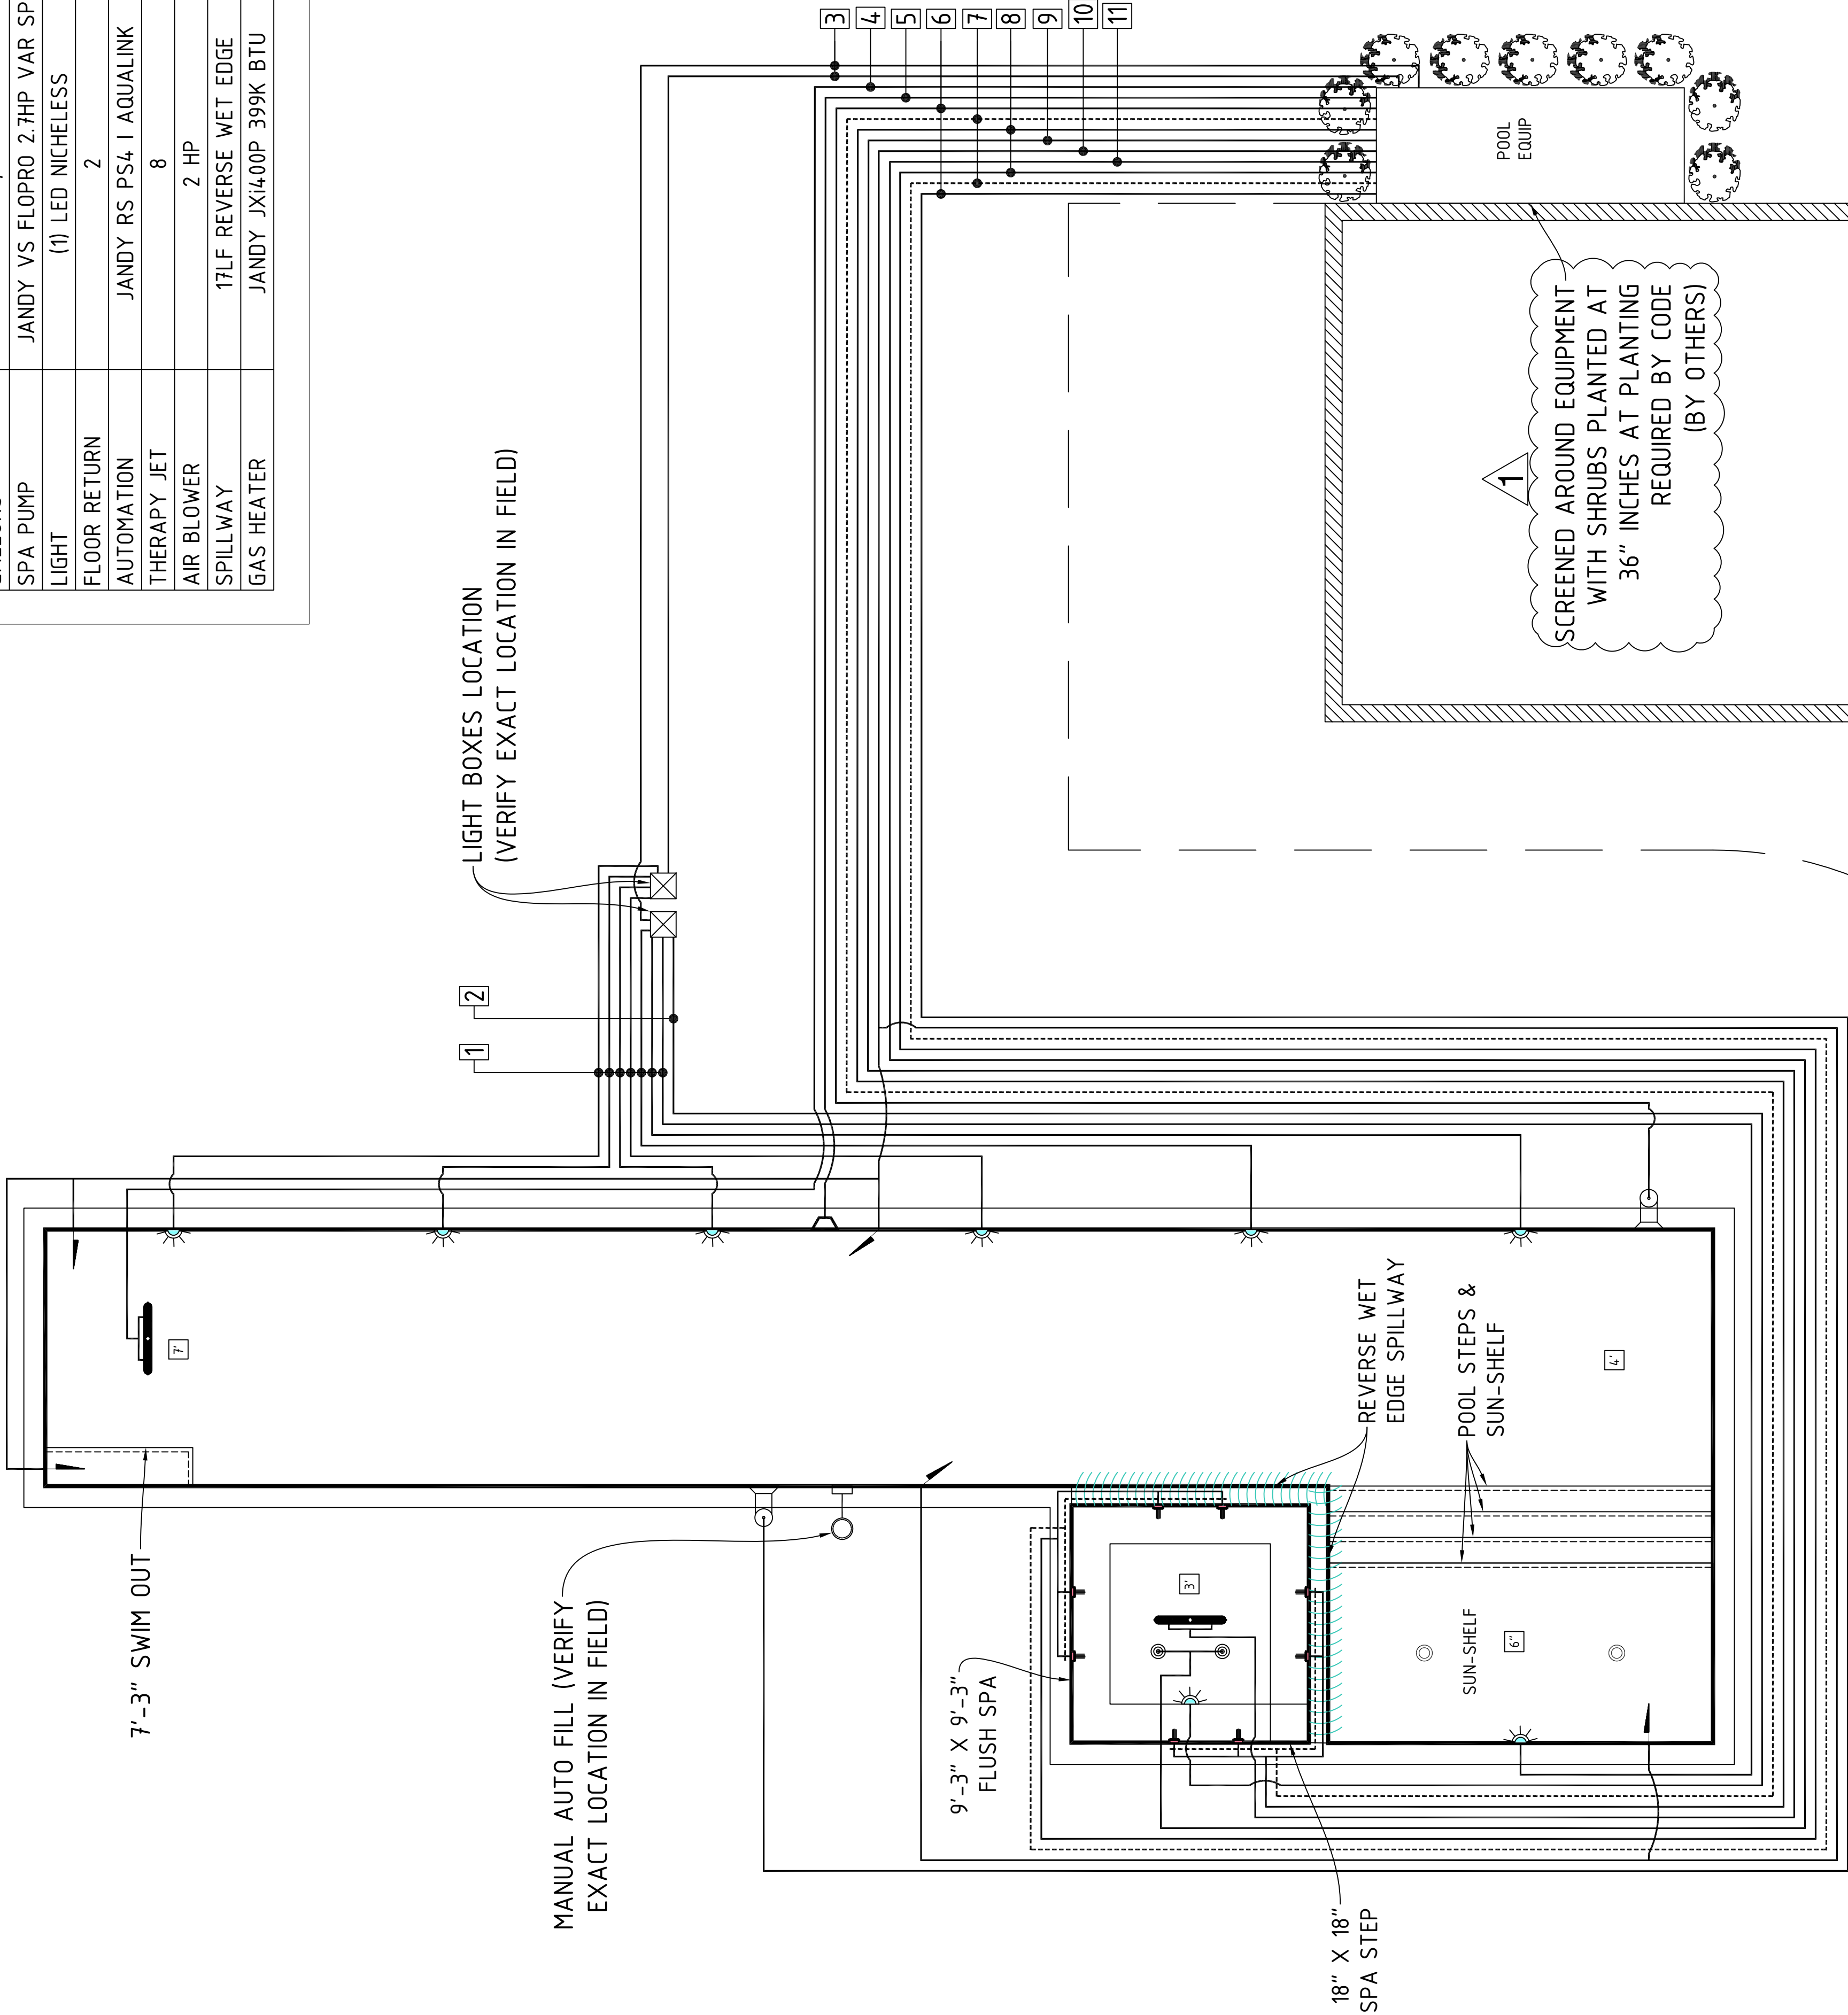

1
SCREENED AROUND EQUIPMENT
WITH SHRUBS PLANTED AT
36" INCHES AT PLANTING
REQUIRED BY CODE
(BY OTHERS)