


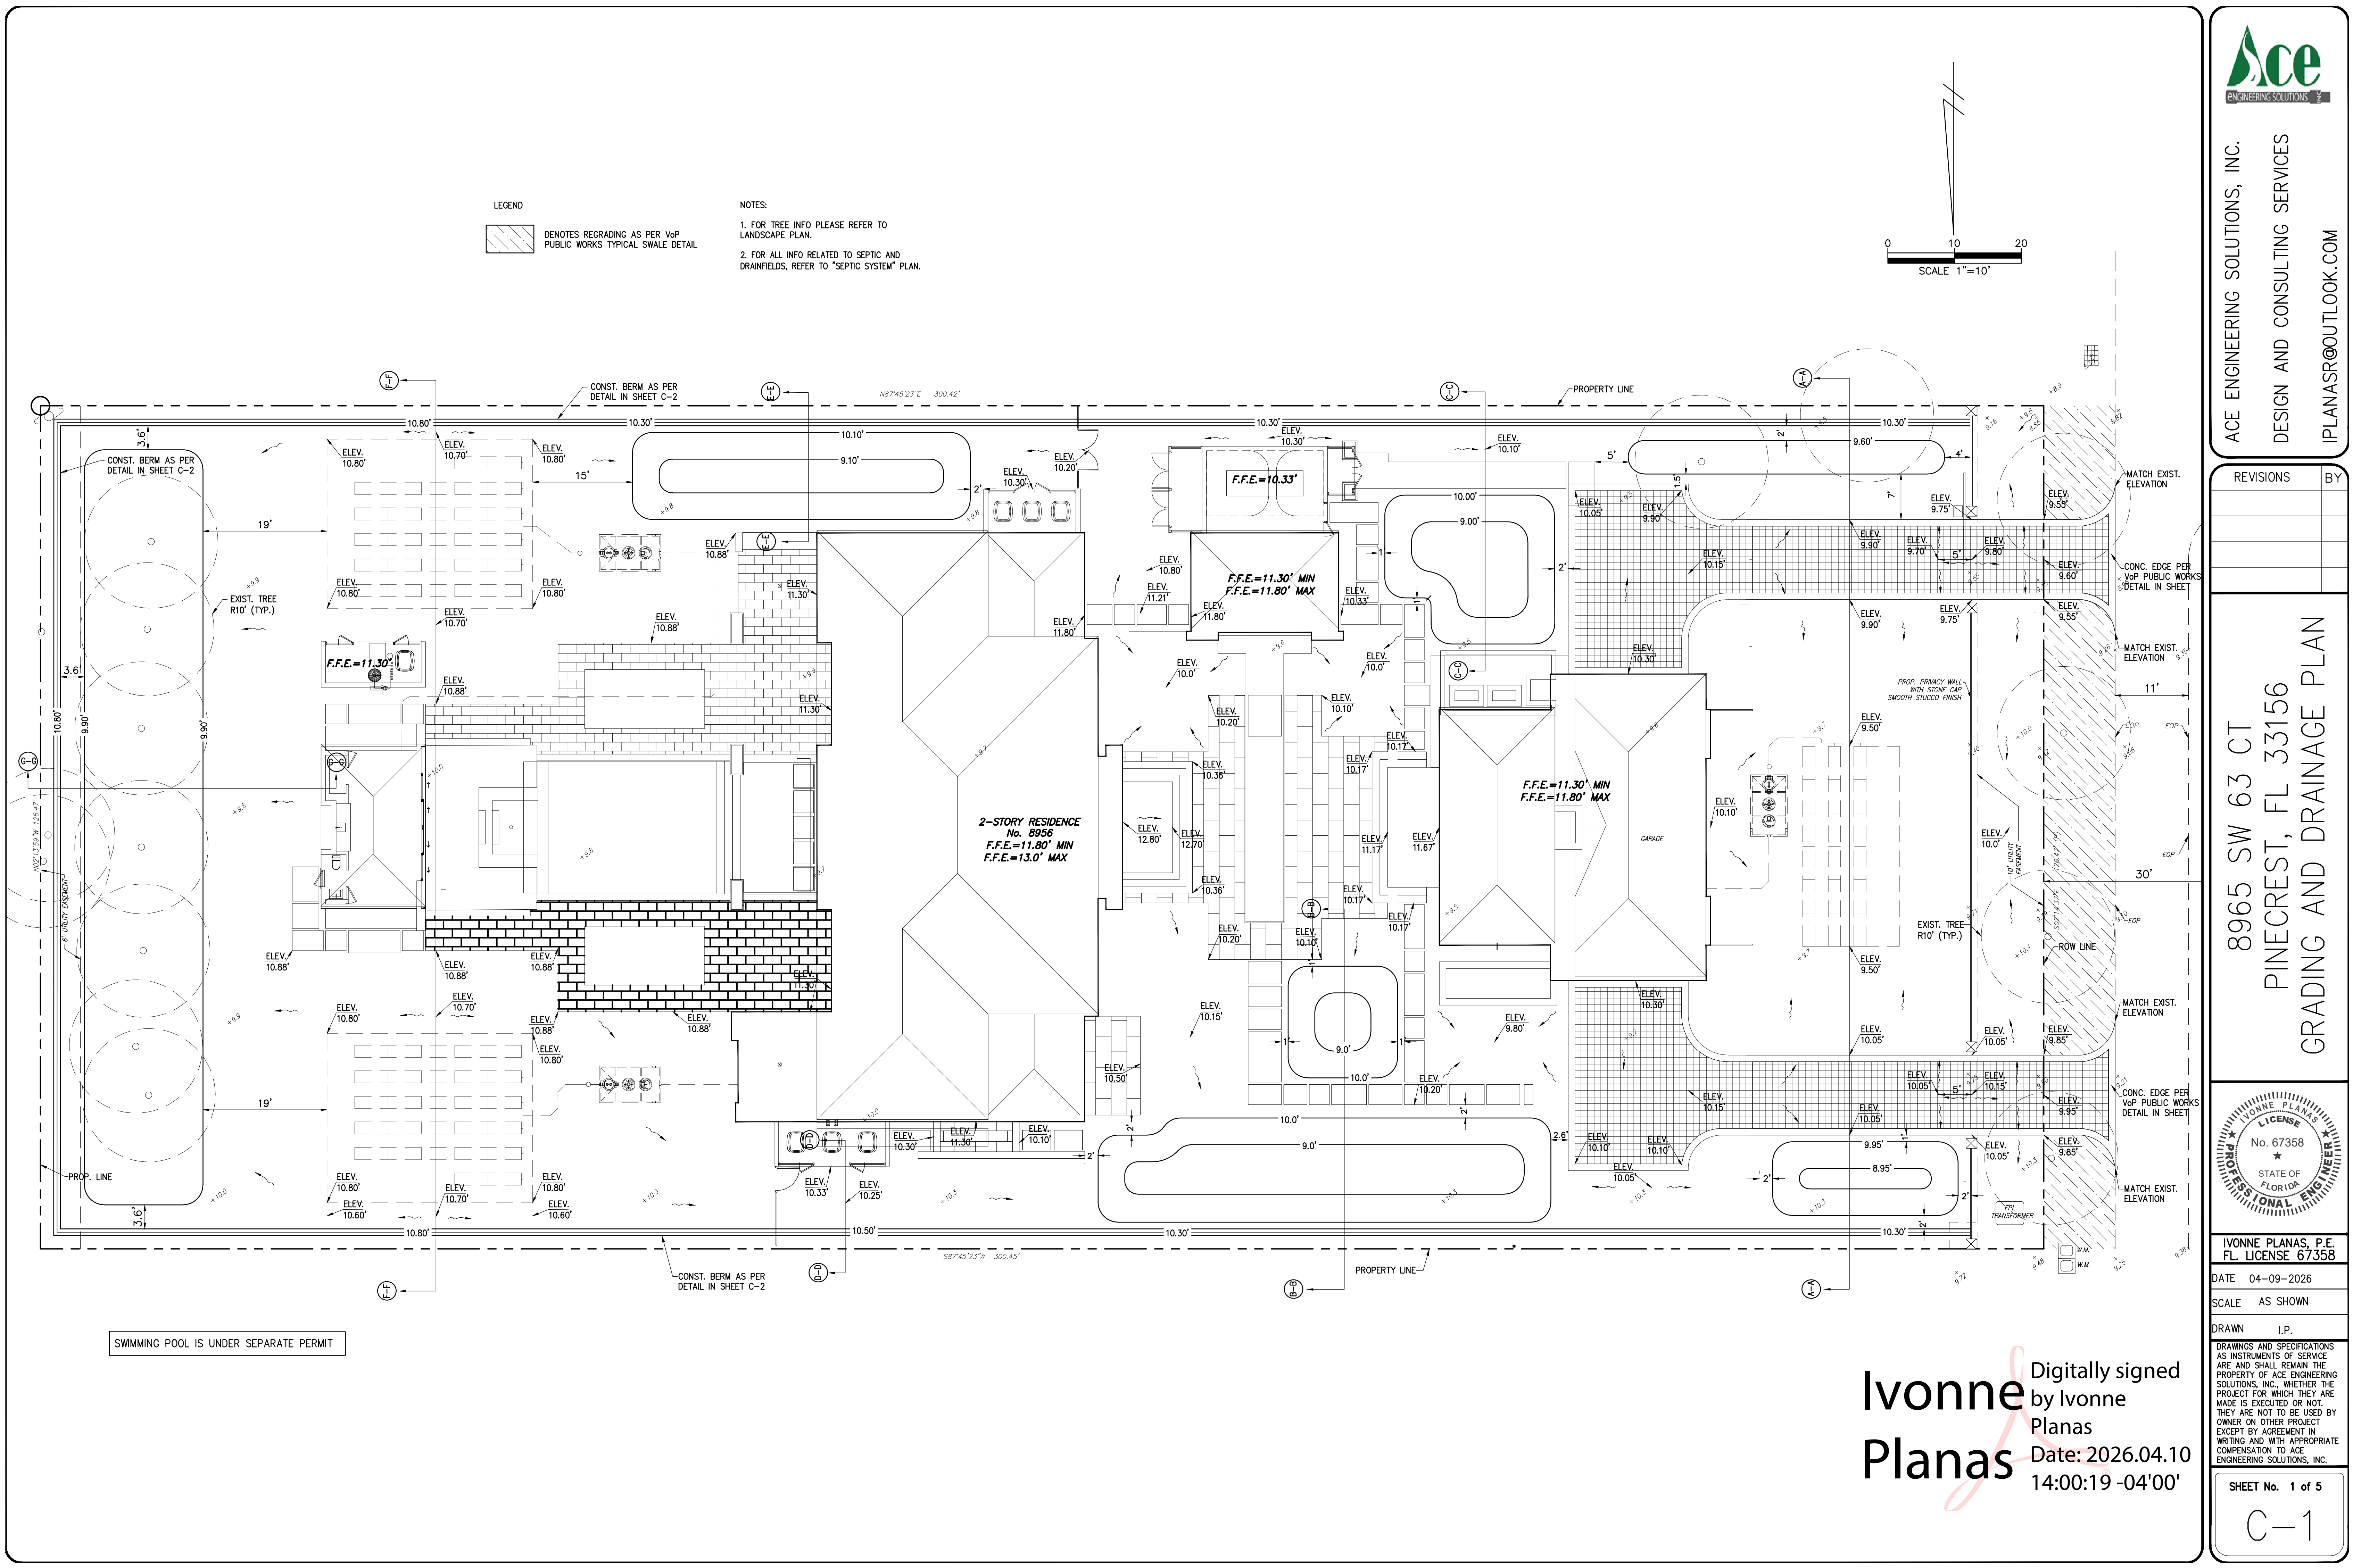




ACE ENGINEERING SOLUTIONS, INC.
DESIGN AND CONSULTING SERVICES
IPLANASR@OUTLOOK.COM

REVISIONS	BY

8965 SW 63 CT
PINECREST, FL 33156
GRADING AND DRAINAGE PLAN

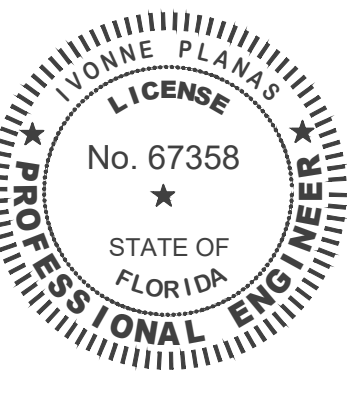

IVONNE PLANAS, P.E.
FL. LICENSE 67358

DATE	04-09-2026
SCALE	AS SHOWN
DRAWN	I.P.
DRAWINGS AND SPECIFICATIONS AS INSTRUMENTS OF SERVICE ARE AND SHALL REMAIN THE PROPERTY OF ACE ENGINEERING SOLUTIONS, INC. WHETHER THE PROJECT FOR WHICH THEY ARE MADE IS EXECUTED OR NOT. THEY ARE NOT TO BE USED BY OWNER ON OTHER PROJECT EXCEPT BY AGREEMENT IN WRITING AND WITH APPROPRIATE COMPENSATION TO ACE ENGINEERING SOLUTIONS, INC.	
SHEET No. 1 of 5	

C-1

Digitally signed by Ivonne Planas
Date: 2026.04.10 14:00:19 -04'00'