


THE ARCHITECT HEREBY EXPRESSLY RESERVES THE COPYRIGHT AND PROPERTY RIGHTS IN THESE PLANS. DRAWINGS ARE NOT TO BE REPRODUCED, CHANGED, OR COPIED IN ANY FORM OR MANNER WHATSOEVER WITHOUT FIRST OBTAINING WRITTEN PERMISSION AND CONSENT. NOR ARE THEY TO BE ASSIGNED TO ANY PARTY WITHOUT FIRST OBTAINING SAID WRITTEN PERMISSION AND CONSENT.

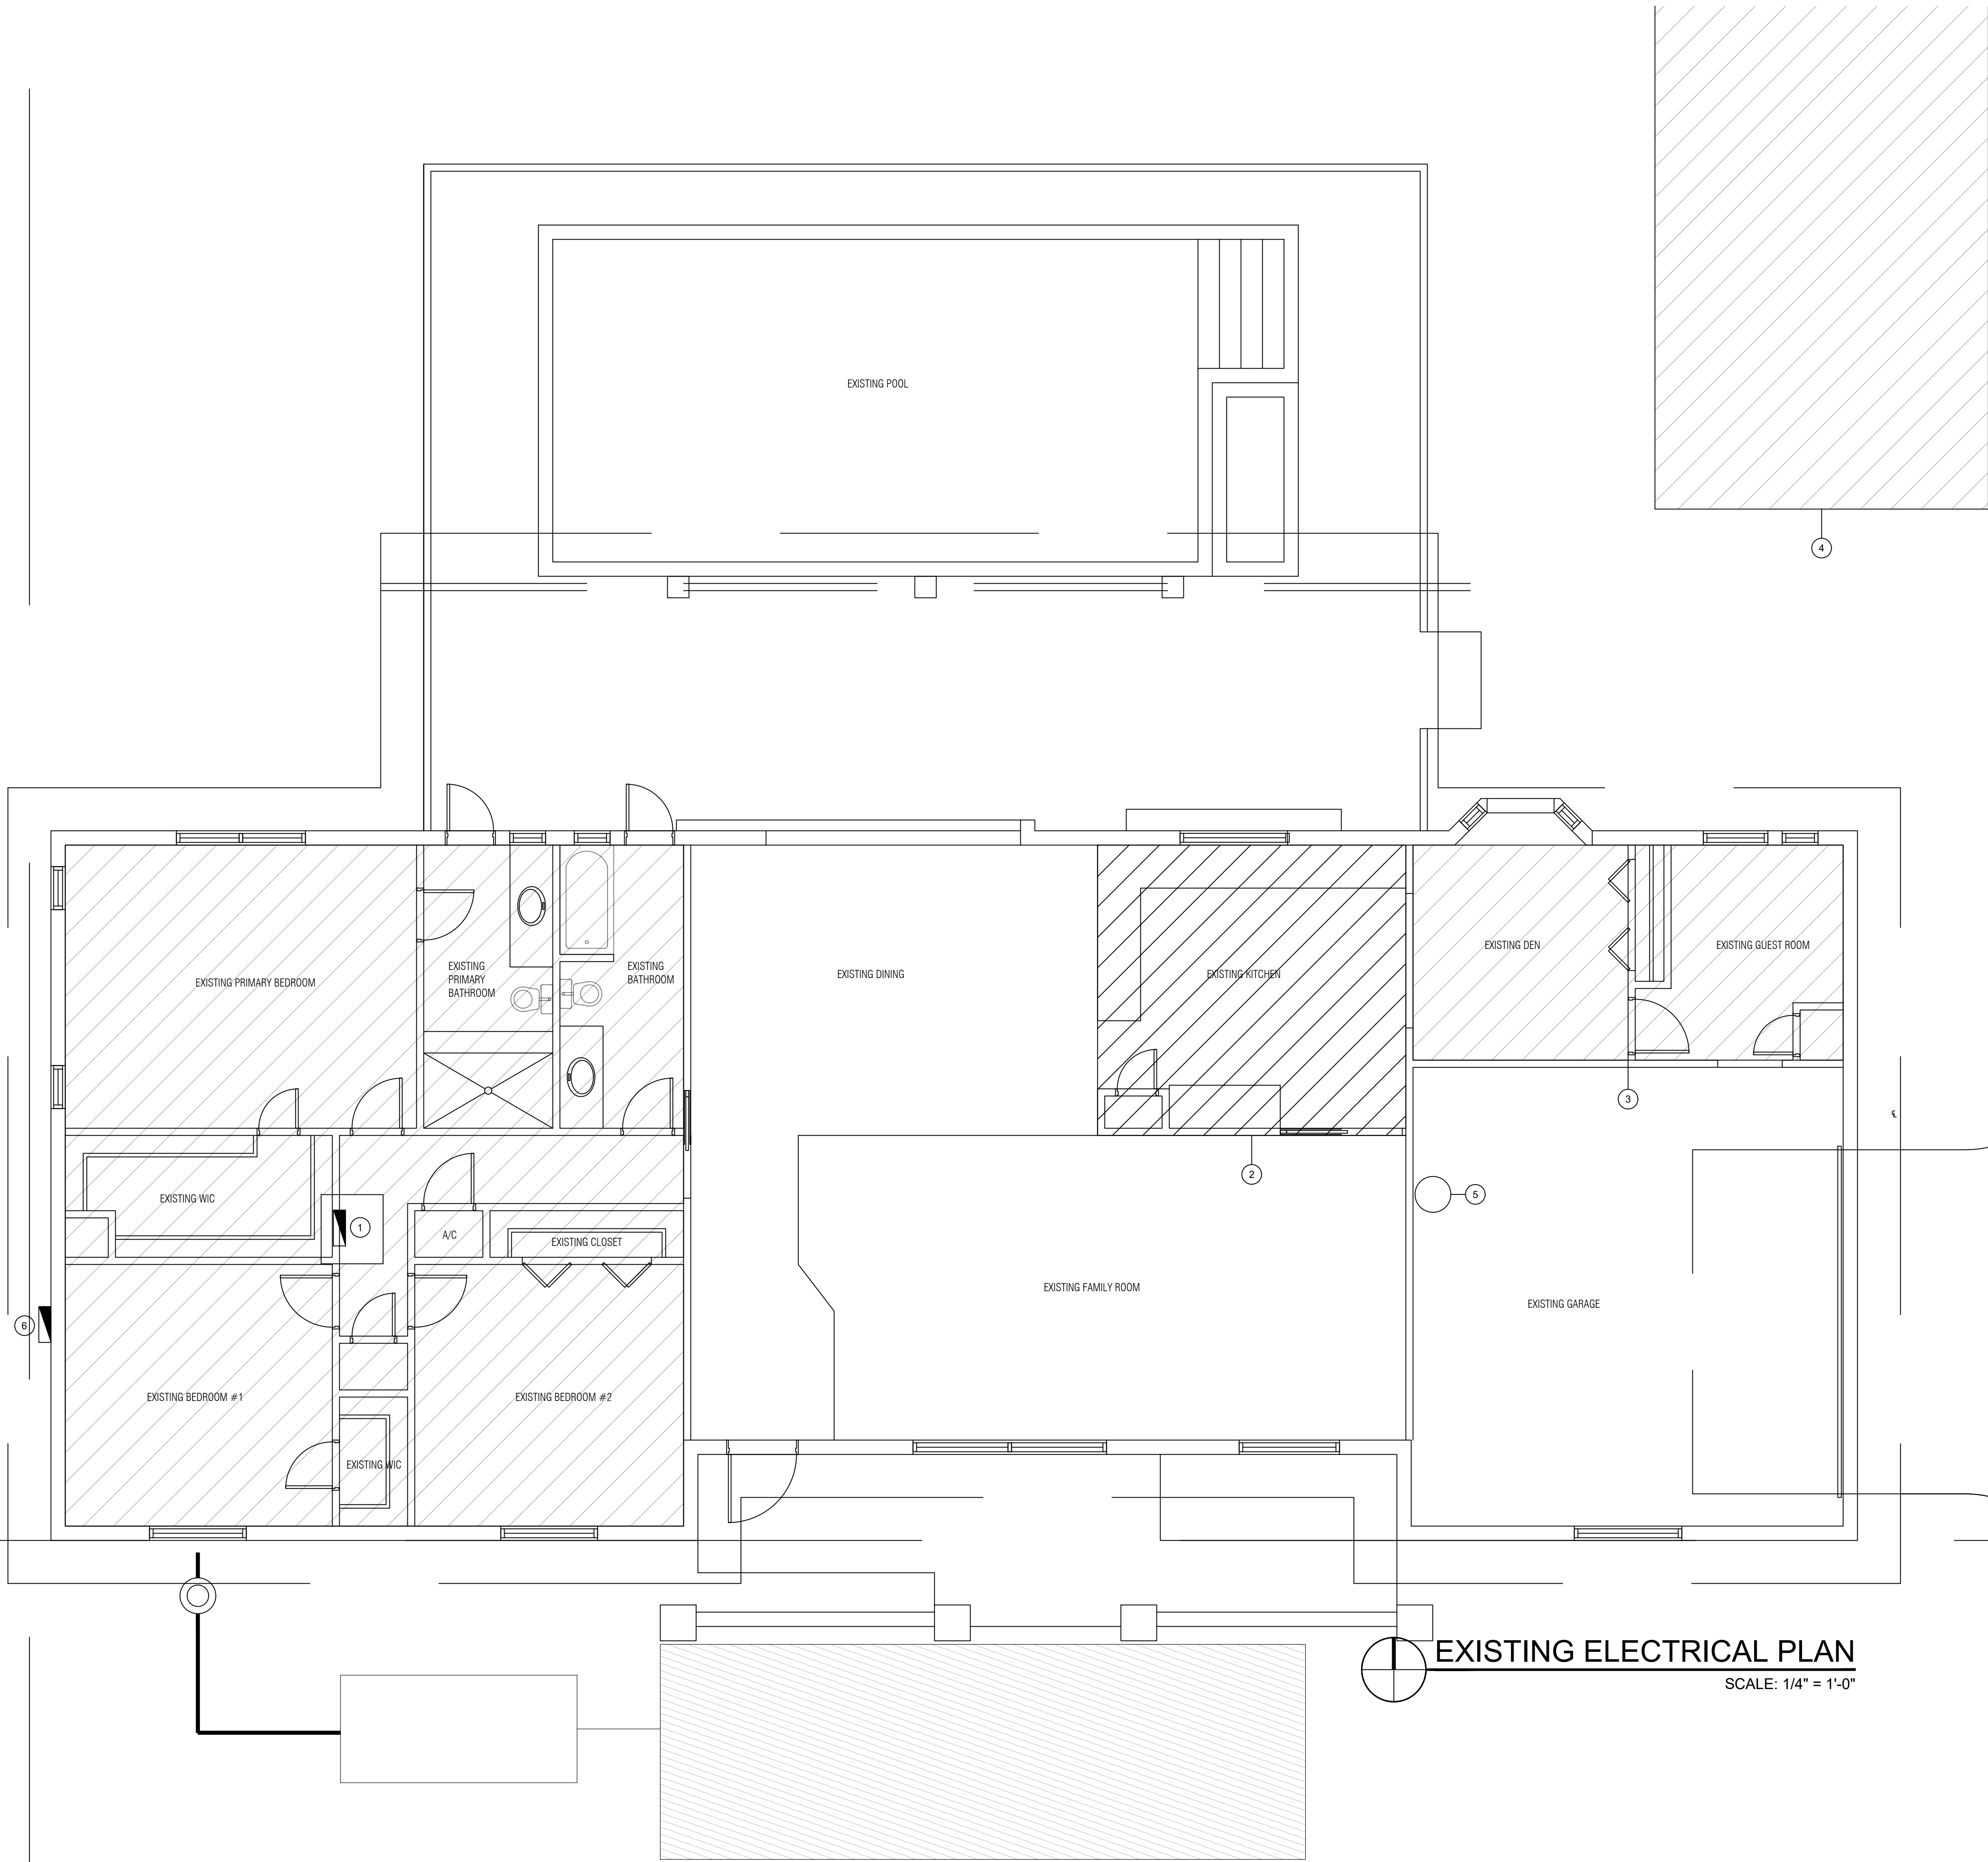


EXISTING ELECTRICAL PLAN
SCALE: 1/4" = 1'-0"

SCOPE OF WORK

1. RENOVATION TO AN EXISTING AIR CONDITIONED HOUSE.
2. PROVIDE NEW RECEPTACLE AND LIGHTING AS SHOWN.
3. EXISTING HVAC TO BE REPLACED.
4. NEW SEPARATE STRUCTURE TO BE ADDED.
5. EXISTING ELECTRICAL SERVICE TO BE UPGRADED.

KEY NOTES

1. REMOVE AND REPLACE EXISTING ELECTRICAL PANEL AND IN SAME LOCATION. SEE E5 FOR ADDITIONAL INFORMATION.
2. EXISTING KITCHEN TO REMAIN.
3. EXISTING DEN TO REMAIN.
4. NEW STRUCTURE TO BE BUILDING INCLUDING BATHROOM.
5. EXISTING ELECTRICAL WATER HEATER TO BE REPLACED WITH NEW IN SAME LOCATION.
6. EXISTING ELECTRICAL SERVICE TO BE REPLACED WITH NEW. SEE E5 FOR FURTHER INFORMATION.

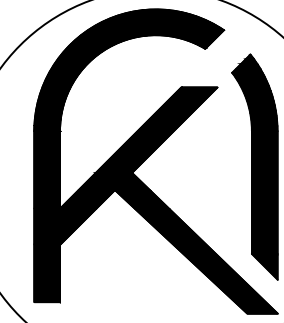

ARKO ARCHITECTURE, LLC
2980 McFARLANE RD, SUITE 200
COCONUT GROVE, FL 33133
edgardo@thearkgroup.com
eduardo@thearkgroup.com
c: 954.647.1447
c: 305.951.6181

ADDITION & RESTORATION FOR:

MAZZINI & MELINE
RESIDENCE

10300 SW 70TH AVE,
MIAMI, FL 33156



DRAWN BY
DATE 04.03.23 PROJECT
CHECKED BY 22-84

REVISIONS

EXISTING
ELECTRICAL
PLAN

CONSTRUCTION DOCUMENTS

E2