


This item has been digitally signed and sealed by Amarilis Rodriguez, P.E. on the date adjacent to the seal.
Printed copies of this document are not considered signed and sealed and the signature must be verified on any electronic copies.

arpe engineering inc
2020 Ponce de Leon Blvd., Suite 1002
Coral Gables, Florida 33134
Phone > 305 444 9809
Fax > 305 444 9827
Engineering Design:
> Mechanical > Electrical
> Plumbing > Fire Protection
www.arpe-eng.com
Amarilis Rodriguez, P.E.
License Number 60236
C.A. 20359
Signature _____
Date _____

1 WATER & GAS FIRST FLOOR PLAN
SCALE: 3/16"=1'-0"

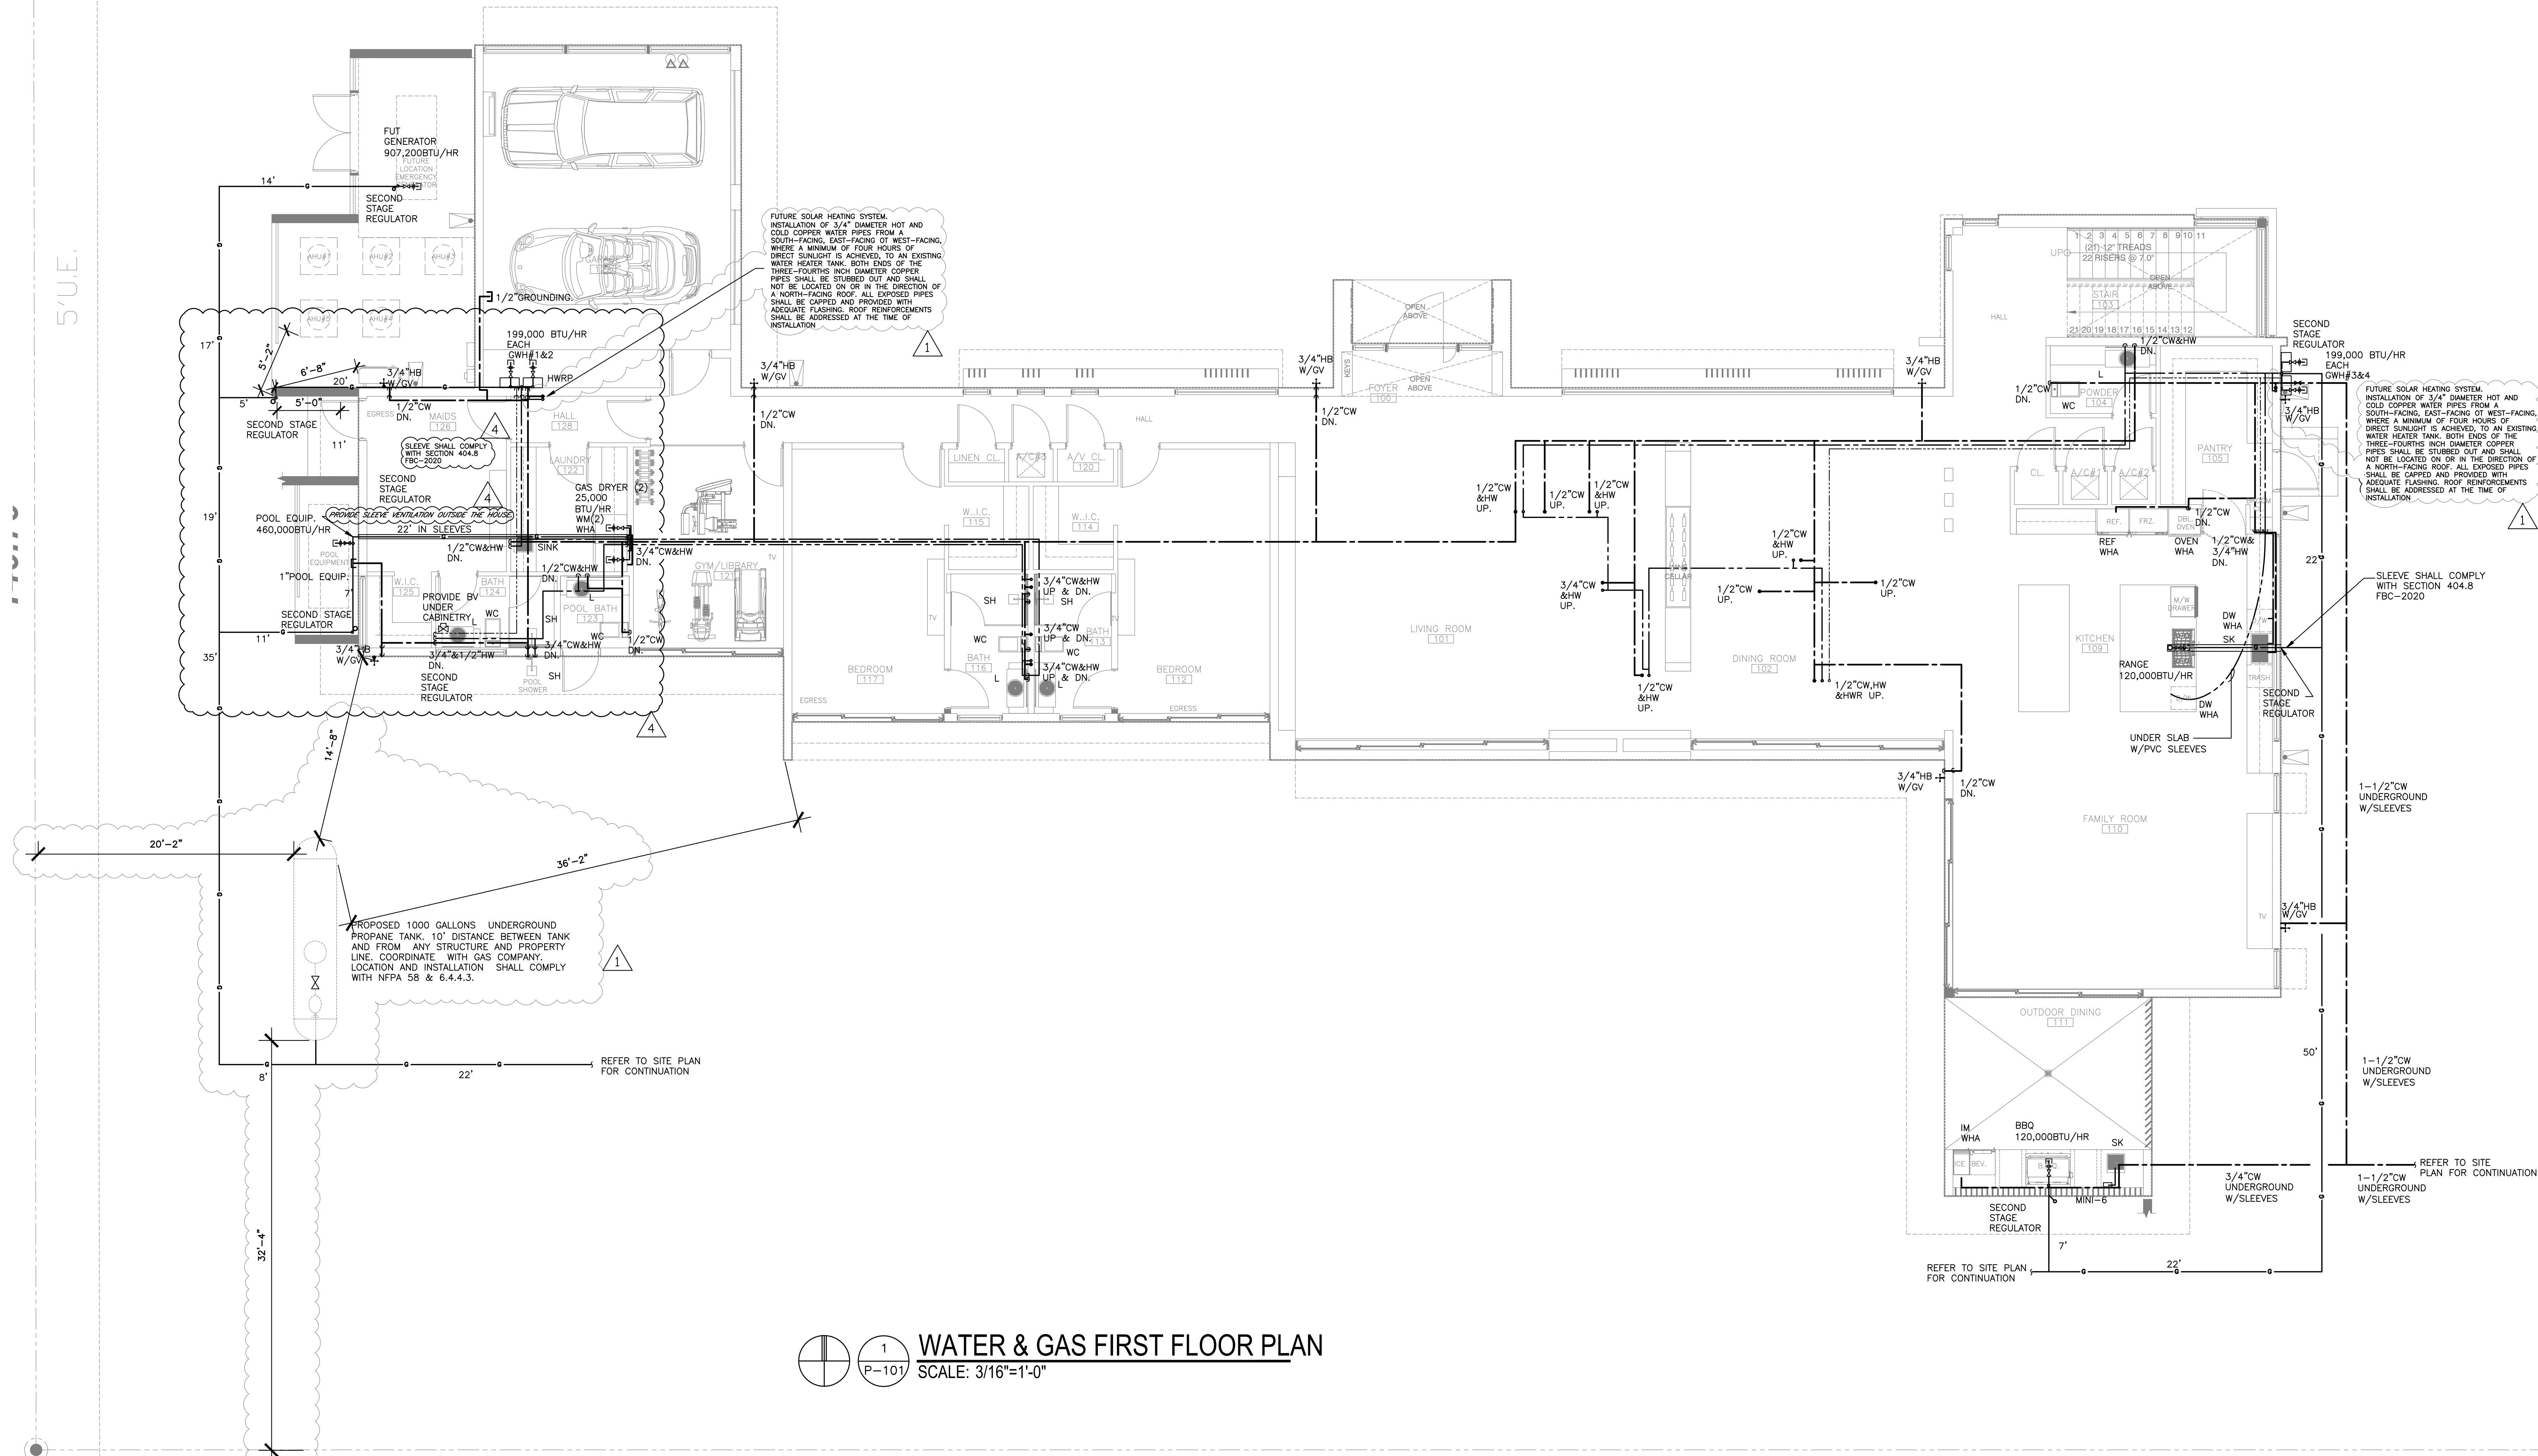

GAS NOTES

1- USE THE FLORIDA BUILDING CODE-FUEL 2020 GAS TABLE 402.4(36) TO DETERMINE PE PIPE SIZE FOR HIGH PRESSURE OUTSIDE THE BUILDING.

1A- USE THE FLORIDA BUILDING CODE-FUEL 2020 GAS TABLE 402.4(35) TO DETERMINE PE PIPE SIZE FOR LOW PRESSURE OUTSIDE THE BUILDING.


1B- USE THE FLORIDA BUILDING CODE-FUEL 2020 GAS TABLE 402.4(28) TO DETERMINE ME PIPE SIZE FOR LOW PRESSURE INSIDE THE BUILDING.

2- INSIDE OF BUILDING USE SCHEDULE 40 METALIC PIPE AND SHALL COMPLY WITH SECTION 403.4.1 THROUGH 403.4.4 FBC-2020.

3- UNDERGROUND PIPING FOR OUTSIDE OF BUILDING SHALL BE PLASTIC PIPE AND COMPLY WITH SECTION 404.14.1 THROUGH 404.14.3 AND SECTION 405.3 FBC-2020.

4- UNDERGROUND PIPING SYSTEM SHALL BE INSTALLED A MINIMUM DEPTH OF 12" BELOW GRADE.

5- UNDERGROUND PIPING FOR INSIDE OF BUILDING SHALL COMPLY WITH SECTION 404.11, FBC-2020.

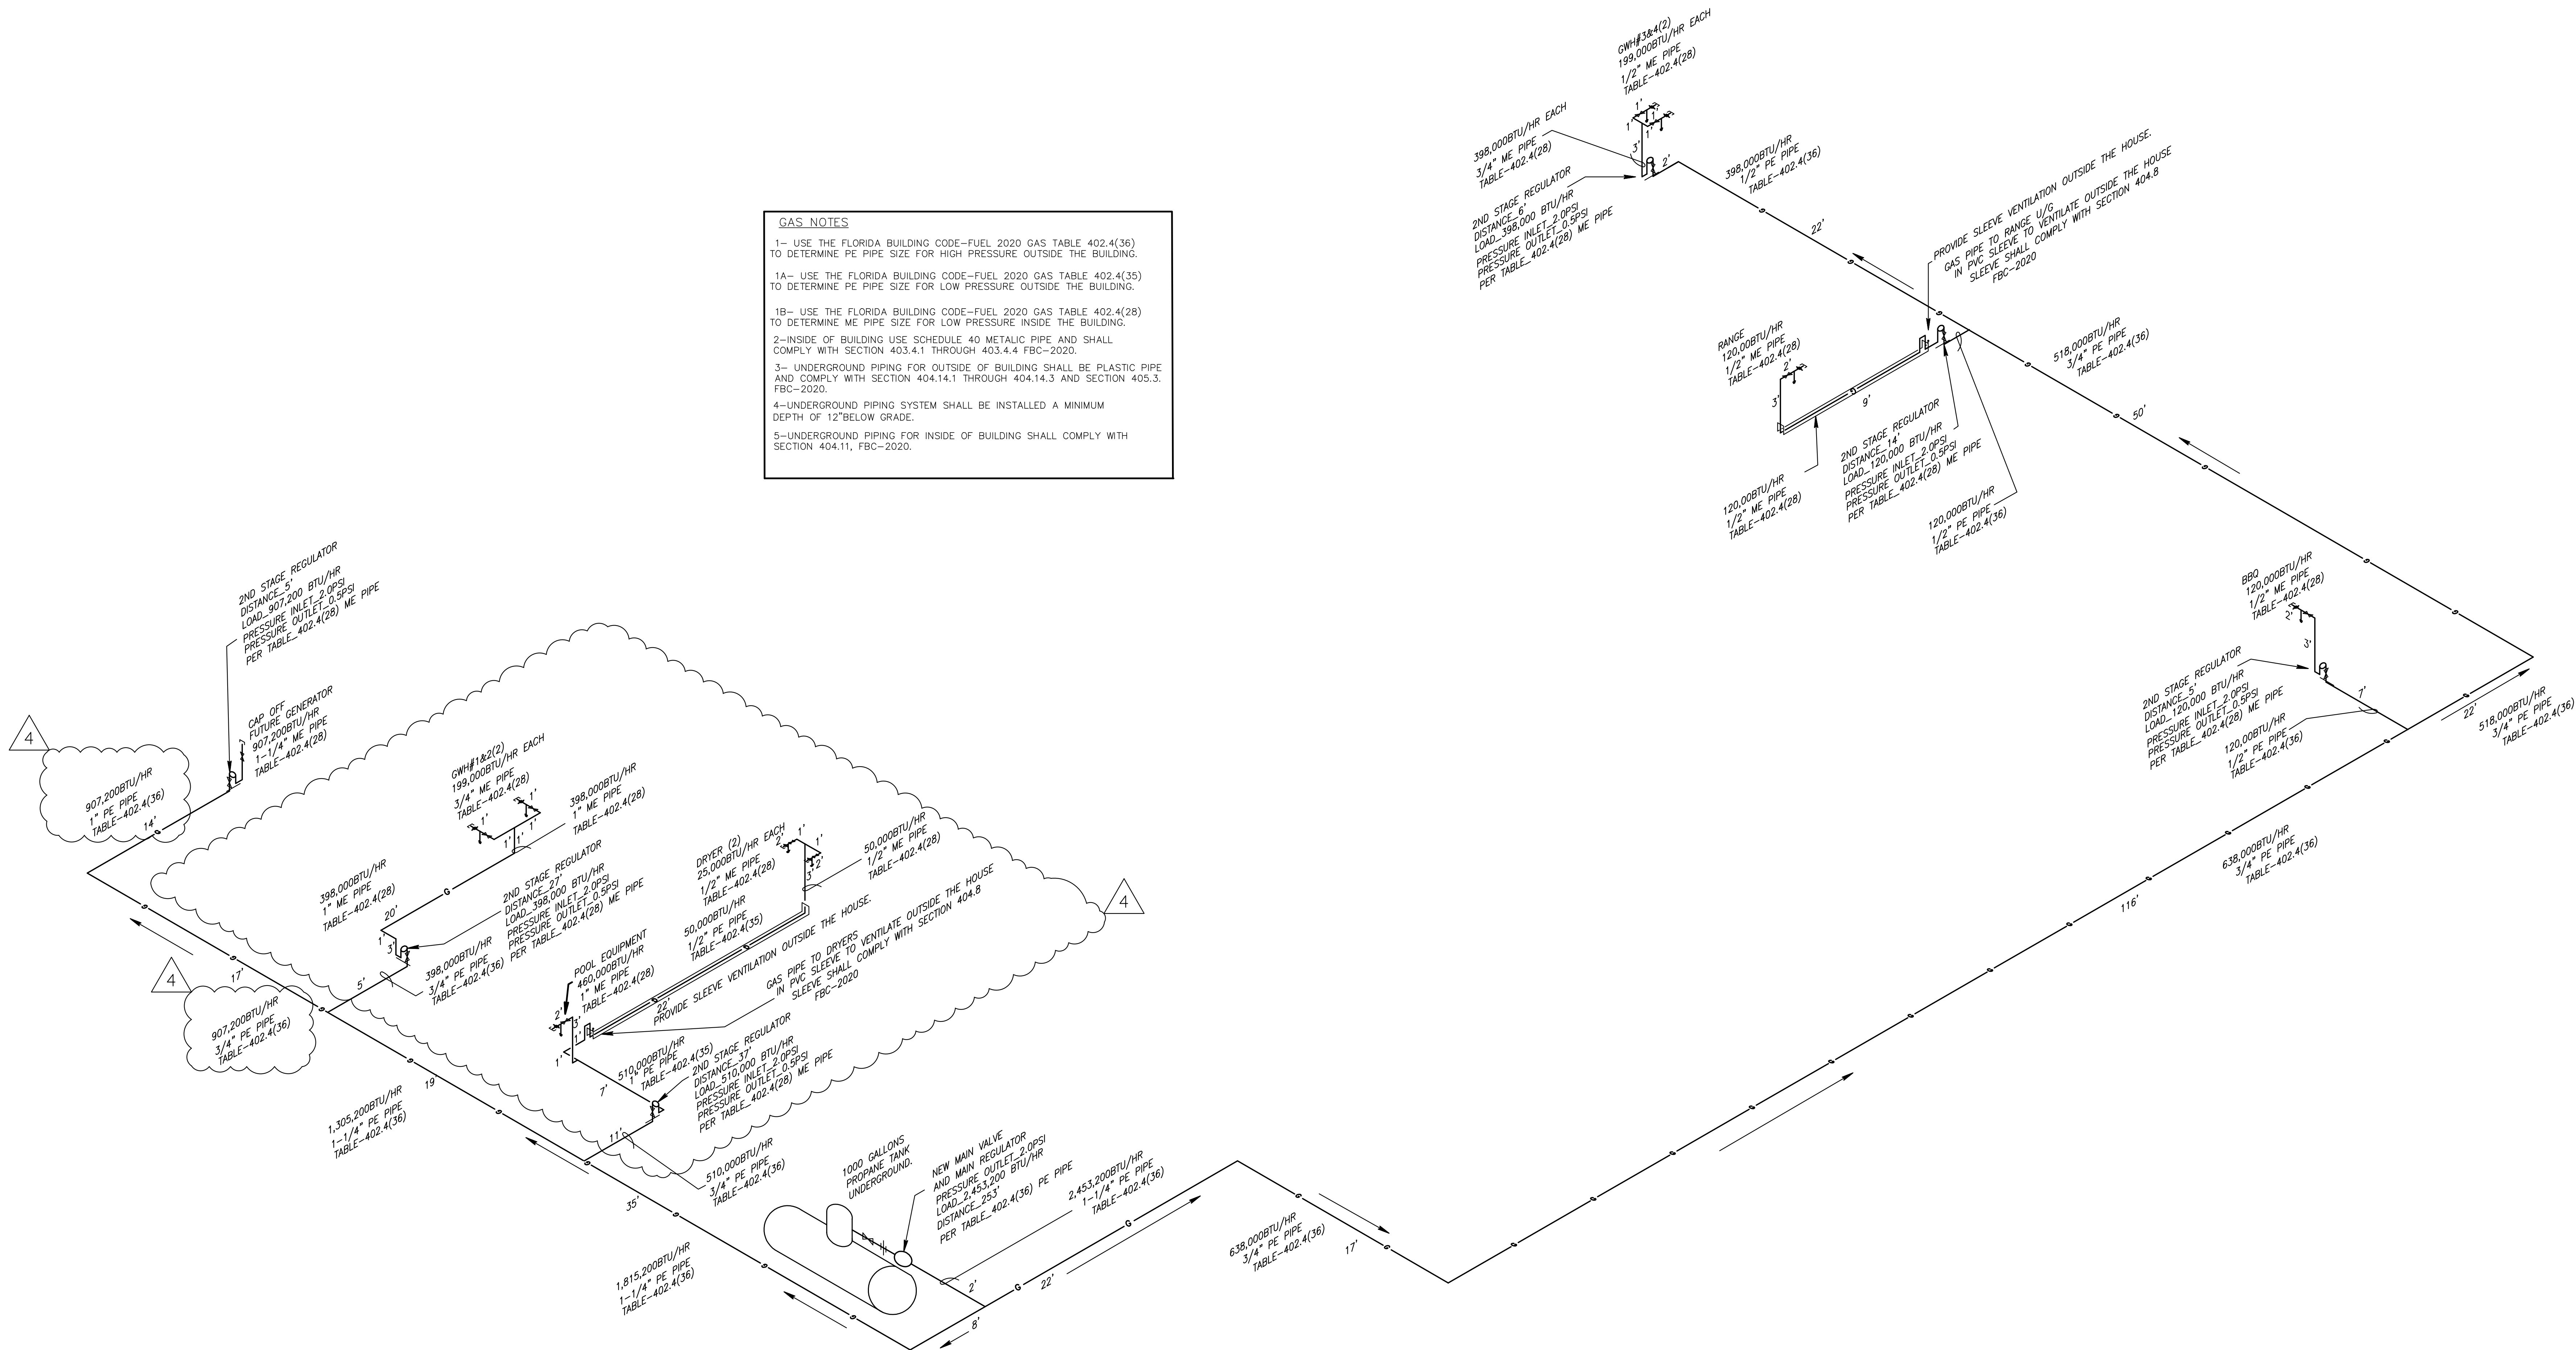

GAS ISOMETRIC
NOT TO SCALE

This item has been digitally signed and sealed by Amarilis Rodriguez, P.E. on the date adjacent to the seal.
Printed copies of this document are not considered signed and sealed and the signature must be verified
on any electronic copies.

JOB # 23-0822

arpe
Engineering inc
2020 Ponce de Leon Blvd., Suite 1002
Coral Gables, Florida 33134
Phone > 305.444.9809
Fax > 305.444.9827

Amarilis Rodriguez, P.E.
License Number 60236
C.A. 26350
Engineering Design
> Mechanical > Electrical
> Plumbing > Fire Protection
Signature _____
Date _____

www.arpe-eng.com